


FIRE PROTECTION DRAWINGS	
DRG. NO.	DESCRIPTION
SP-01	SITE PLAN AND GENERAL NOTES
SP-02	NFPA RULES AND GENERAL DETAILS 1
SP-03	NFPA RULES AND GENERAL DETAILS 2
SP-04	GENERAL NOTES AND VALVE SCHEDULE
SP-05	RISER SCHEMATIC & DETAILS
SP-06	RISER SCHEMATIC & DETAILS (CONT...)
SP-07	ISOMETRIC DIAGRAM - LOW PRESSURE ZONE
SP-08	ISOMETRIC DIAGRAM - HIGH PRESSURE ZONE
SP-09	P3 LEVEL
SP-10	P2 LEVEL
SP-11	P1 LEVEL
SP-12	GROUND FLOOR
SP-13	UPPER GROUND FLOOR
SP-14	2ND FLOOR
SP-15	3RD FLOOR TO 5TH FLOOR
SP-16	6TH FLOOR
SP-17	7TH FLOOR
SP-18	8TH FLOOR
SP-19	9TH FLOOR
SP-20	10TH-12TH FLOOR
SP-21	13TH-21ST FLOOR
SP-22	22TH-23RD FLOOR
SP-23	24TH-33TH FLOOR
SP-24	34TH FLOOR
SP-25	35TH FLOOR
SP-26	36TH FLOOR
SP-27	37TH FLOOR
SP-28	38TH FLOOR
SP-29	AMENITY FLOOR
SP-30	MECH. PENTHOUSE
SP-31	ELEVATOR MACHINE ROOM

775 Vaughan will be located at 775 Vaughan Road, Toronto ON., as shown in Figure 3-1.

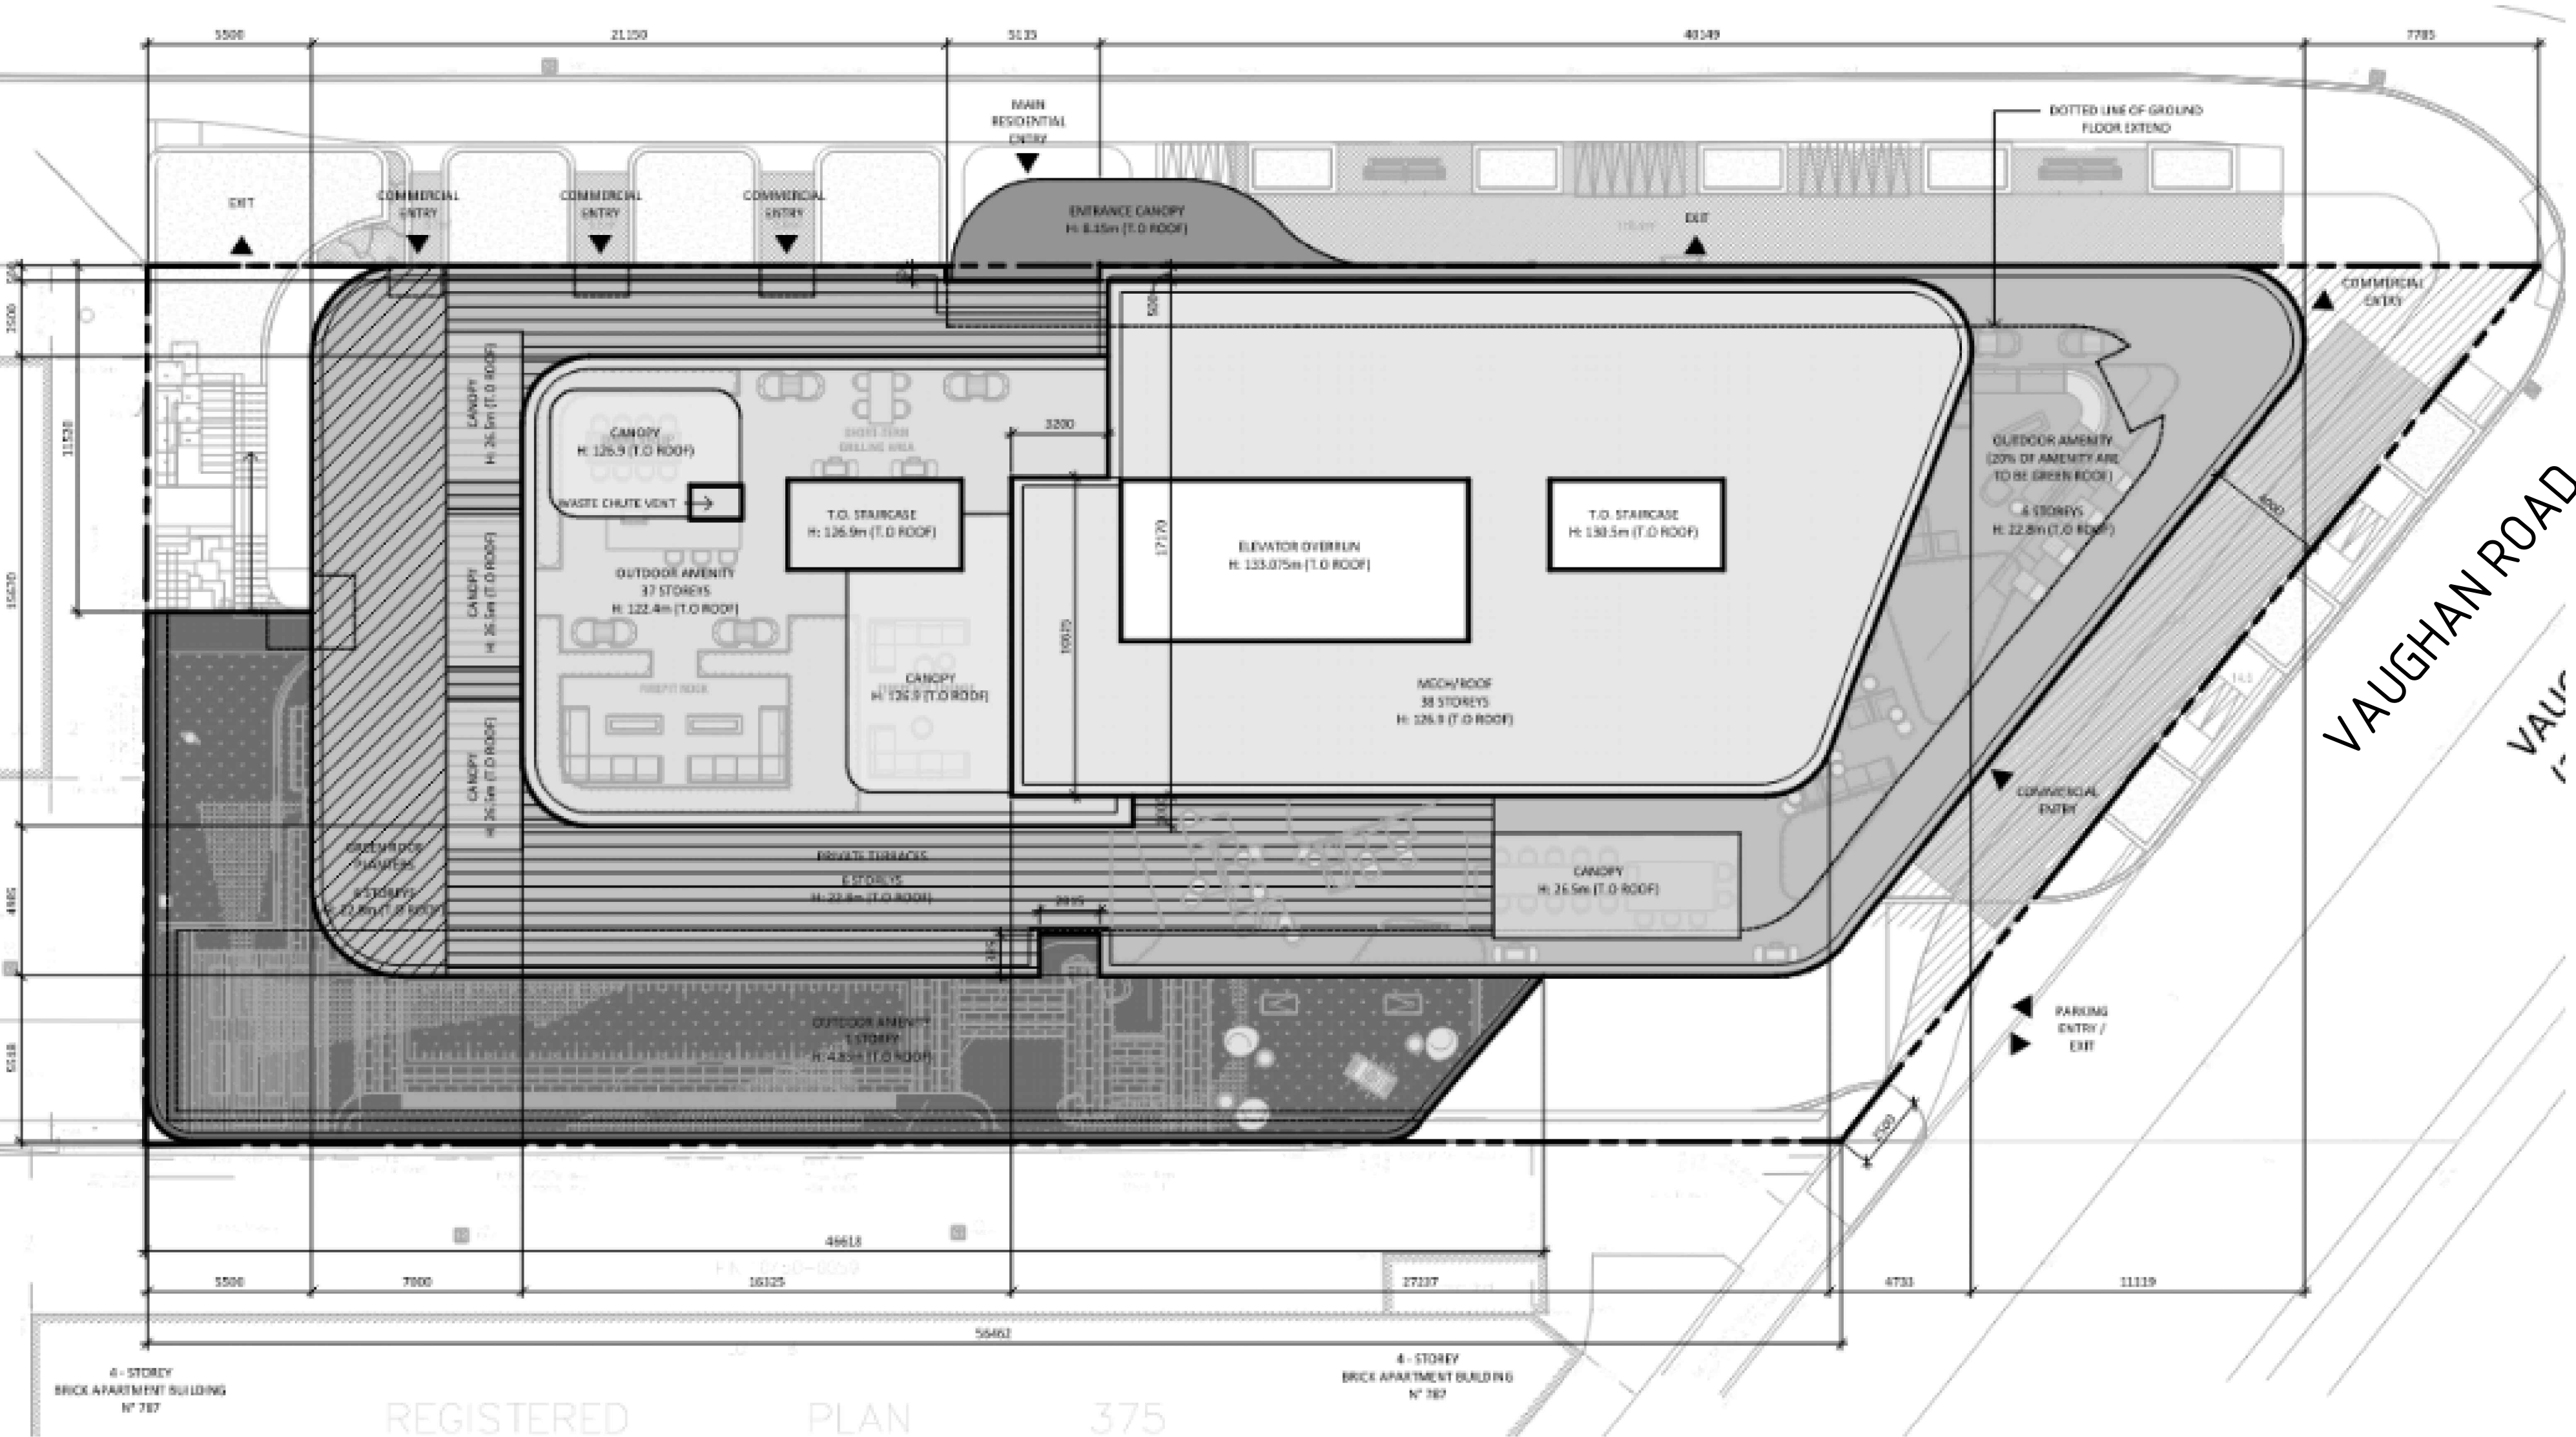

SITE PLAN

GENERAL NOTES

- NOTE 1:**
SPRINKLERS SHALL BE INSTALLED IN ALL OF BATHROOMS AND CLOSETS AS PER NFPA-13.

NOTE 2:
WHERE SIDEWALL SPRINKLER IS INSTALLED AT SOFFIT (BULKHEAD) EXCEEDING MORE THAN 8" IN WIDTH, PENDENT SPRINKLERS SHALL BE INSTALLED UNDER THE SOFFIT (BULKHEAD).

NOTE 3:
RESIDENTIAL SIDEWALL SPRINKLERS SHALL BE PERMITTED TO BE INSTALLED IN THE FACE OF A SOFFIT LOCATED DIRECTLY OVER CABINETS WITHOUT REQUIRING ADDITIONAL SPRINKLERS BELOW THE SOFFIT OR CABINETS WHERE THE SOFFIT DOES NOT PROJECT HORIZONTALLY MORE THAN 12" FROM THE WALL.

NOTE 4:
IF CPVC PIPE IS USED, CONTRACTOR TO PROVIDE "EXPANSION OFFSET LOOP" ON STRAIGHT RUNS EXCEEDING 100 FT IN LENGTH.


NOTE 5:
ANY FIRE STOPPING, ACOUSTIC SEALANT AND MATERIALS USED IN THIS PROJECT WHICH COME IN CONTACT WITH CPVC SPRINKLER PIPING IS TO BE COMPATIBLE WITH CPVC PIPING.
- NOTE 6:**
CONTRACTOR SHALL COORDINATE WITH LIGHTING, DIFFUSER & INTERIOR DESIGN DRAWINGS PRIOR TO INSTALLATION OF SPRINKLER SYSTEM.

PENDENT SPRINKLERS SHALL BE POSITIONED AWAY FROM LIGHT FIXTURES A MIN. DISTANCE OF 4 TIMES THE MAX. DIMENSION OF THE OBSTRUCTION (FIXTURE). THE MAX. 36".

NOTE 7:
SPRINKLER LAYOUT BASED ON BULKHEADS BEING MAXIMUM 12" DEEP AS PER ARCH. DWGS. ADDITIONAL SIDEWALL SPRINKLERS MAY BE REQUIRED IF BULKHEAD DEPTH EXCEEDS 12".

NOTE 8:
CEILING POCKETS IN BEDROOMS
SPRINKLERS ARE REQUIRED IN ALL CEILING POCKETS, EXCEPT BEDROOMS THAT CONFORM TO THE FOLLOWINGS.

 - 1) THE TOTAL VOLUME OF THE UNPROTECTED CEILING POCKET DOES NOT EXCEED 100 CU.FT.
 - 2) THE DEPTH OF THE UNPROTECTED CEILING POCKET DOES NOT EXCEED 12 IN.
 - 3) THE PENDENT SPRINKLER IS WITHIN 10' OF ALL OF WALLS.
 - 4) THE INTERIOR FINISH OF THE UNPROTECTED CEILING POCKET IS NONCOMBUSTIBLE OR LIMITED-COMBUSTIBLE CONSTRUCTION.

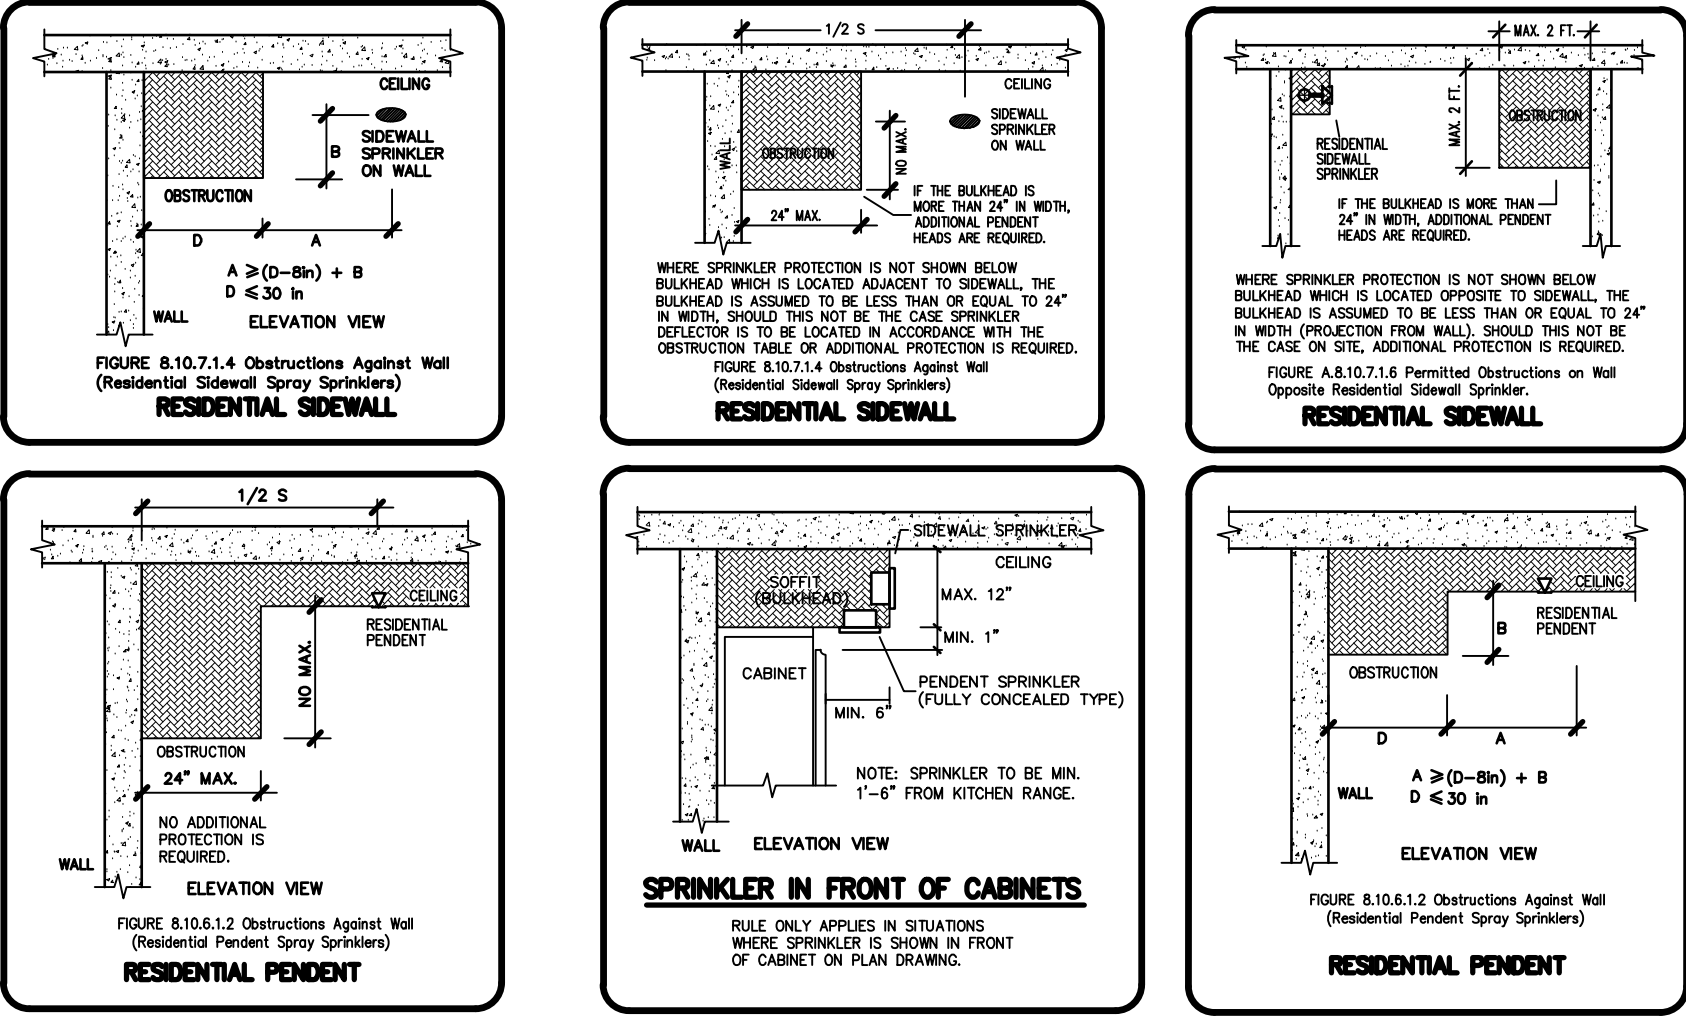

PROJECT
PROPOSED MIXED-USED DEVELOPMENT
ADDRESS:
775-783 Vaughan Rd & 670-680
Northcliffe Blvd, York, ON

DRAWING TITLE
SITE PLAN AND GENERAL NOTES

LIFELINE FIRE PROTECTION
www.lifelinefireprotection.com

50 Casimir Court, Concord, ON
L4K 4J5
(416)850-9477

PROJECT NORTH
TRUE NORTH

22-0007
PROJECT

SK RJ
BY REVIEWED

SP-01

FIRE PROTECTION NOTES:

PROJECT SCOPE OF WORK:

THIS PROJECT CONSISTS OF DESIGNING AND INSTALLING AN OVERHEAD WET & DRY SPRINKLER SYSTEM ALONG WITH STANDPIPE SYSTEM IN A NEW 41 STOREY

APARTMENT BUILDING. THE BUILDING AREA IS APPROXIMATELY 14,714 SQ FT (1,367 SQ.M) AND THE STARTING POINT OF INSTALLATION IS 6" FLANGED CONNECTION LOCATED IN THE SPRINKLER ROOM.

BUILDING DETAILS:

BUILDING DESCRIPTION: NEW 41-STOREY RESIDENTIAL/ MIXED USE BUILDING

FIRE ALARM: YES

BUILDING CONSTRUCTION: NON-COMBUSTIBLE, CONCRETE SLAB

ONTARIO BUILDING CODE CLASSIFICATION: GROUP C , GROUP A2 & GROUP F3 OCCUPANCY

SPRINKLER SYSTEM DESIGN:

THIS SPRINKLER SYSTEM HAS BEEN DESIGNED IN ACCORDANCE WITH THE

FOLLOWING CODES & STANDARDS:

- NFPA 13 (2013) "STANDARD FOR THE INSTALLATION OF SPRINKLER SYSTEMS"
- THE ONTARIO BUILDING CODE (2012)

DESIGN CRITERIA - RESIDENTIAL:

AREAS INCLUDED:

RESIDENTIAL SUITES & ADJOINING CORRIDORS

CODE REFERENCES:

1. NFPA 13 - FIGURE 11.3.1.1: FOUR ADJACENT SPRINKLERS THAT PRODUCE THE GREATEST HYDRAULIC DEMAND
2. NFPA 13 - FIGURE 11.3.1.3: THE GREATER OF

2.1. - 0.10 GPM/FT2 OVER THE DESIGN AREA OF THE SPRINKLER HEADS, OR

2.2. - THE MINIMUM FLOW RATES INDICATED IN THE SPRINKLER LISTING.

NFPA 13 - 11.3.2.2 AND TABLE 11.2.3.1.2: RESIDENTIAL HAZARD -> 100 GPM HOSE ALLOWANCE

DESIGN CRITERIA - ORDINARY HAZARD I:

AREAS INCLUDED:

MECHANICAL PENTHOUSE, BIKE STORAGE, PARKING GARAGE

CODE REFERENCES:

1. NFPA 13 - FIGURE 11.2.3.1.1: CHOOSE 0.15 USGPM / FT2 OVER 1,500 SQ. FT
2. NFPA 13 - FIGURE 11.2.3.2.3.1: A DESIGN AREA INCREASE OF 30% WAS APPLIED FOR DRY SYSTEM.

THE RESULTING DESIGN AREA IS 1950 SQ. FT

3. NFPA 13 - TABLE 11.2.3.1.2: ORDINARY HAZARD I -> 250 USGPM HOSE ALLOWANCE

STORAGE CRITERIA:

AS PER NFPA 13, PRODUCT STORAGE IS NOT TO EXCEED THE FOLLOWING HEIGHTS

FOR ORDINARY HAZARD I OCCUPANCIES:

- CLASS I COMMODITIES: 12'-0" HIGH MAXIMUM (SOLID PILE OR RACK)

- CLASS II COMMODITIES: 10'-0" HIGH MAXIMUM (SOLID PILE OR RACK)

- CLASS III-IV COMMODITIES: NOT PERMITTED

- PLASTICS COMMODITIES: NOT PERMITTED

NO IDLE WOOD OR PLASTIC PALLET STORAGE ALLOWED

DESIGN CRITERIA - ORDINARY HAZARD II:

AREAS INCLUDED:

LOCKER ROOMS, GARBAGE ROOM

CODE REFERENCES:

1. NFPA 13 - FIGURE 11.2.3.1.1: CHOOSE 0.2 USGPM / FT2 OVER 1,500 SQ. FT
2. NFPA 13 - FIGURE 11.2.3.2.3.1: A DESIGN AREA INCREASE OF 30% WAS APPLIED FOR DRY SYSTEM.

THE RESULTING DESIGN AREA IS 1950 SQ. FT

3. NFPA 13 - TABLE 11.2.3.1.2: ORDINARY HAZARD II -> 250 USGPM HOSE ALLOWANCE

STORAGE CRITERIA:

AS PER NFPA 13, PRODUCT STORAGE IS NOT TO EXCEED THE FOLLOWING HEIGHTS

FOR ORDINARY HAZARD II OCCUPANCIES:

- CLASS III-IV COMMODITIES: 12'-0" HIGH MAXIMUM (SOLID PILE OR RACK)

- CLASS IV COMMODITIES: 12'-0" HIGH MAXIMUM (SOLID PILE)

- CLASS IV COMMODITIES: 10'-0" HIGH MAXIMUM (RACK)

- PLASTICS COMMODITIES: 5'-0" HIGH MAXIMUM (SOLID PILE)

NO IDLE WOOD OR PLASTIC PALLET STORAGE ALLOWED

DESIGN CRITERIA - LIGHT HAZARD:

AREAS INCLUDED:

AMENITIES, MAIL ROOM

CODE REFERENCES:

1. NFPA 13 - FIGURE 11.2.3.1.1: CHOOSE 0.10 USGPM/FT2 OVER 1,500 SQ. FT
2. NFPA 13 - FIGURE 11.2.3.2.3.1: A DESIGN AREA REDUCTION OF 40% WAS APPLIED FOR QUICK RESPONSE SPRINKLERS. THE RESULTING DESIGN IS 900 SQ. FT.

3. NFPA 13 - TABLE 11.2.3.1.2: LIGHT HAZARD -> 100 USGPM HOSE ALLOWANCE

STANDPIPE DESIGN:

THE STANDPIPE SYSTEM HAS BEEN DESIGNED IN ACCORDANCE WITH THE

FOLLOWING CODES & STANDARDS:

- NFPA 14 (2013) "STANDARD FOR THE INSTALLATION OF STANDPIPE SYSTEMS"
- THE ONTARIO BUILDING CODE (2012)

STANDPIPE DESIGN CRITERIA:

BUILDING HEIGHT: 134 M (440 feet)

NUMBER OF STOREYS: 41

BUILDING AREA: 1367 SQ.M (14,714 SQ.FT)

ONTARIO BUILDING CODE (OBC) REFERENCES:

1. OBC 3.2.9.3.(1): 38 MM (1-1/2") HOSE VALVES ARE REQUIRED
2. OBC 3.2.9.3.(2): 65 mm (2-1/2") HOSE VALVES ARE REQUIRED

3. OBC 3.2.9.7.(4): IF THE BUILDING IS 4M OR HIGH, MEASURED BETWEEN GRADE AND THE CEILING LEVEL IF THE TOP STOREY, THE BUILDING SHALL BE SERVED BY NO FEWER THAN TWO SOURCES OF

WATER SUPPLY FROM A PUBLIC WATER SYSTEM.

NFPA 14 SYSTEM CLASS:

CLASS I WET STANDPIPE SYSTEM

WATER SUPPLY INFORMATION:

STATIC: 60 PSI

RESIDUAL: 52 PSI

HANGERS:

REFER TO THE HANGER DETAILS SECTION

MATERIAL NOTES:

ALL MATERIALS SHALL BE ULC LISTED FOR FIRE PROTECTION USE IN ACCORDANCE WITH NFPA 13 STANDARDS.

ITEMS NOT INCLUDED IN THIS CONTRACT:

- ELECTRICAL WIRING OF SPRINKLER DEVICES
- PAINTED OR GALVANIZED SPRINKLER PIPING
- UNDERGROUND INCOMING WATER SUPPLY
- FIRE EXTINGUISHERS

NOTES TO THE OWNER / OCCUPANTS:


THE OWNER / OCCUPANT IS RESPONSIBLE FOR SUPPLYING & MAINTAINING ADEQUATE HEAT (4°C, 40°F) TO ALL AREAS WHERE WET PIPING IS INSTALLED IN ORDER TO PREVENT THE WET PIPING FROM FREEZING.

GENERAL SPECIFICATIONS:

1. THESE DRAWINGS ARE FOR PERMIT AND TENDER PURPOSES AND ARE NOT TO BE USED FOR CONSTRUCTION.
4. THE FIRE PROTECTION CONTRACTOR IS TO COORDINATE INSTALLATION WITH NEW AND EXISTING SITE CONDITIONS AND ACCEPT RESPONSIBILITY FOR COORDINATION ACTIVITIES AND COST OF MAKING ADJUSTMENTS TO PIPE ROUTING AND SIZES TO AVOID INTERFERENCE WITH ARCHITECTURAL, STRUCTURAL AND MEP SERVICES. VERIFY ALL DIMENSIONS AND REPORT DISCREPANCIES TO THE DESIGN CONSULTANTS BEFORE PROCEEDING WITH THE WORK.
5. UPON COMPLETION OF INSTALLATION, THE FIRE PROTECTION CONTRACTOR SHALL HYDROSTATICALLY TEST THE SYSTEM(S) IN ACCORDANCE WITH THE REQUIREMENTS OF NFPA 13 (2013) AND SUBMIT COMPLETED CONTRACTOR'S MATERIAL AND TEST CERTIFICATES TO THE AUTHORITY HAVING JURISDICTION AND THE DESIGN CONSULTANTS.
6. ALL WORK SHALL BE PERFORMED IN ACCORDANCE WITH ALL LOCAL CODES, STANDARDS, BY-LAWS, PROJECT SPECIFICATIONS, AND AUTHORITIES HAVING JURISDICTION.
7. ALL SYSTEM COMPONENTS TO BE ULC LISTED AND IN ACCORDANCE WITH NFPA 13 (2013).
8. THE FIRE PROTECTION CONTRACTOR SHALL PROVIDE A MATERIAL DATA SUBMITTAL PACKAGE TO THE DESIGN CONSULTANTS FOR REVIEW PRIOR TO FABRICATION AND INSTALLATION.
9. MEET ALL OBSTRUCTION CRITERIA IN ACCORDANCE WITH NFPA 13 (2013).
10. PROVIDE SPRINKLER HEADS OF A SUITABLE TEMPERATURE RATING BASED ON THE PROXIMITY TO ALL HEAT SOURCES IN ACCORDANCE WITH NFPA 13 (2013).
11. INSTALL WIRE GUARDS ON ALL SPRINKLER HEADS SUSCEPTIBLE TO MECHANICAL DAMAGE INCLUDING BUT NOT LIMITED TO MECHANICAL ROOMS, ELECTRICAL ROOMS, STORAGE ROOMS, GYMNASIUMS, UNDER STAIRS, ETC.
12. PROVIDE LOW POINT DRAINS ON ALL TRAPPED SECTIONS OF PIPE IN ACCORDANCE WITH NFPA 13 (2013). DISCHARGE TO AN APPROVED LOCATION.
13. PROVIDE A STOCK OF SPARE SPRINKLER HEADS AND ASSOCIATED WRENCHES IN A METAL CABINET MOUNTED ON THE WALL NEAR THE MAIN FIRE PROTECTION VALVE HEADER. AMOUNT OF SPARE SPRINKLER HEADS TO BE PER NFPA 13 (2013).
14. FIRE STOP ALL PENETRATIONS IN RATED WALLS, CEILINGS AND FLOORS WITH LISTED AND APPROVED SYSTEMS.
15. ALL ELECTRICAL WIRING OF FIRE PROTECTION DEVICES IS BY OTHERS. COORDINATE WITH ELECTRICAL AND FIRE ALARM CONTRACTORS.
16. ALL PIPE LENGTHS ARE SHOWN AS CENTRE-TO-CENTRE LENGTHS.

CEILING OBSTRUCTION
RESIDENTIAL SIDEWALL



THE CLEAR DISTANCE REQUIRED SHALL BE 8'-0" (2440mm)
THIS DISTANCE IS TO BE MEASURED FROM THE CENTRE OF THE SPRINKLER TO THE EDGE OF THE OBSTRUCTION AS PER NFPA 13 (2013) 8.10.7.1.2

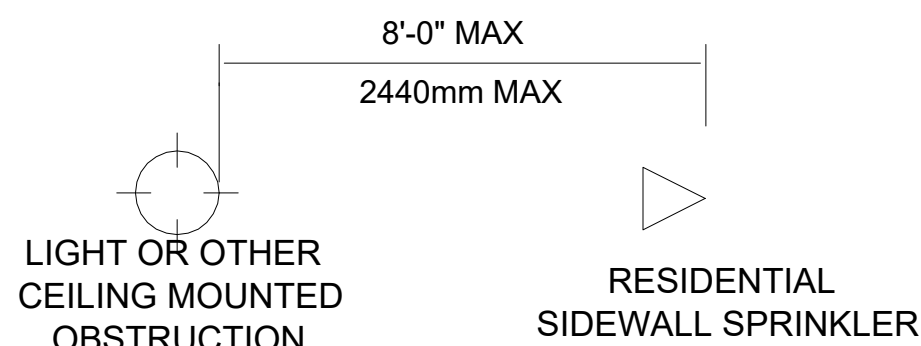

CEILING OBSTRUCTION
RESIDENTIAL PENDENT
(FOUR TIMES RULE)

RESIDENTIAL PENDENT SPRINKLERS SHALL BE A MINIMUM DISTANCE OF FOUR TIMES THE MAXIMUM DIMENSION OF THE OBSTRUCTION (IE. LIGHTS & CEILING FANS). THE MAXIMUM CLEAR DISTANCE REQUIRED SHALL BE 3'-0" (914mm)


THIS DISTANCE IS TO BE MEASURED FROM THE CENTRE OF THE SPRINKLER TO THE EDGE OF THE OBSTRUCTION AS PER NFPA 13 (2013) 8.10.6.2.1.3.

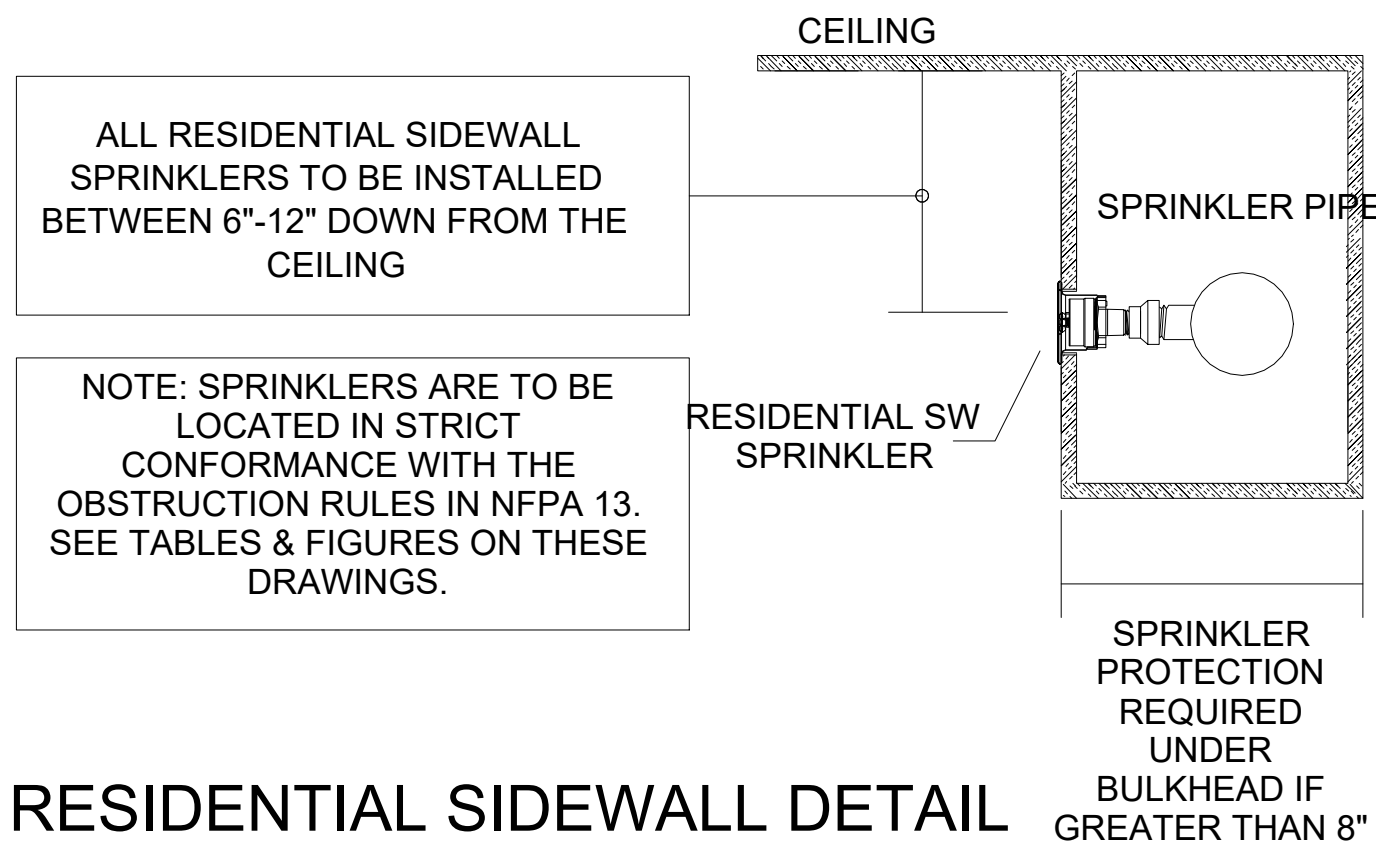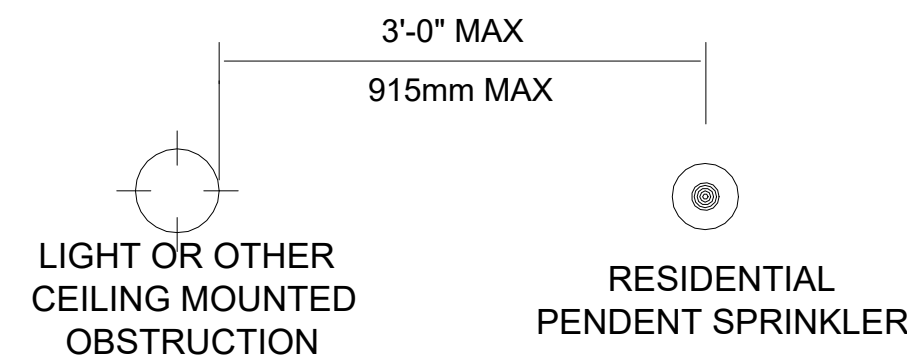


RESIDENTIAL SIDEWALL DETAIL
NOT TO SCALE

PERMITTED OBSTRUCTION ON WALL OPPOSITE
RESIDENTIAL SIDEWALL SPRINKLERS


FIGURE A.8.10.7.1.6

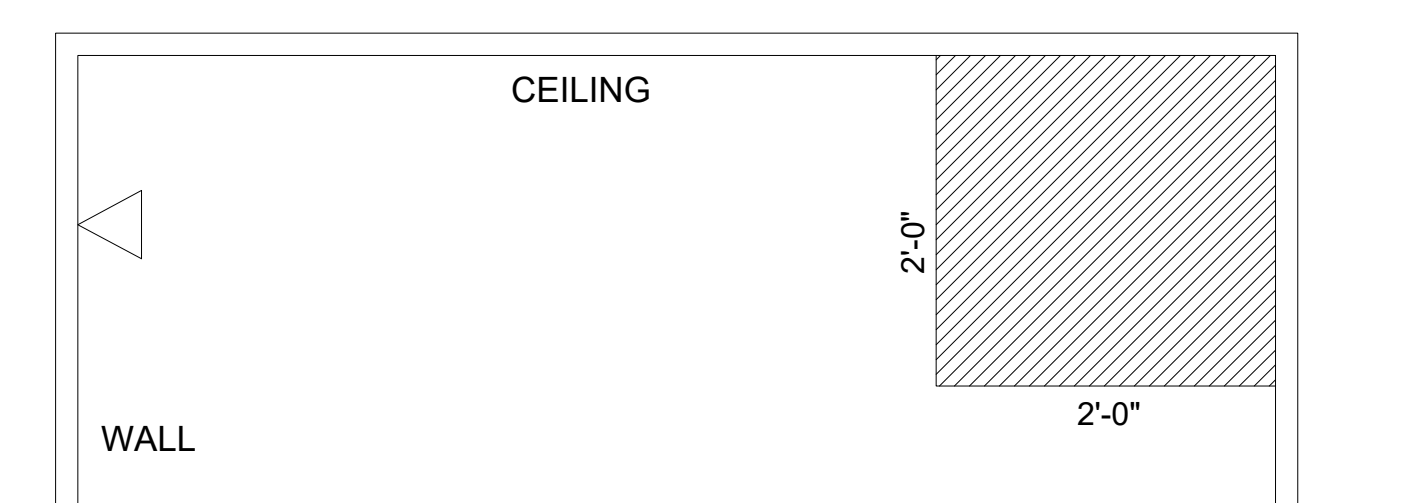

STEEL PIPES THROUGH CONCRETE

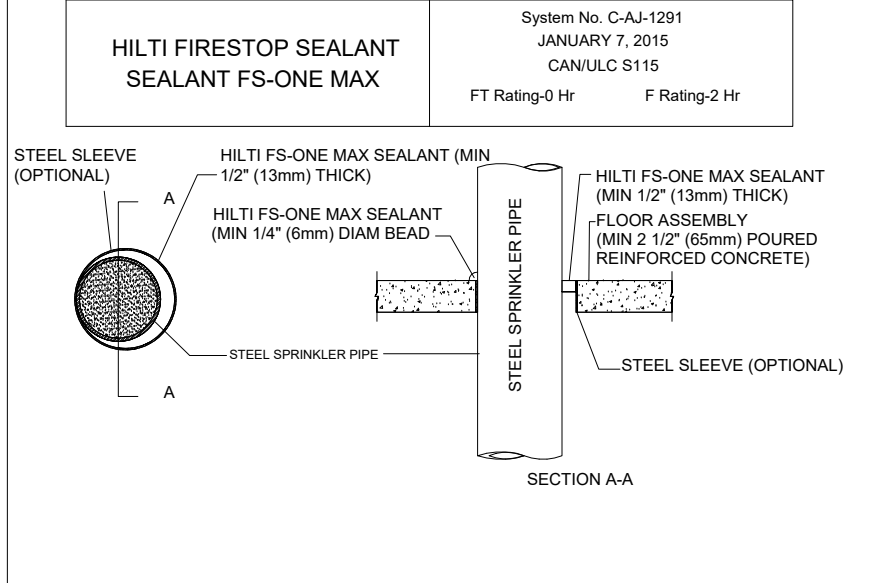

STEEL PIPES THROUGH GYPSUM

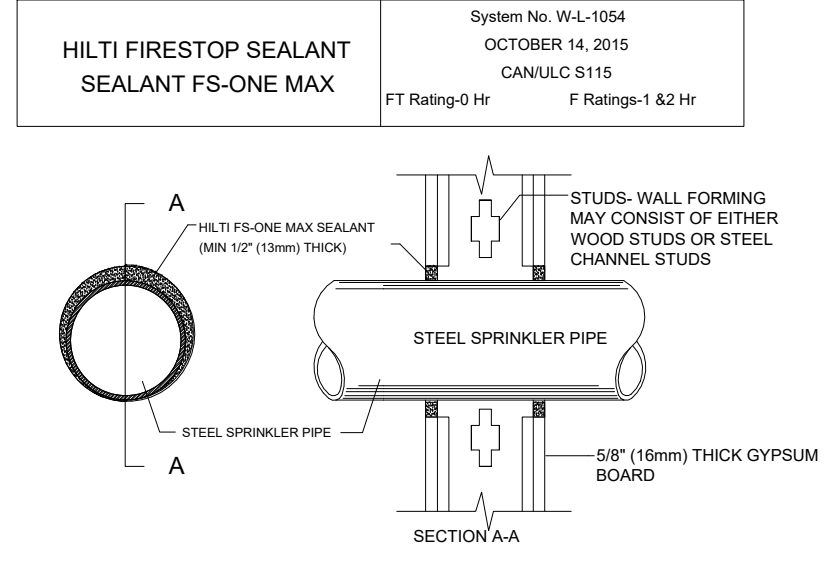

FIRESTOP DETAILS

SCALE: N.T.S.

DISTANCE FROM SPRINKLER TO SIDE OF OBSTRUCTION, (A)	MAXIMUM ALLOWABLE DISTANCE OF DEFLECTOR ABOVE BOTTOM OF OBSTRUCTION, (N.) (B)
LESS THAN 1'-6"	0
1'-6" TO LESS THAN 3'-0"	1
3'-0" TO LESS THAN 4'-0"	3
4'-0" TO LESS THAN 4'-6"	5
4'-6" TO LESS THAN 6'-0"	7
6'-0" TO LESS THAN 6'-6"	9
6'-6" TO LESS THAN 7'-0"	11
7'-0" AND GREATER	14

NFPA 13 TABLE 8.10.6.1.2.
POSITIONING OF SPRINKLER TO AVOID OBSTRUCTION TO DISCHARGE. (RESIDENTIAL PENDENT SPRINKLERS)


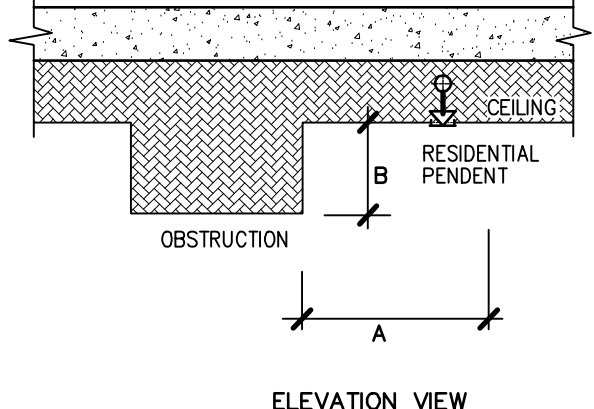


FIGURE 8.10.6.1.2(a) Positioning of Sprinkler to Avoid Obstructions to Discharge (Residential Pendent Sprinkler).

RESIDENTIAL PENDENT

DISTANCE FROM SIDEWALL SPRINKLER TO SIDE OF OBSTRUCTION, (A)	MAXIMUM ALLOWABLE DISTANCE OF DEFLECTOR ABOVE BOTTOM OF OBSTRUCTION, (N.) (B)
LESS THAN 1'-6"	0
1'-6" TO LESS THAN 3'-0"	1
3'-0" TO LESS THAN 4'-0"	3
4'-0" TO LESS THAN 4'-6"	5
4'-6" TO LESS THAN 6'-0"	7
6'-0" TO LESS THAN 6'-6"	9
6'-6" TO LESS THAN 7'-0"	11
7'-0" TO LESS THAN 7'-6"	14

NFPA 13 TABLE 8.10.7.1.4.
POSITIONING OF SPRINKLER TO AVOID OBSTRUCTION ALONG WALL. (RESIDENTIAL SIDEWALL SPRINKLERS)

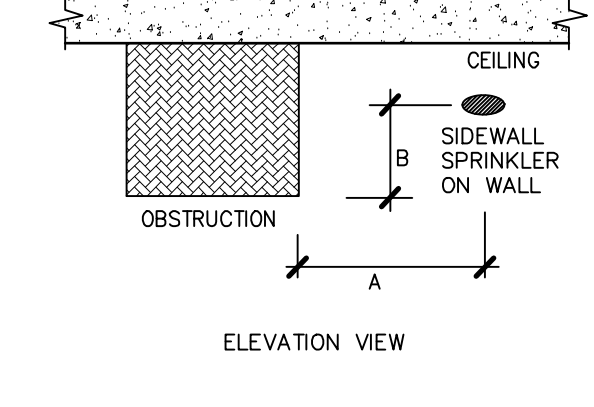

NFPA 13 FIGURE 8.10.7.1.4.
POSITIONING OF SPRINKLER TO AVOID OBSTRUCTION ALONG WALL. (RESIDENTIAL SIDEWALL SPRINKLERS)

GENERAL INSTALLATION
NOTES:

RESIDENTIAL SIDEWALL SPRINKLERS:

1. THE AREA OF RESIDENTIAL SIDEWALL COVERAGE NOT TO EXCEED 288 SQ.FT.
2. THE MIN. DISTANCE BETWEEN RESIDENTIAL SIDEWALL SPRINKLERS TO BE 8'-0".
3. THE MAX. DISTANCE BETWEEN RESIDENTIAL SIDEWALL SPRINKLERS TO BE 16'-0".
4. NO SPRINKLER IS TO BE LOCATED WITHIN THE MAXIMUM PROTECTION AREA OF ANOTHER SPRINKLER.

THERE IS NO WAY THAT SPRINKLERS WILL COLD SOLDER BASED ON THE LOCATION OF THE SPRINKLER DEFLECTORS. (UNLESS AT DIFFERENT ELEVATIONS).

5. SPRINKLERS TO BE LOCATED MIN. DISTANCE OF 4" FROM AN END WALL AND SHALL NOT EXCEED ONE-HALF OF THE ALLOWABLE DISTANCE PERMITTED BETWEEN SPRINKLERS.

6. MINIMUM DISTANCE BETWEEN SIDEWALL SPRINKLER AND LIGHT FIXTURES AND SIMILAR OBSTRUCTIONS TO BE 8 FEET. SEE FIGURE 8.10.7.1.3.

7. SPRINKLER DEFLECTOR TO BE LOCATED A MIN. OF 9" FROM CEILING.

8. WHERE SOFFITS USED FOR THE INSTALLATION OF SPRINKLERS EXCEED 8 INCHES IN WIDTH OR PROJECTION FROM WALL, ADDITIONAL SPRINKLERS SHALL BE INSTALLED BELOW THE SOFFIT.

9. OBSTRUCTIONS ON THE WALL OPPOSITE FROM THE SIDEWALL SPRINKLER SHALL BE PERMITTED WHERE OBSTRUCTION IS UP TO 2 FT DEEP AND 2 FT WIDE.

10. IN SITUATIONS WHERE BULKHEADS ARE MORE THAN 24 INCHES AND LESS THAN 30 INCHES IN WIDTH OR PROJECTION FROM WALL, SIDEWALL SPRINKLER TO BE LOCATED A MINIMUM OF 26" FROM THE NEAREST SIDE OF BULKHEAD (BASED ON A SPRINKLER DEFLECTOR LOCATED NO MORE THAN 4 INCHES ABOVE THE ELEVATION OF THE BOTTOM OF THE BULKHEAD).

11. ALL WIDTHS OF BULKHEADS HAVE BEEN MEASURED IN AUTOCAD FROM ARCHITECTURAL DRAWINGS. PENDANT SPRINKLERS HAVE BEEN ADDED FOR ALL BULKHEADS WITH WIDTHS IN EXCESS OF 24" WHERE SIDEWALL SPRINKLER IS FACING THE BULKHEAD (IN FRONT OF) AND 30" WHEN SIDEWALL SPRINKLER IS BESIDE THE BULKHEAD (UNLESS SIDEWALL SPRINKLER IS LOCATED FAR ENOUGH AWAY FROM FACE OF BULKHEAD SO THAT WATER SPRAY IS NOT OBSTRUCTED).

12. SPRINKLER TO BE LOCATED AS PER OBSTRUCTION RULES TO PREVENT THE WATER PATTERN FROM FULLY DEVELOPING.

13. SEE OBSTRUCTION RULES ON SP-1.

RESIDENTIAL PENDENT SPRINKLERS:

1. THE AREA OF RESIDENTIAL PENDENT COVERAGE NOT TO EXCEED 288 SQ.FT.

2. THE MIN. DISTANCE BETWEEN RESIDENTIAL PENDENT SPRINKLERS TO BE 8'-0".

3. THE MAX. DISTANCE BETWEEN RESIDENTIAL PENDENT SPRINKLERS TO BE 20'-0".

4. NO SPRINKLER IS TO BE LOCATED WITHIN THE MAXIMUM PROTECTION AREA OF ANOTHER SPRINKLER.

THERE IS NO WAY THAT SPRINKLERS WILL COLD SOLDER BASED ON THE LOCATION OF THE SPRINKLER DEFLECTORS. (UNLESS AT DIFFERENT ELEVATIONS).

5. SPRINKLERS TO BE LOCATED MIN. DISTANCE OF 4" FROM AN END WALL AND SHALL NOT EXCEED 10 FT. FROM AN END WALL.

6. SPRINKLER DEFLECTOR TO BE LOCATED 1" TO 4" FROM THE CEILING.

7. SPRINKLER TO BE LOCATED AS PER OBSTRUCTION RULES TO PREVENT THE WATER PATTERN FROM FULLY DEVELOPING. (SEE DETAIL ON DRAWINGS).

8. SEE OBSTRUCTION RULES ON SP-1.

X	XX	XXXXXXXXXXXX
NO	DATE	DESCRIPTION
ISSUED/REVISION RECORD		

PROJECT

PROPOSED MIXED-USED DEVELOPMENT

ADDRESS:

775-783 Vaughan Rd & 670-680

Northcliffe Blvd, York, ON

DRAWING TITLE

NFPA RULES AND GENERAL




DETAILS 1




50 Casimir Court, Concord, ON
L4K 4J5
(416)850-9477

PROJECT	TRUE NORTH
22-0007	PROJECT
SK	RJ
BY	REVIEWED

SP-02

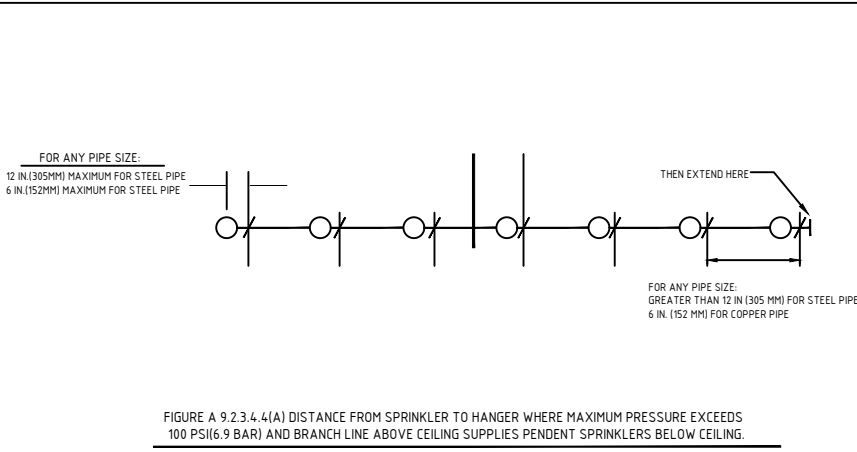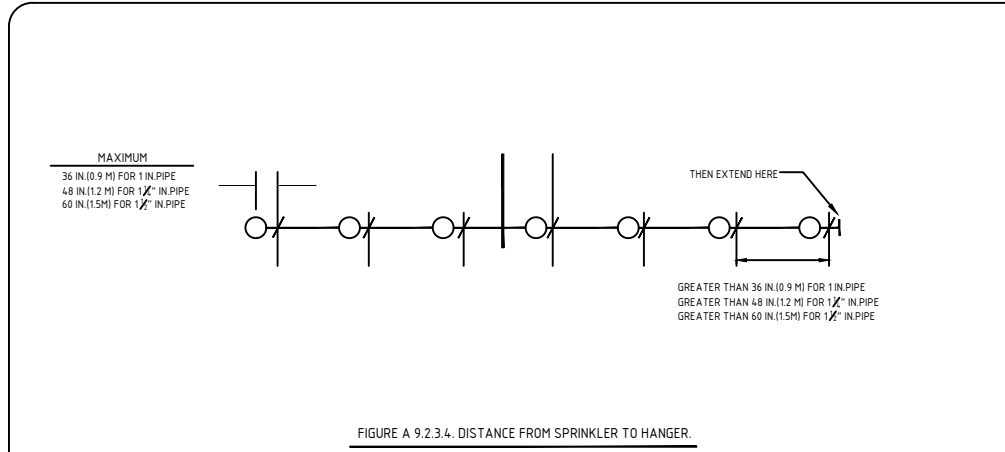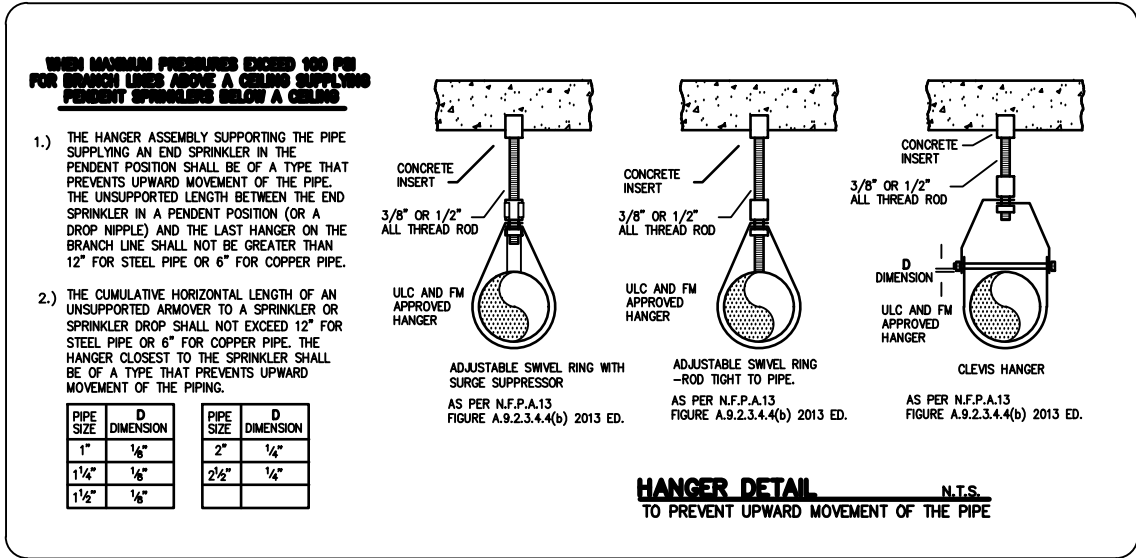


Heat Source	Minimum Distance from Edge of Source to Ordinary-Temperature Sprinkler (in.)	Minimum Distance from Edge of Source to Intermediate-Temperature Sprinkler (in.)
Side of open or recessed fireplace	36	12
Front of recessed fireplace	60	36
Kitchen range	18	9
Uninsulated heat ducts	18	9
Uninsulated hot water pipes	12	6
Side of ceiling or wall mounted hot air diffusers	24	12
Front of wall mounted hot air diffusers	36	18
Hot water heater or furnace	6	3
Light fixture 0W-250W	6	3
Light fixture 250W-499W	12	6

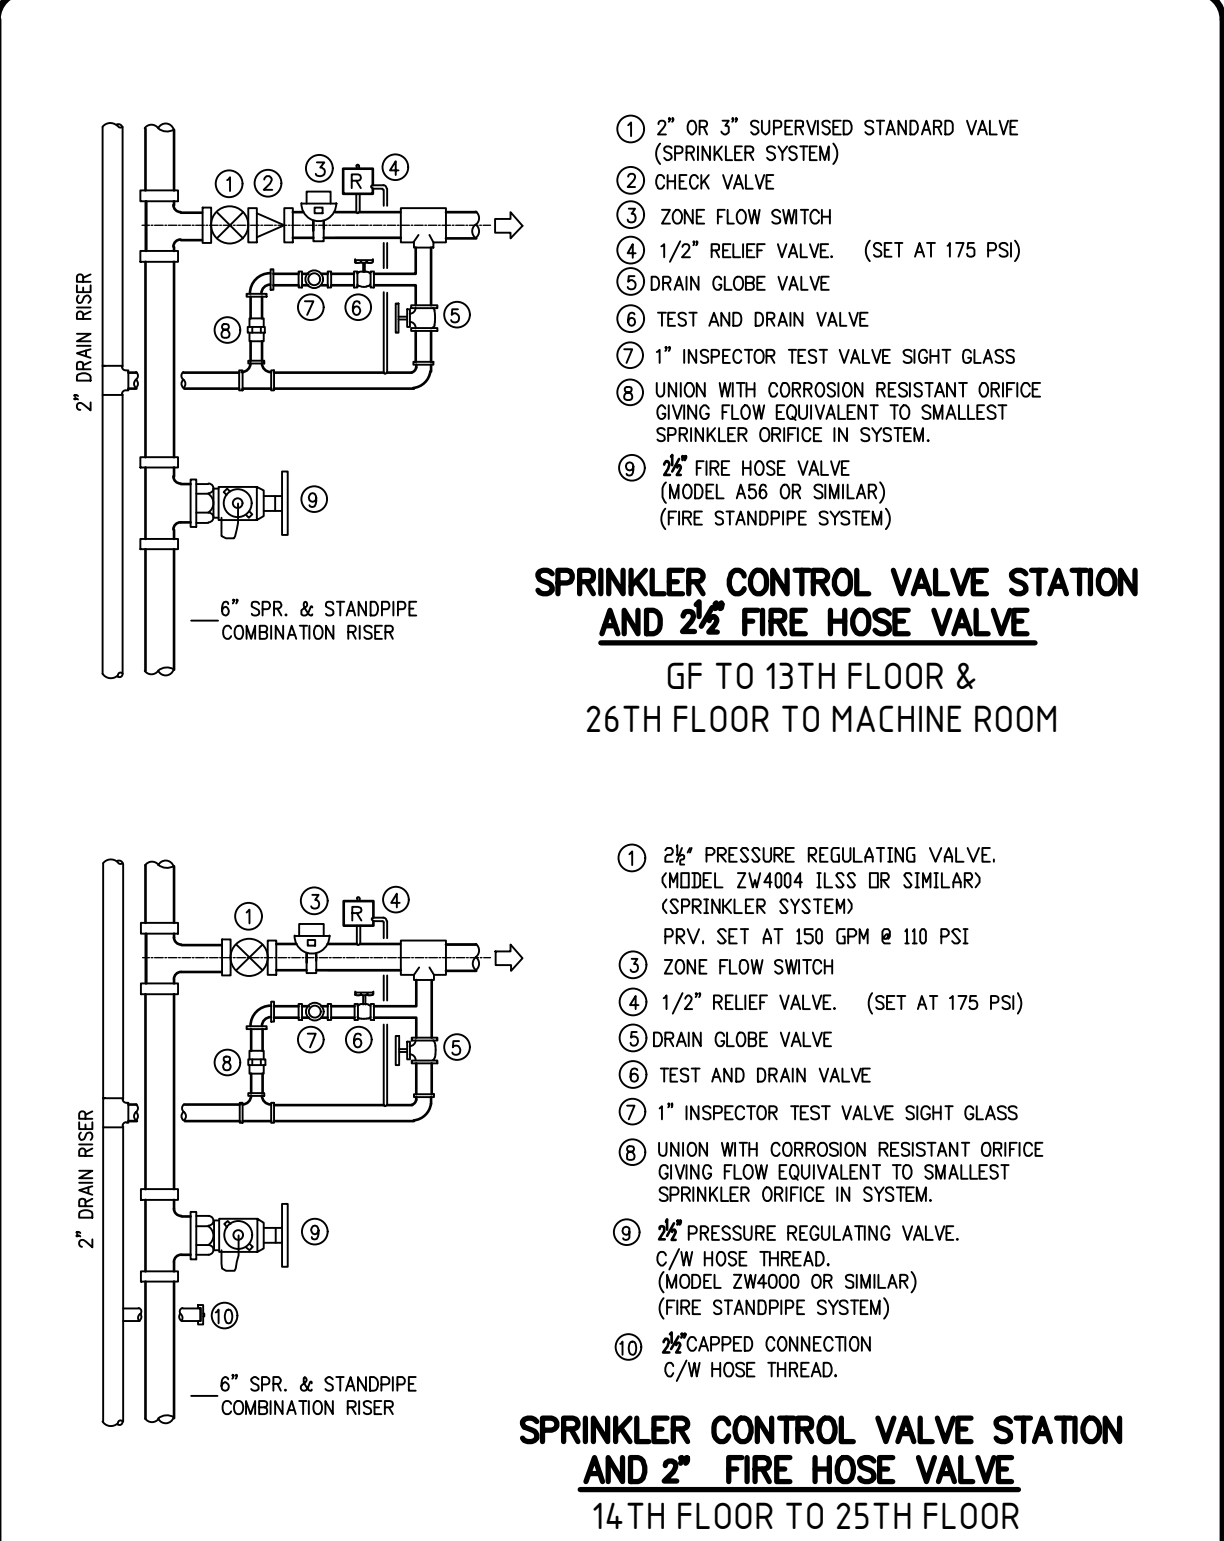

X	XX	XXXXXXXXXXXX
NO	DATE	DESCRIPTION
ISSUED/REVISION RECORD		

	NOMINAL PIPE SIZE (IN.)											
	¾	1	1¼	1½	2	2½	3	3½	4	5	6	8
STEEL PIPE EXCEPT THREADED LIGHT WALL	N/A	12-0	12-0	15-0	15-0	15-0	15-0	15-0	15-0	15-0	15-0	15-0
THREADED LIGHTWALL STEEL PIPE	N/A	12-0	12-0	12-0	12-0	12-0	12-0	N/A	N/A	N/A	N/A	N/A
COPPER TUBE	8-0	8-0	10-0	10-0	12-0	12-0	12-0	15-0	15-0	15-0	15-0	15-0
CPVC	5-6	6-0	6-6	7-0	8-0	9-0	10-0	N/A	N/A	N/A	N/A	N/A
DUCTILE IRON PIPE	N/A	N/A	N/A	N/A	N/A	N/A	15-0	N/A	15-0	N/A	15-0	15-0

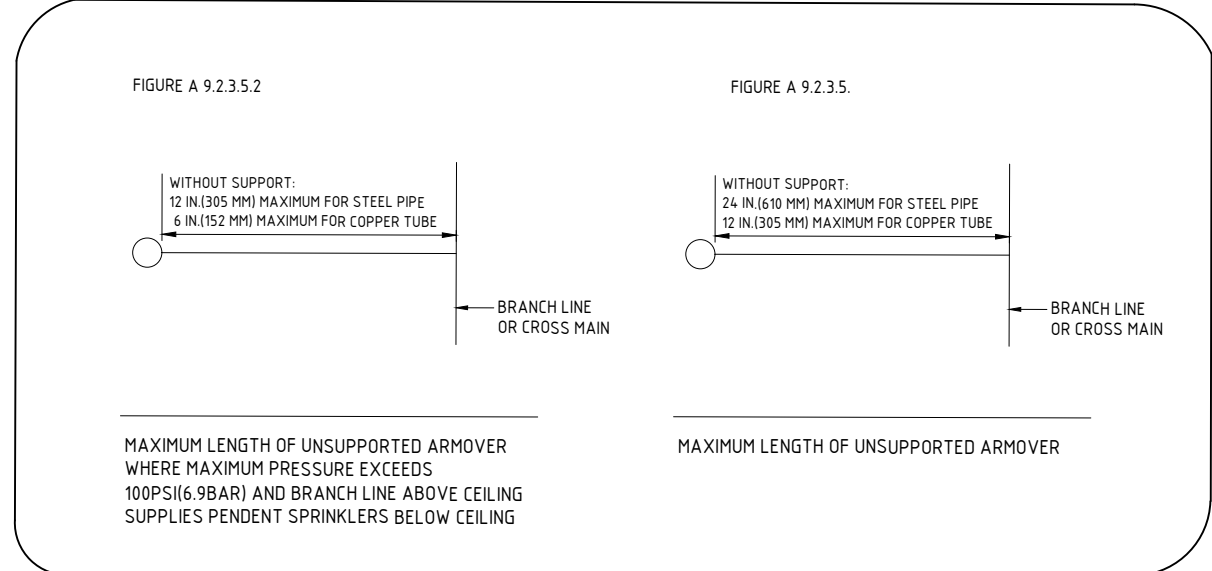

O.B.C. SECTION 3.2.5.14 COMBUSTIBLE SPRINKLER PIPING

(1) COMBUSTIBLE SPRINKLER PIPING SHALL BE USED ONLY FOR WET SYSTEMS IN RESIDENTIAL OCCUPANCIES AND OTHER LIGHT HAZARD OCCUPANCIES. (SEE APPENDIX A.)





(2) COMBUSTIBLE SPRINKLER PIPING SHALL MEET THE REQUIREMENTS OF 14C000-100P-AL TUBE FOR THE INSTALLATION OF COMBUSTIBLE PIPING FOR SPRINKLER SYSTEMS.

(3) COMBUSTIBLE SPRINKLER PIPING SHALL BE SEPARATED FROM THE AREA SERVED BY THE SPRINKLER SYSTEM AND FROM ANY OTHER FIRE COMPARTMENT BY CEILING, WALLS, OR PARTS CONSIDERED AS A MINIMUM:







(A) LATH AND PLASTER.

(B) CEMENT BOARD NOT LESS THAN 0.5 IN. (12.7 MM) THICK OR

(C) 1/2\"/>

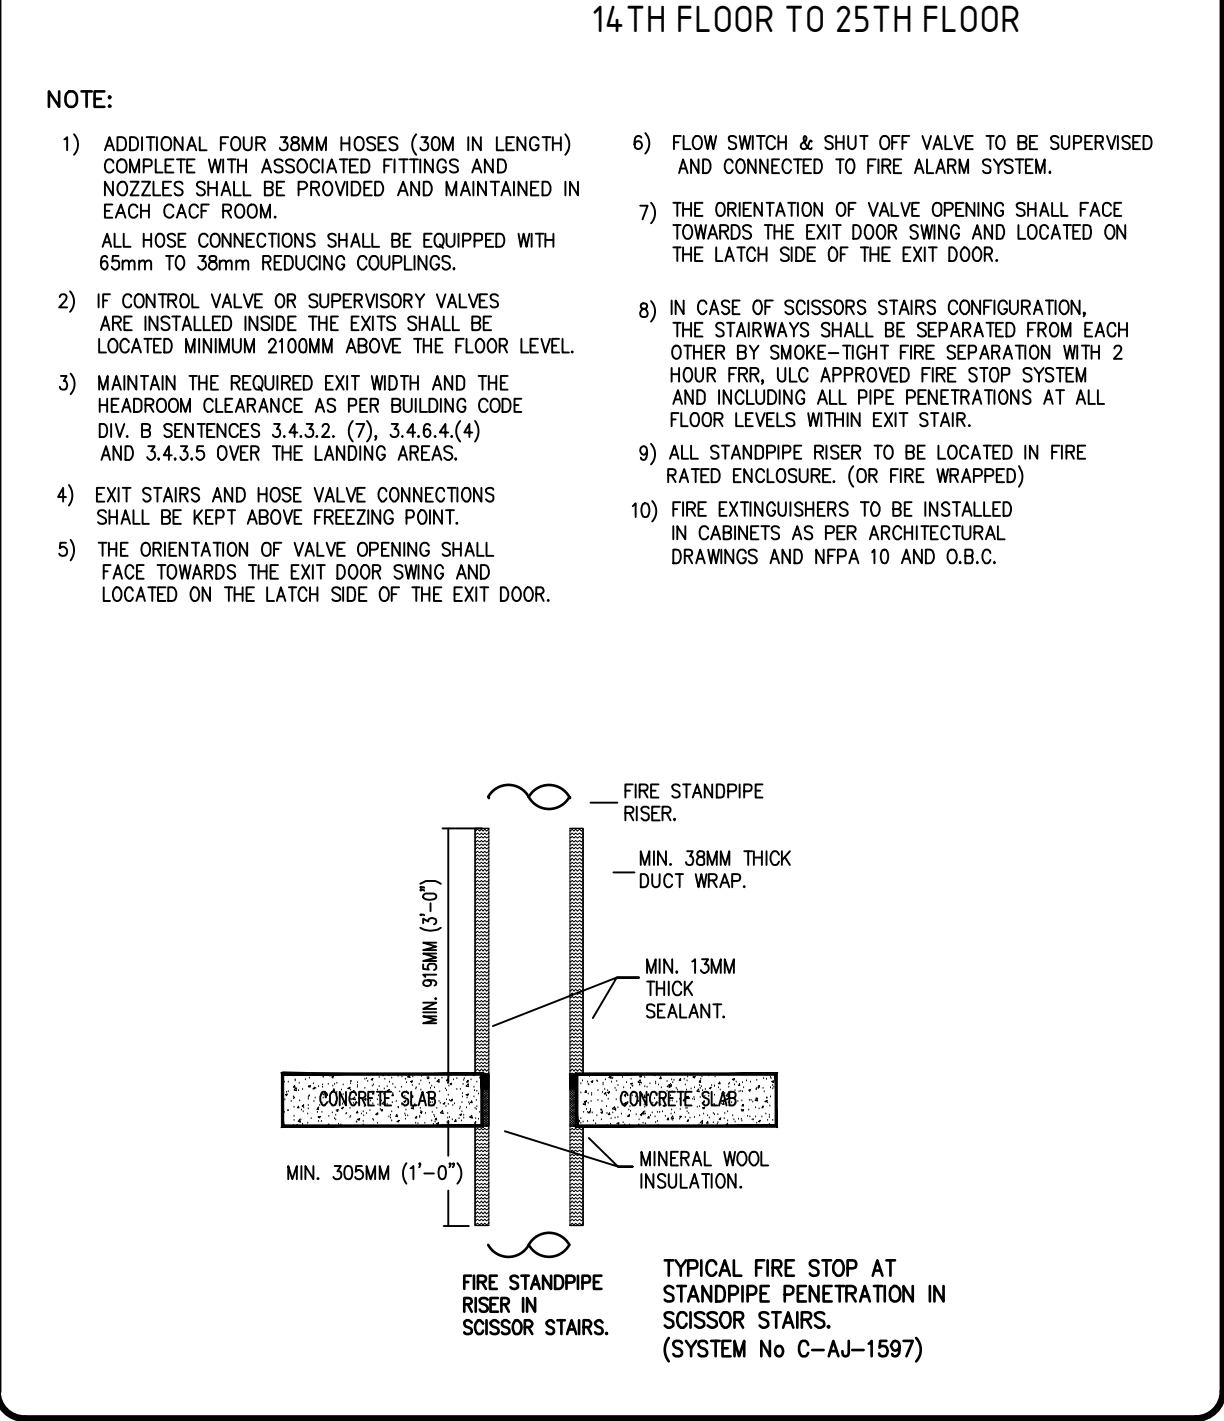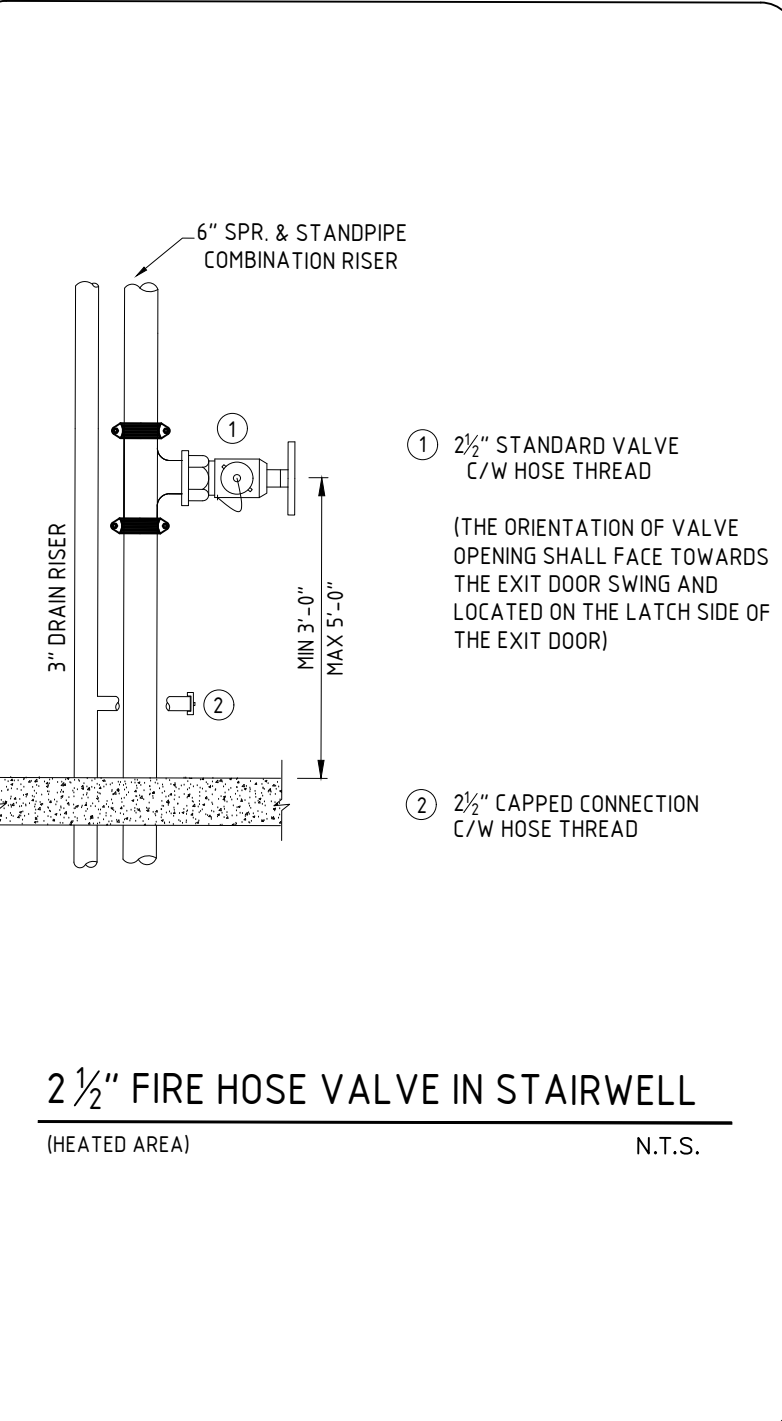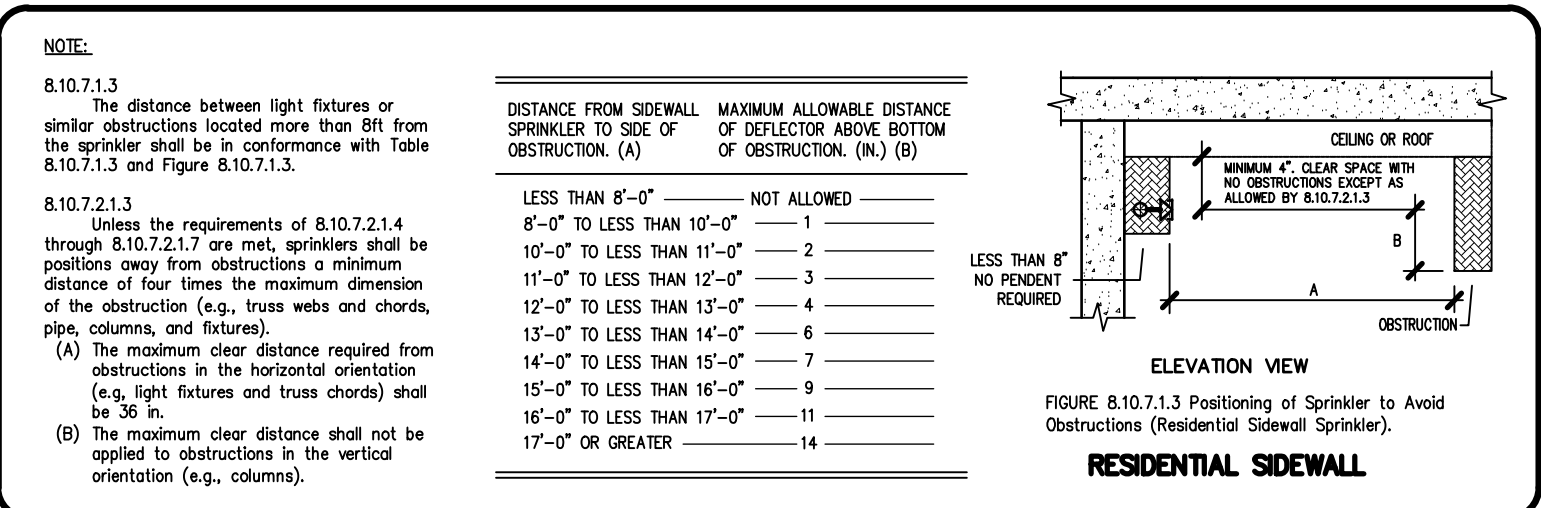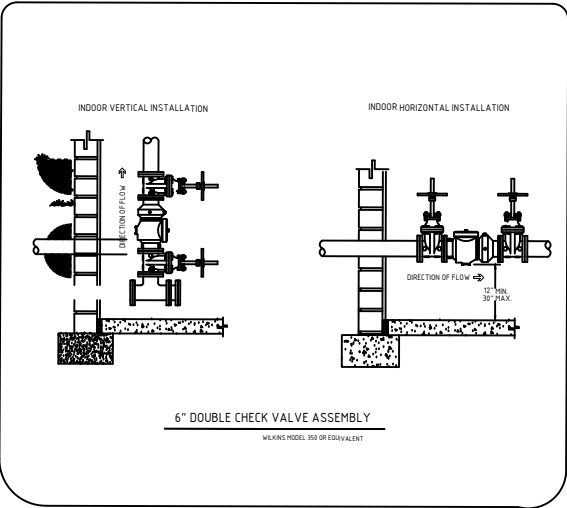

PROJECT	
PROPOSED MIXED-USED DEVELOPMENT	
ADDRESS: 775-783 Vaughan Rd & 670-680 Northcliffe Blvd, York, ON	
DRAWING TITLE	
NFPA RULES AND GENERAL DETAILS 2	

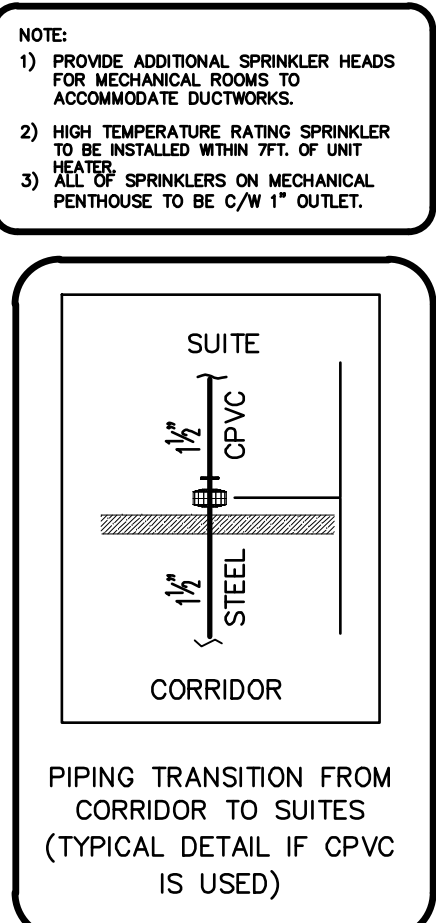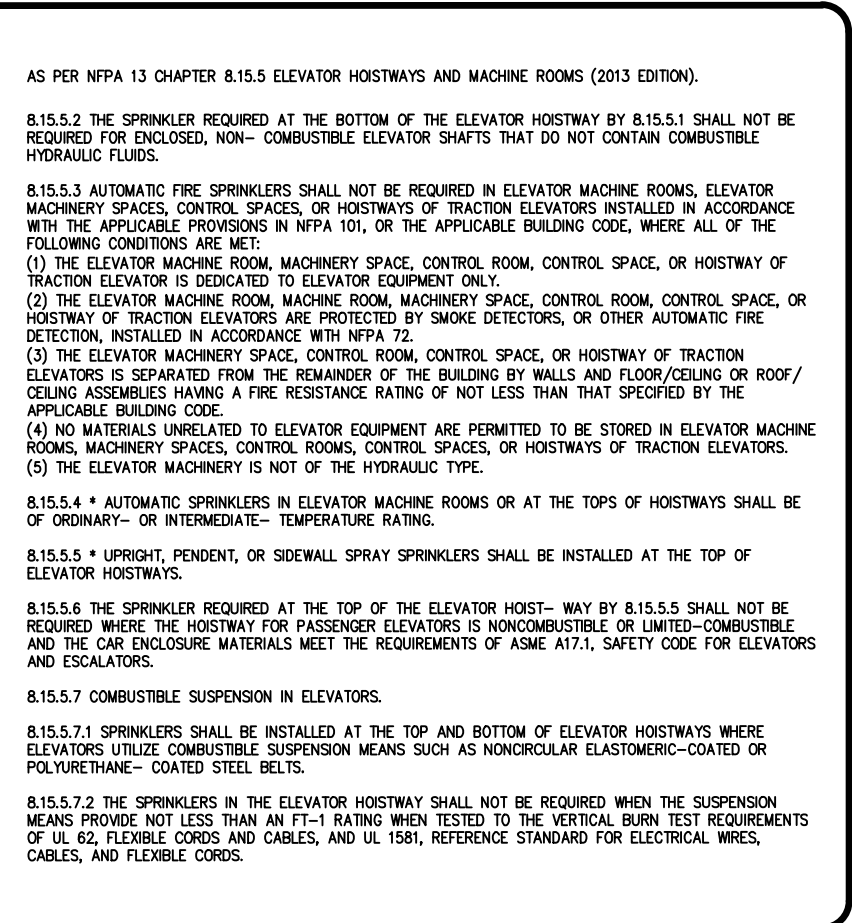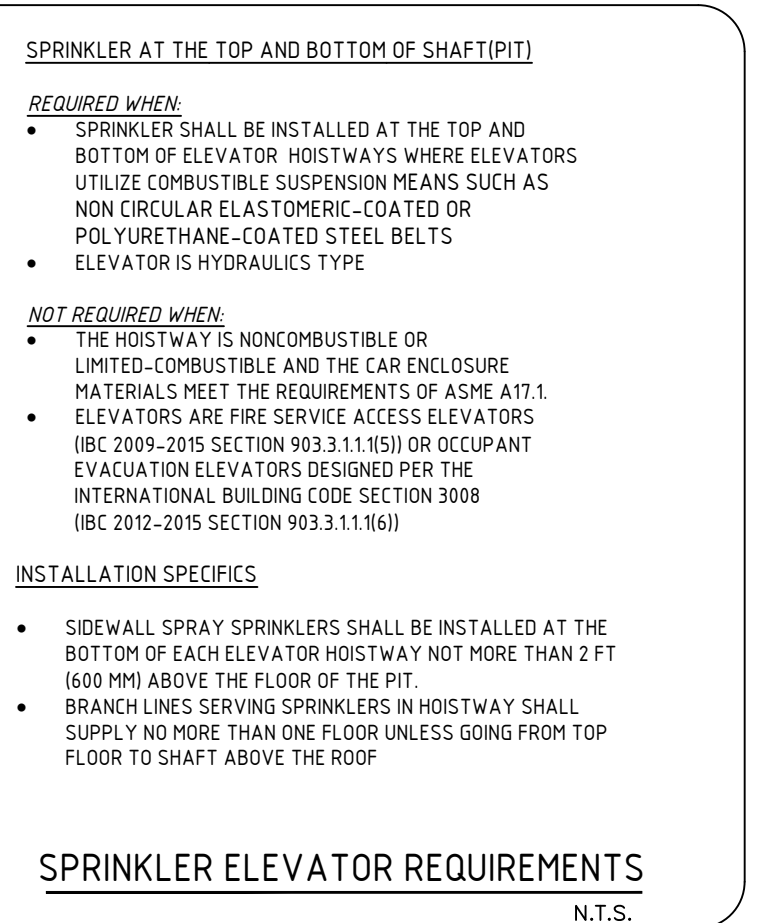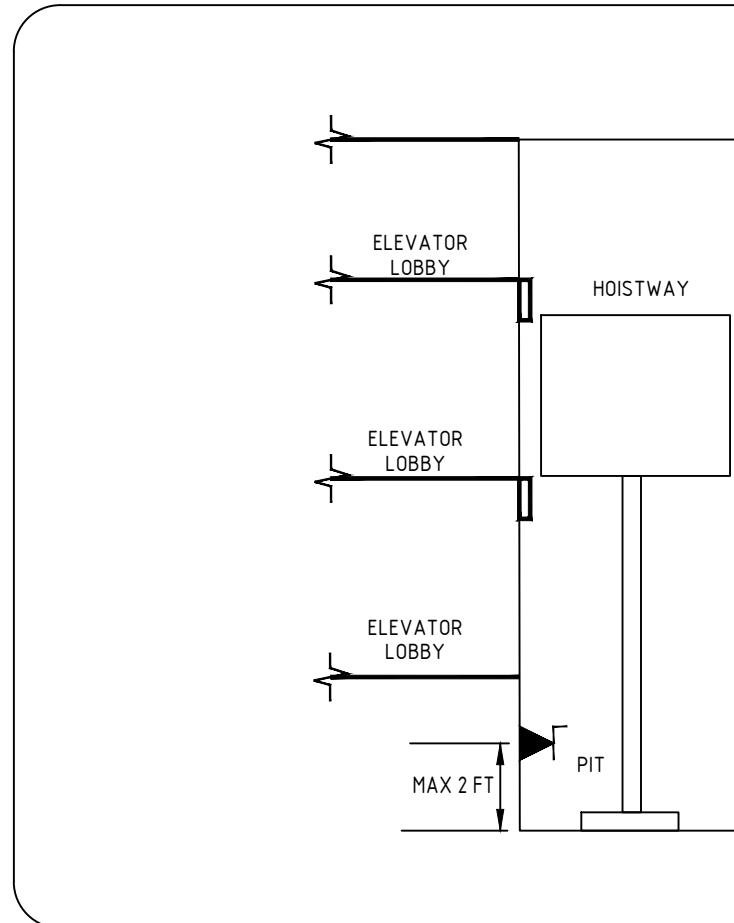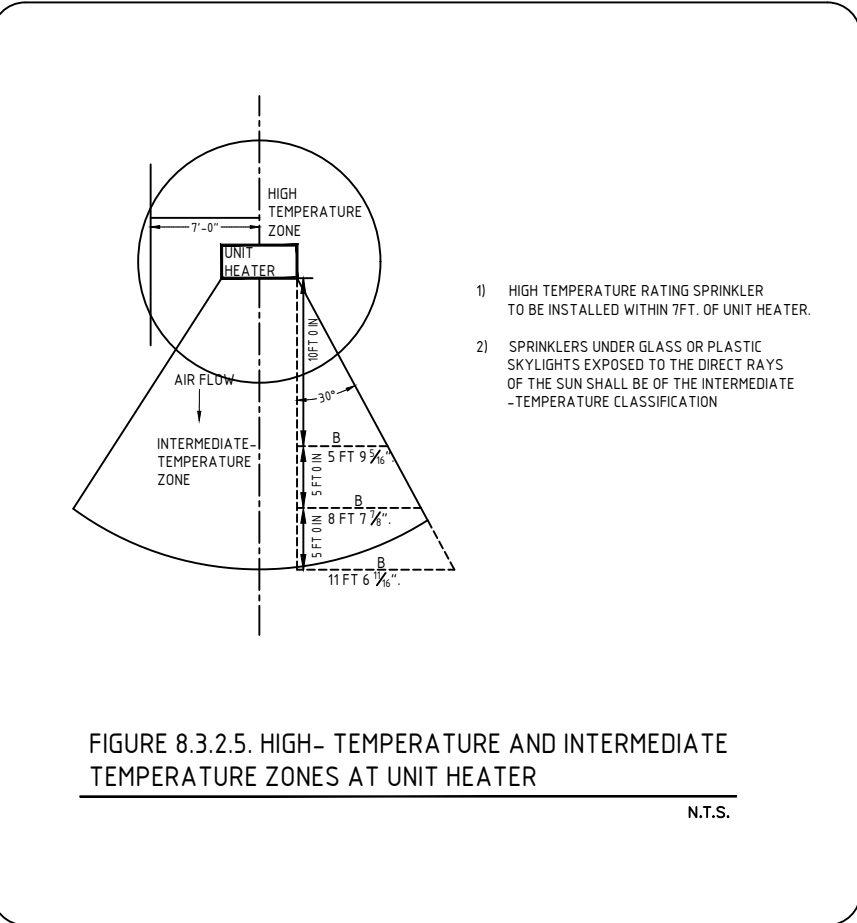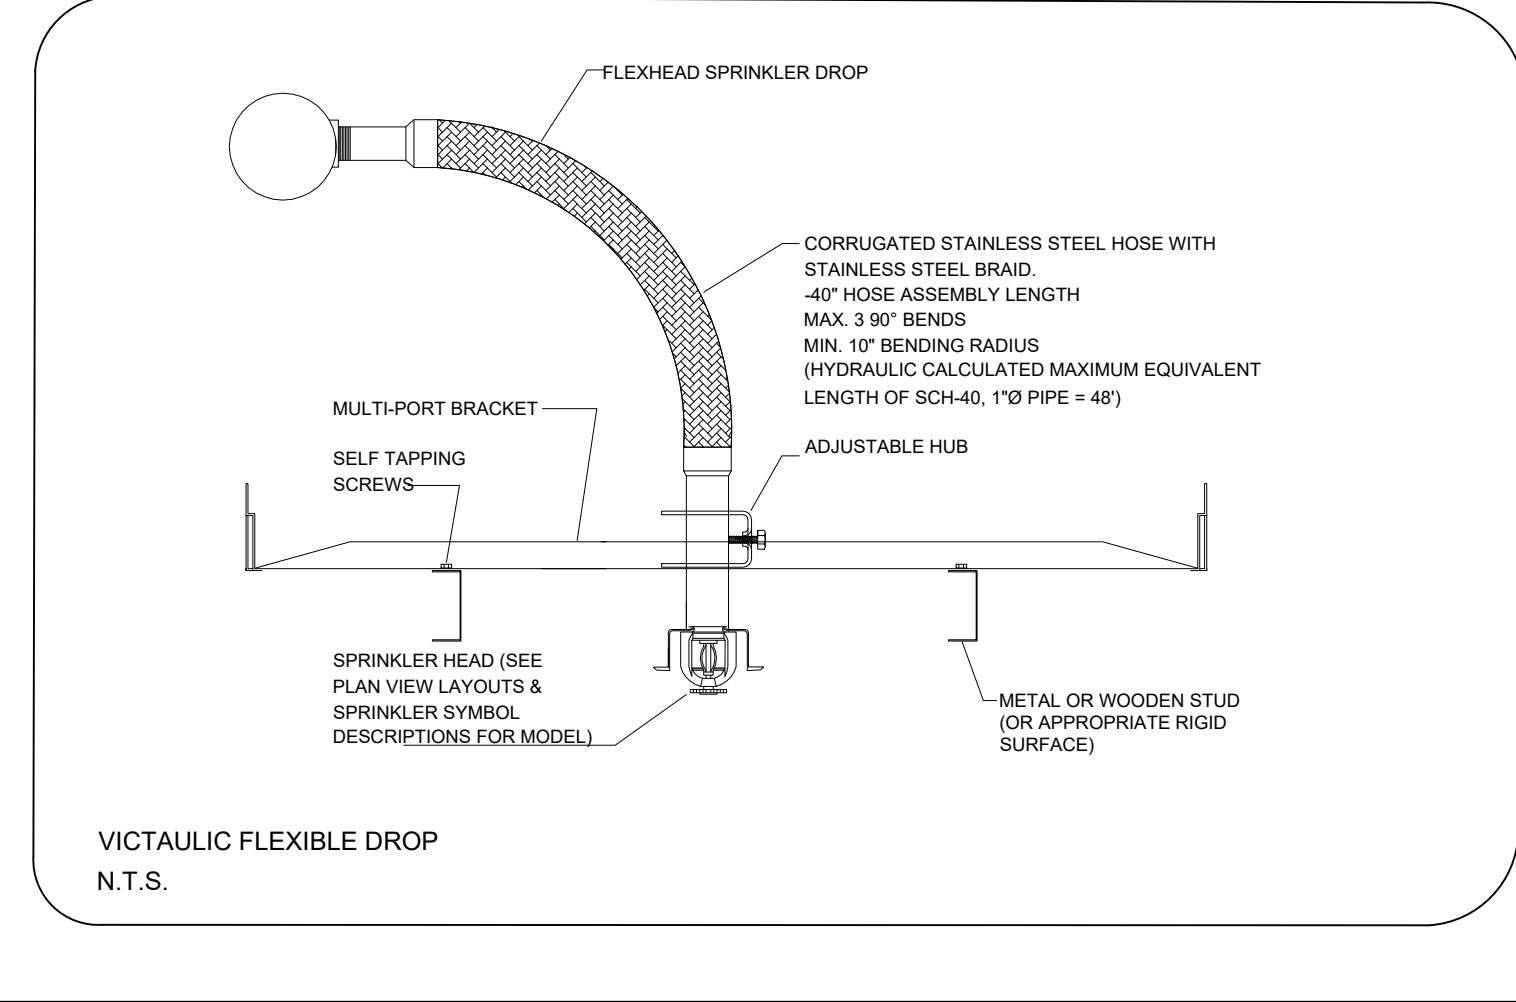

PROJECT	
PROPOSED MIXED-USED DEVELOPMENT	
ADDRESS: 775-783 Vaughan Rd & 670-680 Northcliffe Blvd, York, ON	
DRAWING TITLE	
NFPA RULES AND GENERAL DETAILS 2	

ELECTRIC FIRE PUMP SPECIFICATIONS

- 1.0 ALL EQUIPMENT SUPPLIED UNDER THIS SPECIFICATION SHALL BE NEW AND SHALL BE U.L.C.-LISTED AND/OR FM-APPROVED FOR FIRE PROTECTION SERVICE AND INSTALLED AND USED AS INTENDED BY THE LISTING. ALL PIPING, MATERIALS, VALVES, AND OTHER EQUIPMENT DOWNSTREAM OF THE FIRE PUMP SHALL BE RATED WITH A MINIMUM WORKING PRESSURE OF 200 PSI.
- 2.0 THE FOLLOWING ITEMS SHALL BE SUPPLIED BY THE FIRE PROTECTION CONTRACTOR.
 - a.) FIRE PUMPS (LEAD & STANDBY)
 - 750 USGPM @ 225 PSI
 - 200 HP / 575 VOLTS / 3 PHASE (ARMSTRONG OR EQUAL)
 - b.) JOCKEY PUMP
 - 10 USGPM @ 230 PSI
 - 3 HP / 575 VOLTS / 3 PHASE (ARMSTRONG OR EQUAL)
 - c.) ASSOCIATED EQUIPMENT-
 - CHECK VALVE, BUTTERFLY VALVE, DISCHARGE TEE, D54Y GATE VALVE, NON CORROSIVE SENSING LINE,
 - 28" DIAL TYPE SUCTION GAUGE, 38" DIAL TYPE DISCHARGE GAUGE, CORROSION RELIEF VALVE.
 - d.) LEAD-STANDBY DUEL FIRE PUMP CONTROLLER.

NOTE: FOR BUILDINGS OVER 8M, CONTROLLER TO BE LEAD-STANDBY DUAL FIRE PUMP CONTROLLER. FULL SERVICE REDUCED VOLTAGE AUTOTRANSFORMER C/W TRANSFER SWITCH.
- 3.0 THE AUTOMATIC TRANSFER SWITCH COMBINATION SWITCH BE APPROVED BY U.L.C. THE AUTOMATIC TRANSFER SWITCH AND THE FIRE PUMP CONTROLLER SHALL EACH BE MOUNTED IN SEPARATE ENCLOSURES, MECHANICALLY ATTACHED TO FORM ONE UNIT AND PROVIDE FOR PROTECTED INTERLOCK WIRING.

- 4.0 THE JOCKEY PUMP SHALL BE CONTROLLED BY AN AUTOMATIC JOCKEY PUMP CONTROLLER WITH FULL VOLTAGE STARTER. UPON SYSTEM PRESSURE DROP THE JOCKEY PUMP WILL START UP AUTOMATICALLY AND PRESSURIZE THE SYSTEM TO THE SET PRESSURE AND THEN STOP. IF THE SYSTEM PRESSURE CONTINUES TO DECREASE BELOW THE RANGE OF THE JOCKEY PUMP, THE MAIN FIRE PUMP WILL START AUTOMATICALLY.
- 5.0 THE FIRE PUMP SHALL BE HYDROSTATICALLY TESTED TO TWICE THE MAXIMUM PRESSURE DEVELOPED AT SHUT-OFF BUT NOT LESS THAN 250 PSI. TESTS WILL MEET OR EXCEED NFPA 20 STANDARDS.
- 6.0 THE FIRE PUMP SHALL BE SUBJECTED TO A PERFORMANCE TEST AT RATED SPEED.
 - 1. PUMP RUNNING
 - 2. LOSS OF PHASE
 - 3. CONTROLLER CONNECTED TO ALTERNATE POWER SOURCE.
 - 4. PHASE REVERSAL.
 - 5. ALTERNATE SOURCE ISOLATING SWITCH OR CIRCUIT BREAKER
 - 6. CONTROLLER OR SYSTEM TROUBLE.
 - 7. MANUAL MODE/OFF MODE
- 7.0 THE PUMP SHALL FURNISH NOT LESS THAN 1500 GPM RATED CAPACITY AT A PRESSURE NOT LESS THAN 65% OF RATED HEAD. THE SHUT-OFF TOTAL HEAD OF THE PUMP SHALL NOT EXCEED 140% OF RATED TOTAL HEAD. CERTIFIED CURVES SHALL BE SUPPLIED TO THE PURCHASER SHOWING THE EFFICIENCY, BRAKE-HORSEPOWER AND TOTAL HEAD DEVELOPED AT SHUT-OFF AT RATED CAPACITY AND AT 150% OF RATED CAPACITY.
- 8.0 THE FOLLOWING IS TO BE MONITORED TO FIRE ALARM SYSTEM FROM FIRE PUMP CONTROL PANEL:
 1. PUMP RUNNING
 2. LOSS OF PHASE
 3. CONTROLLER CONNECTED TO ALTERNATE POWER SOURCE.
 4. PHASE REVERSAL.
 5. ALTERNATE SOURCE ISOLATING SWITCH OR CIRCUIT BREAKER
 6. CONTROLLER OR SYSTEM TROUBLE.
 7. MANUAL MODE/OFF MODE

- 9.0 THESE DRAWINGS ARE FOR PERMIT ONLY. CONTRACTOR MUST SUPPLY SPRINKLER SHOP DRAWINGS SUITABLE FOR INSTALLATION AND RESUBMIT DRAWINGS AND CALCULATIONS TO CITY FOR APPROVAL (IF APPLICABLE).
- 10.0 CONTRACTOR TO SUPPLY AND INSTALL A COMPLETE AND FULLY OPERATIONAL AUTOMATIC SPRINKLER & STANDPIPE SYSTEM AS SHOWN ON THE DRAWINGS AND AS INDICATED IN THE SPECIFICATIONS AND CONFORMING TO N.F.P.A. REQUIREMENTS, N.B.C. REQUIREMENTS AND THE REQUIREMENTS OF THE LOCAL AUTHORITIES.
- 11.0 UPON COMPLETION OF THE INSTALLATION, THE CONTRACTOR SHALL TEST THE SYSTEM AND SUBMIT TO THE ENGINEER COMPLETED CONTRACTORS TEST CERTIFICATES STATING THAT THE SYSTEMS HAVE BEEN INSTALLED, TESTED AND APPROVED BY THE AUTHORITIES HAVING JURISDICTION IN ACCORDANCE WITH N.F.P.A.#13, LATEST OR APPLICABLE EDITION.
- 12.0 ALL WORK SHALL BE DONE IN ACCORDANCE WITH ALL CODES, STANDARDS BY-LAWS AND AUTHORITIES HAVING JURISDICTION.
- 13.0 SYSTEMS TO BE INSTALLED AS PER N.F.P.A. STANDARDS, AND LOCAL AUTHORITIES.
- 14.0 SPRINKLER CONTRACTOR TO CO-ORDINATE INSTALLATION WITH EXISTING SITE CONDITIONS AND ACCEPT RESPONSIBILITY FOR AND COST OF MAKING ADJUSTMENTS TO PIPING TO AVOID INTERFERENCE WITH MECHANICAL, ELECTRICAL AND OTHER BUILDING COMPONENTS.
- 15.0 SPRINKLER CONTRACTOR TO INCLUDE FOR OFFSETS IN SPRINKLER PIPING AND MUST SUPPLY AND INSTALL TRAPRAZE HANGERS WHERE REQUIRED. HANGERS FOR MAINS TO BE INSTALLED AT PANEL POINTS OF JOISTS.
- 16.0 ALL SPRINKLER VALVES TO BE SUPERVISED, AND U.L.C. LISTED.
- 17.0 SPRINKLER CONTRACTOR TO ALLOW FOR ADDITIONAL PRESSURE SWITCHES WHERE REQUIRED FOR ALARM SYSTEM.
- 18.0 CONTRACTOR TO ALLOW IN PRICE FOR SUFFICIENT PIPE AND FITTINGS TO INSTALL SPRINKLERS WITHIN A 5 FT. RADIUS OF THE LOCATION SHOWN ON DRAWINGS.
- 19.0 BLANK

GENERAL SPECIFICATIONS

- 20.0 ALL MATERIALS USED IN THE INSTALLATION OF THE SPRINKLER SYSTEM SHALL BE CANADIAN MADE, UNLESS SPECIFICALLY APPROVED IN WRITING PRIOR TO INSTALLATION BY THE ARCHITECTS AND/OR ENGINEERS RESPONSIBLE FOR THE SYSTEM DESIGN.
- 21.0 CONTRACTOR MUST CHECK AND VERIFY ALL DIMENSIONS AND CONDITIONS ON THE JOB AND REPORT DISCREPANCIES TO THE ENGINEER BEFORE PROCEEDING WITH THE WORK.
- 22.0 PROVIDE FLOW ALARM DEVICES, SUPERVISORY SWITCHES AND PRESSURE SWITCHES WHERE SHOWN ON DRAWINGS. WIRING TO ANNUNCIATOR SHALL BE BY ELECTRICAL CONTRACTOR. PROVIDE NECESSARY SIGNS WHERE REQUIRED BY THE LOCAL FIRE AUTHORITIES.
- 23.0 PROVIDE SHOP DRAWINGS FOR THE FOLLOWING:
 - A) - SPRINKLER HEADS
 - B) - ALARM VALVE AND TRIM
 - C) - SUPERVISORY DEVICES
 - D) - HANGERS
 - E) - FLOW SWITCHES
- 24.0 A COPY OF N.F.P.A. STANDARD # 25 IS TO BE PROVIDED AND LEFT IN A VISIBLE LOCATION IN THE SPRINKLER ROOM.
- 25.0 DIMENSIONS AND/OR MEASUREMENTS INDICATED ON THE DRAWINGS ARE TO BE VERIFIED AT SITE AND ANY MAJOR DISCREPANCIES TO BE REPORTED PRIOR TO FABRICATION AND INSTALLATION. (IF APPLICABLE).
- 26.0 EXACT LOCATION AND ELEVATION OF MAINS TO BE DETERMINED BY CONTRACTOR TO SUIT SITE CONDITIONS.
- 27.0 CONTRACTOR TO CO-ORDINATE LOCATION OF SPRINKLERS WITH RESPECT TO SURFACE MOUNTED LIGHT FIXTURES AND MAINTAIN MINIMUM CLEARANCE AS REQUIRED BY NFPA 13 TO AVOID ANY OBSTRUCTION TO SPRAY PATTERN OF SPRINKLERS.
- 28.0 MINIMUM WALL THICKNESS OF SPRINKLER PIPING TO BE EQUIVALENT TO SCHEDULE 10S.
- 29.0 CONTRACTOR TO PROVIDE HYDRAULIC PLATES. (WE WILL PROVIDE INFO ONLY.)
- 30.0 SPRINKLERS IN LIGHT HAZARD OCCUPANCIES (e.g. LOBBY ETC.) TO BE QUICK RESPONSE TYPE.
- 31.0 CONTRACTOR TO PROVIDE NECESSARY HANGERS AND ASSEMBLY TO COMPLY WITH THE FOLLOWING:
 - A) UNSUPPORTED LENGTH BETWEEN END SPRINKLER AND LAST HANGER SHALL NOT EXCEED 36 INCHES FOR 1" DIA. PIPE, 48" FOR 1 1/2" DIA. PIPE AND 60" FOR 1 3/4" DIA. PIPE OR LARGER. NOTE: WHEN PRESSURE EXCEEDS 100 PSI, REFER TO NFPA STANDARD # 13.
 - B) THE LENGTH OF AN UNSUPPORTED ARM-OVER TO A SPRINKLER SHALL NOT EXCEED 24".

NOTE: WHEN PRESSURE EXCEEDS 100 PSI, REFER TO NFPA STANDARD # 13.
- 32.0 CONTRACTOR TO PROVIDE ADEQUATE BRANS AS REQUIRED BY N.F.P.#13 AND DISCHARGE TO A LOCATION TO SUIT SITE CONDITIONS.
- 33.0 ELECTRIC FIRE PUMP AND JOCKEY PUMP TO BE INSTALLED IN ACCORDANCE WITH NFPA STANDARD #20 AND N.B.C. AND BE IN COMPLIANCE WITH THE REQUIREMENTS OF LOCAL AUTHORITIES.
- 34.0 ENGINEER TO WITNESS FIRE PUMP & STANDPIPE TESTS.
- 35.0 ALL PIPING IN CORRIDOR (INCLUDING FEEDS INTO SUITES) MUST BE STEEL PIPING.
- 36.0 CONTRACTOR TO INCLUDE FOR AN ADDITIONAL 150 SPRINKLERS FOR BELOW OBSTRUCTIONS ETC.
- 37.0 CONTRACTOR TO INCLUDE FOR 3 BRUM DRIPS PER DRY SYSTEM.
- 38.0 ELECTRICAL CONTRACTOR IS RESPONSIBLE TO SUPPLY AND INSTALL ELECTRICAL HEAT TRACING WHERE SHOWN ON DRAWINGS AND WHERE REQUIRED TO PREVENT WATER IN PIPES FROM FREEZING.
- 39.0 FIRE ALARM CONTRACTOR IS RESPONSIBLE TO CONNECT HEAT TRACING WIRE TO FIRE ALARM SYSTEM.
- 40.0 MECHANICAL CONTRACTOR IS RESPONSIBLE TO SUPPLY AND INSTALL ALL THE NECESSARY INSULATION WHERE SHOWN ON DRAWINGS AND WHERE REQUIRED TO PREVENT WATER IN PIPES FROM FREEZING.
- 41.0 MECHANICAL CONTRACTOR IS RESPONSIBLE TO SUPPLY AND INSTALL EXTINGUISHERS WHERE SHOWN ON DRAWINGS AND WHERE REQUIRED.
- 42.0 MECHANICAL CONTRACTOR IS RESPONSIBLE TO SUPPLY AND INSTALL FIRE WHIP WHERE FIRE RATED ENCLOSURE (AS SHOWN ON DRAWINGS) IS NOT FEASIBLE.

SUPERVISED VALVE SCHEDULE-1		
VALVE No.	SERVICE	LOCATION
SV-1	DOUBLE CHECK DETECTOR VALVE INLET	FIRE PUMP ROOM
SV-2	DOUBLE CHECK DETECTOR VALVE OUTLET	FIRE PUMP ROOM
SV-3	DOUBLE CHECK DETECTOR VALVE INLET	FIRE PUMP ROOM
SV-4	DOUBLE CHECK DETECTOR VALVE OUTLET	FIRE PUMP ROOM
SV-5	FIRE MAIN ISOLATION	FIRE PUMP ROOM
SV-6	FIRE PUMP BY-PASS	FIRE PUMP ROOM
SV-7	FIRE PUMP BY-PASS N/O	FIRE PUMP ROOM
SV-8	FIRE PUMP SUCTION N/O	FIRE PUMP ROOM
SV-9	FIRE PUMP DISCHARGE N/O	FIRE PUMP ROOM
SV-10	FIRE PUMP SUCTION N/O	FIRE PUMP ROOM
SV-11	FIRE PUMP DISCHARGE N/O	FIRE PUMP ROOM
SV-12	FIRE PUMP TEST CONNECTION	FIRE PUMP ROOM
SV-13	FIRE PUMP TEST CONNECTION	FIRE PUMP ROOM
SV-14	FHV & SPR. COMBINATION MAIN (HIGH PRESSURE)	FIRE PUMP ROOM
SV-15	FHV & SPR. COMBINATION MAIN (LOW PRESSURE)	FIRE PUMP ROOM
SV-16	DRY SPRINKLER SYSTEM P3	FIRE PUMP ROOM
SV-17	DRY SPRINKLER SYSTEM P2	FIRE PUMP ROOM
SV-18	DRY SPRINKLER SYSTEM P1	FIRE PUMP ROOM
SV-19	HIGH PRESSURE INTER CONNECTION	38TH FLOOR
SV-20	FIRE STANDPIPE RISER	P1
SV-21	FIRE STANDPIPE RISER	P1
SV-22	FIRE STANDPIPE RISER	P1
SV-23	FIRE STANDPIPE RISER	P1
SV-24	FIRE STANDPIPE RISER FOR U/G	P1
SV-25	FIRE STANDPIPE RISER FOR U/G	P1
SV-101	PRV STATION IN	FIRE PUMP ROOM
SV-102	PRV STATION IN	FIRE PUMP ROOM
SV-103	PRV STATION BY-PASS	FIRE PUMP ROOM
SV-104	PRV STATION OUT	FIRE PUMP ROOM
SV-105	PRV STATION OUT	FIRE PUMP ROOM
SV-106	PRV STATION BY-PASS	FIRE PUMP ROOM
SV-107	PRV STATION DRAIN	FIRE PUMP ROOM


LOW AIR PRESSURE SWITCH SCHEDULE		
VALVE No.	SERVICE	LOCATION
LAPS-1	DRY SPRINKLER SYSTEM ON P1	FIRE PUMP ROOM
LAPS-2	DRY SPRINKLER SYSTEM ON P2	FIRE PUMP ROOM
LAPS-3	DRY SPRINKLER SYSTEM ON P3	FIRE PUMP ROOM

PRESSURE SWITCH SCHEDULE		
VALVE No.	SERVICE	LOCATION
PS-1	DRY SPRINKLER SYSTEM ON P1	FIRE PUMP ROOM
PS-2	DRY SPRINKLER SYSTEM ON P2	FIRE PUMP ROOM
PS-3	DRY SPRINKLER SYSTEM ON P3	FIRE PUMP ROOM

SUPERVISED VALVE SCHEDULE-2			
VALVE NUMBER	SERVICE	LOCATION	
SV-F0	WET SPRINKLER SYSTEM ON GROUND FLOOR	STAIR D, GF	
SV-F1	WET SPRINKLER SYSTEM ON UPPER GROUND FLOOR	STAIR D, UGF	
SV-F2	WET SPRINKLER SYSTEM ON 2ND FLOOR	STAIR D, 2ND FLOOR	
SV-F3	WET SPRINKLER SYSTEM ON 3RD FLOOR	STAIR D, 3RD FLOOR	
SV-F4	WET SPRINKLER SYSTEM ON 4TH FLOOR	STAIR D, 4TH FLOOR	
SV-F5	WET SPRINKLER SYSTEM ON 5TH FLOOR	STAIR D, 5TH FLOOR	
SV-F6	WET SPRINKLER SYSTEM ON 6TH FLOOR	STAIR D, 6TH FLOOR	
SV-F7	WET SPRINKLER SYSTEM ON 7TH FLOOR	STAIR D, 7TH FLOOR	
SV-F8	WET SPRINKLER SYSTEM ON 8TH FLOOR	STAIR D, 8TH FLOOR	
SV-F9	WET SPRINKLER SYSTEM ON 9TH FLOOR	STAIR D, 9TH FLOOR	
SV-F10	WET SPRINKLER SYSTEM ON 10TH FLOOR	STAIR D, 10TH FLOOR	
SV-F11	WET SPRINKLER SYSTEM ON 11TH FLOOR	STAIR D, 11TH FLOOR	
SV-F12	WET SPRINKLER SYSTEM ON 12TH FLOOR	STAIR D, 12TH FLOOR	
SV-F13	WET SPRINKLER SYSTEM ON 13TH FLOOR	STAIR D, 13TH FLOOR	
SV-F14	WET SPRINKLER SYSTEM ON 14TH FLOOR	STAIR D, 14TH FLOOR	
SV-F15	WET SPRINKLER SYSTEM ON 15TH FLOOR	STAIR D, 15TH FLOOR	
SV-F16	WET SPRINKLER SYSTEM ON 16TH FLOOR	STAIR D, 16TH FLOOR	
SV-F17	WET SPRINKLER SYSTEM ON 17TH FLOOR	STAIR D, 17TH FLOOR	
SV-F18	WET SPRINKLER SYSTEM ON 18TH FLOOR	STAIR D, 18TH FLOOR	
SV-F19	WET SPRINKLER SYSTEM ON 19TH FLOOR	STAIR D, 19TH FLOOR	
SV-F20	WET SPRINKLER SYSTEM ON 20TH FLOOR	STAIR D, 20TH FLOOR	
SV-F21	WET SPRINKLER SYSTEM ON 21TH FLOOR	STAIR D, 21TH FLOOR	
SV-F22	WET SPRINKLER SYSTEM ON 22TH FLOOR	STAIR D, 22TH FLOOR	
SV-F23	WET SPRINKLER SYSTEM ON 23TH FLOOR	STAIR D, 23TH FLOOR	
SV-F24	WET SPRINKLER SYSTEM ON 24TH FLOOR	STAIR D, 24TH FLOOR	
SV-F25	WET SPRINKLER SYSTEM ON 25TH FLOOR	STAIR D, 25TH FLOOR	
SV-F26	WET SPRINKLER SYSTEM ON 26TH FLOOR	STAIR D, 26TH FLOOR	
SV-F27	WET SPRINKLER SYSTEM ON 27TH FLOOR	STAIR D, 27TH FLOOR	
SV-F28	WET SPRINKLER SYSTEM ON 28TH FLOOR	STAIR D, 28TH FLOOR	
SV-F29	WET SPRINKLER SYSTEM ON 29TH FLOOR	STAIR D, 29TH FLOOR	
SV-F30	WET SPRINKLER SYSTEM ON 30TH FLOOR	STAIR D, 30TH FLOOR	
SV-F31	WET SPRINKLER SYSTEM ON 31TH FLOOR	STAIR D, 31TH FLOOR	
SV-F32	WET SPRINKLER SYSTEM ON 32TH FLOOR	STAIR D, 32TH FLOOR	
SV-F33	WET SPRINKLER SYSTEM ON 33TH FLOOR	STAIR D, 33TH FLOOR	
SV-F34	WET SPRINKLER SYSTEM ON 34TH FLOOR	STAIR D, 34TH FLOOR	
SV-F35	WET SPRINKLER SYSTEM ON 35TH FLOOR	STAIR D, 35TH FLOOR	
SV-F36	WET SPRINKLER SYSTEM ON 36TH FLOOR	STAIR D, 36TH FLOOR	
SV-F37	WET SPRINKLER SYSTEM ON 37TH FLOOR	STAIR D, 37TH FLOOR	
SV-F38	WET SPRINKLER SYSTEM ON 38TH FLOOR	STAIR D, 38TH FLOOR	
SV-F39	WET SPRINKLER SYSTEM ON AMENITY FLOOR	STAIR D, AMENITY	
SV-F40	WET SPRINKLER SYSTEM ON MECH. PENTHOUSE	STAIR D, PENTHOUSE	
SV-F41	WET SPRINKLER SYSTEM ON ELEV. MACHINE ROOM	STAIR D, M. ROOM	
SV-GC1	WET SPRINKLER RISER IN GARBAGE CHUTE (L.P.)	P1-GARBAGE ROOM	
SV-GC2	WET SPRINKLER RISER IN GARBAGE CHUTE (HP)	FLOOR 38TH	
SV-WS	WINDOW SPRINKLER	GROUND FLOOR	

FLOW SWITCH SCHEDULE-1			
VALVE NUMBER	SERVICE	LOCATION	
FS-F0	WET SPRINKLER SYSTEM ON GROUND FLOOR	STAIR D, GF	
FS-F1	WET SPRINKLER SYSTEM ON UPPER GROUND FLOOR	STAIR D, UGF	
FS-F2	WET SPRINKLER SYSTEM ON 2ND FLOOR	STAIR D, 2ND FLOOR	
FS-F3	WET SPRINKLER SYSTEM ON 3RD FLOOR	STAIR D, 3RD FLOOR	
FS-F4	WET SPRINKLER SYSTEM ON 4TH FLOOR	STAIR D, 4TH FLOOR	
FS-F5	WET SPRINKLER SYSTEM ON 5TH FLOOR	STAIR D, 5TH FLOOR	
FS-F6	WET SPRINKLER SYSTEM ON 6TH FLOOR	STAIR D, 6TH FLOOR	
FS-F7	WET SPRINKLER SYSTEM ON 7TH FLOOR	STAIR D, 7TH FLOOR	
FS-F8	WET SPRINKLER SYSTEM ON 8TH FLOOR	STAIR D, 8TH FLOOR	
FS-F9	WET SPRINKLER SYSTEM ON 9TH FLOOR	STAIR D, 9TH FLOOR	
FS-F10	WET SPRINKLER SYSTEM ON 10TH FLOOR	STAIR D, 10TH FLOOR	
FS-F11	WET SPRINKLER SYSTEM ON 11TH FLOOR	STAIR D, 11TH FLOOR	
FS-F12	WET SPRINKLER SYSTEM ON 12TH FLOOR	STAIR D, 12TH FLOOR	
FS-F13	WET SPRINKLER SYSTEM ON 13TH FLOOR	STAIR D, 13TH FLOOR	
FS-F14	WET SPRINKLER SYSTEM ON 14TH FLOOR	STAIR D, 14TH FLOOR	
FS-F15	WET SPRINKLER SYSTEM ON 15TH FLOOR	STAIR D, 15TH FLOOR	
FS-F16	WET SPRINKLER SYSTEM ON 16TH FLOOR	STAIR D, 16TH FLOOR	
FS-F17	WET SPRINKLER SYSTEM ON 17TH FLOOR	STAIR D, 17TH FLOOR	
FS-F18	WET SPRINKLER SYSTEM ON 18TH FLOOR	STAIR D, 18TH FLOOR	
FS-F19	WET SPRINKLER SYSTEM ON 19TH FLOOR	STAIR D, 19TH FLOOR	
FS-F20	WET SPRINKLER SYSTEM ON 20TH FLOOR	STAIR D, 20TH FLOOR	
FS-F21	WET SPRINKLER SYSTEM ON 21TH FLOOR	STAIR D, 21TH FLOOR	
FS-F22	WET SPRINKLER SYSTEM ON 22TH FLOOR	STAIR D, 22TH FLOOR	
FS-F23	WET SPRINKLER SYSTEM ON 23TH FLOOR	STAIR D, 23TH FLOOR	
FS-F24	WET SPRINKLER SYSTEM ON 24TH FLOOR	STAIR D, 24TH FLOOR	
FS-F25	WET SPRINKLER SYSTEM ON 25TH FLOOR	STAIR D, 25TH FLOOR	
FS-F26	WET SPRINKLER SYSTEM ON 26TH FLOOR	STAIR D, 26TH FLOOR	
FS-F27	WET SPRINKLER SYSTEM ON 27TH FLOOR	STAIR D, 27TH FLOOR	
FS-F28	WET SPRINKLER SYSTEM ON 28TH FLOOR	STAIR D, 28TH FLOOR	
FS-F29	WET SPRINKLER SYSTEM ON 29TH FLOOR	STAIR D, 29TH FLOOR	
FS-F30	WET SPRINKLER SYSTEM ON 30TH FLOOR	STAIR D, 30TH FLOOR	
FS-F31	WET SPRINKLER SYSTEM ON 31TH FLOOR	STAIR D, 31TH FLOOR	
FS-F32	WET SPRINKLER SYSTEM ON 32TH FLOOR	STAIR D, 32TH FLOOR	
FS-F33	WET SPRINKLER SYSTEM ON 33TH FLOOR	STAIR D, 33TH FLOOR	
FS-F34	WET SPRINKLER SYSTEM ON 34TH FLOOR	STAIR D, 34TH FLOOR	
FS-F35	WET SPRINKLER SYSTEM ON 35TH FLOOR	STAIR D, 35TH FLOOR	
FS-F36	WET SPRINKLER SYSTEM ON 36TH FLOOR	STAIR D, 36TH FLOOR	
FS-F37	WET SPRINKLER SYSTEM ON 37TH FLOOR	STAIR D, 37TH FLOOR	
FS-F38	WET SPRINKLER SYSTEM ON 38TH FLOOR	STAIR D, 38TH FLOOR	
FS-F39	WET SPRINKLER SYSTEM ON AMENITY FLOOR	STAIR D, AMENITY	
FS-F40	WET SPRINKLER SYSTEM ON MECH. PENTHOUSE	STAIR D, PENTHOUSE	
FS-F41	WET SPRINKLER SYSTEM ON ELEV. MACHINE ROOM	STAIR D, M. ROOM	
FS-1	SPRINKLER RISER IN PUMP ROOM (HIGH PRESSURE)	FIRE PUMP	
FS-2	SPRINKLER RISER IN PUMP ROOM (LOW PRESSURE)	FIRE PUMP	
FS-GC1	WET SPRINKLER RISER IN GARBAGE CHUTE (L.P.)	P1-GARBAGE ROOM	
FS-GC2	WET SPRINKLER RISER IN GARBAGE CHUTE (HP)	FLOOR 38TH	
FS-WS	WINDOW SPRINKLER	GROUND FLOOR	

MATERIAL NOTES:		
LOCATION	MATERIAL	
SPRINKLER RISERS	STEEL PIPE SCHEDULE 40	
PARKING GARAGE	STEEL PIPE SCHEDULE 10	
LEVELS CORRIDORS	CPVC PIPE	
RESIDENTIAL UNITS	CPVC PIPE	
STANDPIPE (ABOVE 175 PSI)	STEEL PIPE SCHEDULE 40	
STANDPIPE (BELOW 175 PSI)	STEEL PIPE SCHEDULE 10	
FITTING (MAINS)	UL LISTED GROOVED FITTINGS	
FITTING (LINES)	UL LISTED GROOVED FITTINGS	
HANGER (MAINS)	AS PER NFPA 13 REQUIREMENTS	
HANGER (LINES)	AS PER NFPA 13 REQUIREMENTS	

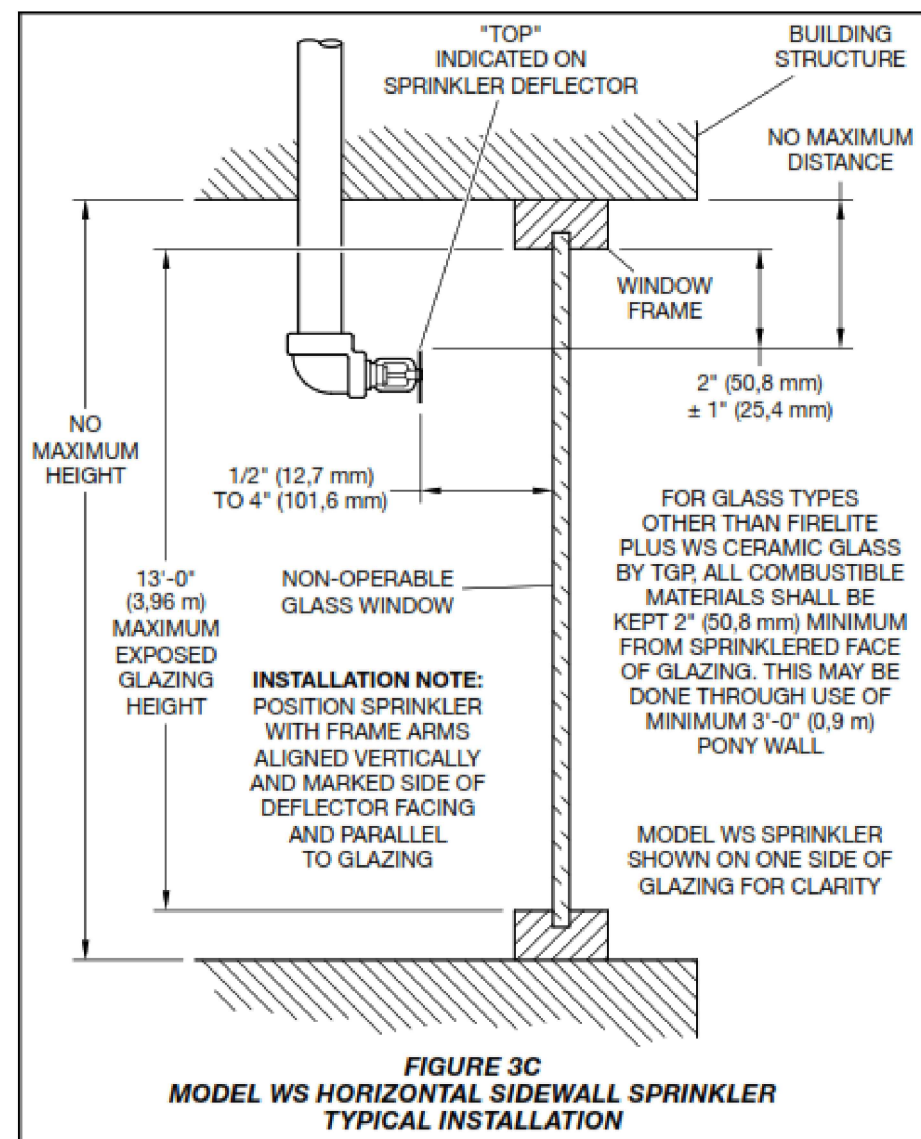


The diagram illustrates a fire sprinkler system for a 21-story building. The system is divided into three main sections: the upper section (floors 18-21), the middle section (floors 14-17), and the lower section (floors 1-13). The system is designed to provide adequate water pressure and flow to all sprinklers throughout the building.

Key Features:


- Floors:** The system covers floors from the Ground Floor to the 21st Floor.
- Pressure Zones:** The system is divided into three main pressure zones:
 - Upper Zone (Floors 18-21):** This zone is designed for a pressure of 158.7 PSI @ FHV.
 - Middle Zone (Floors 14-17):** This zone is designed for a pressure of 148.4 PSI @ FHV.
 - Lower Zone (Floors 1-13):** This zone is designed for a pressure of 152.8 PSI @ FHV.
- Low Pressure Zone:** A specific area between the 14th and 15th floors is designated as a "LOW PRESSURE ZONE (Approx. Static Pressure)".
- Valves and Drains:** The diagram shows the location of various valves, including the main supply valve (SV-25), and drains, including the 3" draw-off to nearest floor drain (SV-21).
- Pipes:** The system uses 4" LP (Low Pressure) pipes for the main supply and 6" HP (High Pressure) pipes for the distribution.
- Stairs:** The system is designed to provide water to the stairs, with specific valves and pipes shown for each stairwell.

The diagram also includes a detailed view of the system's connection to the main building supply and the location of various valves and drains. The system is designed to provide adequate water pressure and flow to all sprinklers throughout the building.

NOTE: 1. ELECTRICAL SPECIFICATIONS FOR FIRE PUMP TO BE CONFIRMED BY ELECTRICAL CONSULTANT.
2. JOCKEY PUMP TO START AT 10 PSI LESS THAN SHUT OFF PRESSURE.
3. FIRE PUMP TO START AT 20 PSI LESS THAN JOCKEY PUMP SHUT OFF PRESSURE.
4. FIRE PUMP SIZE AS PER MECHANICAL DRAWING.

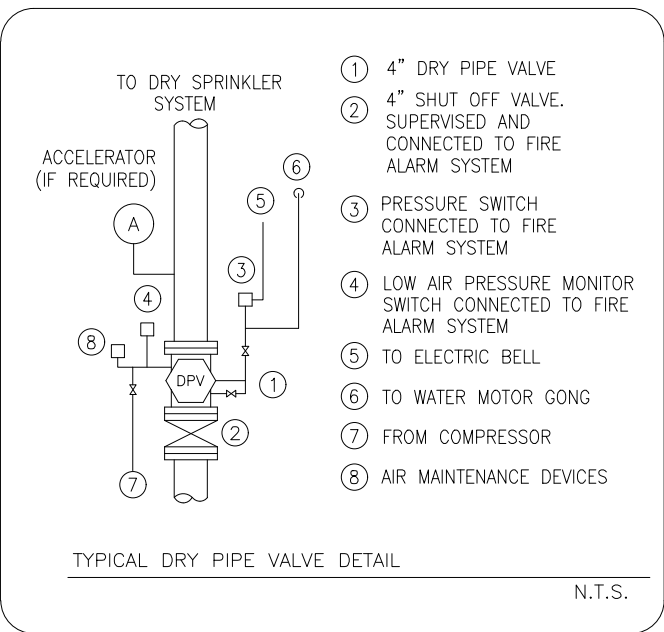

A technical diagram of a 6" double check detector assembly for indoor horizontal installation. The assembly is shown in a cross-section view, mounted on a concrete foundation. It consists of a main horizontal pipe with a vertical riser pipe. The riser pipe has a valve and a pressure gauge. The main pipe has a valve and a pressure gauge. The assembly is labeled "6\"

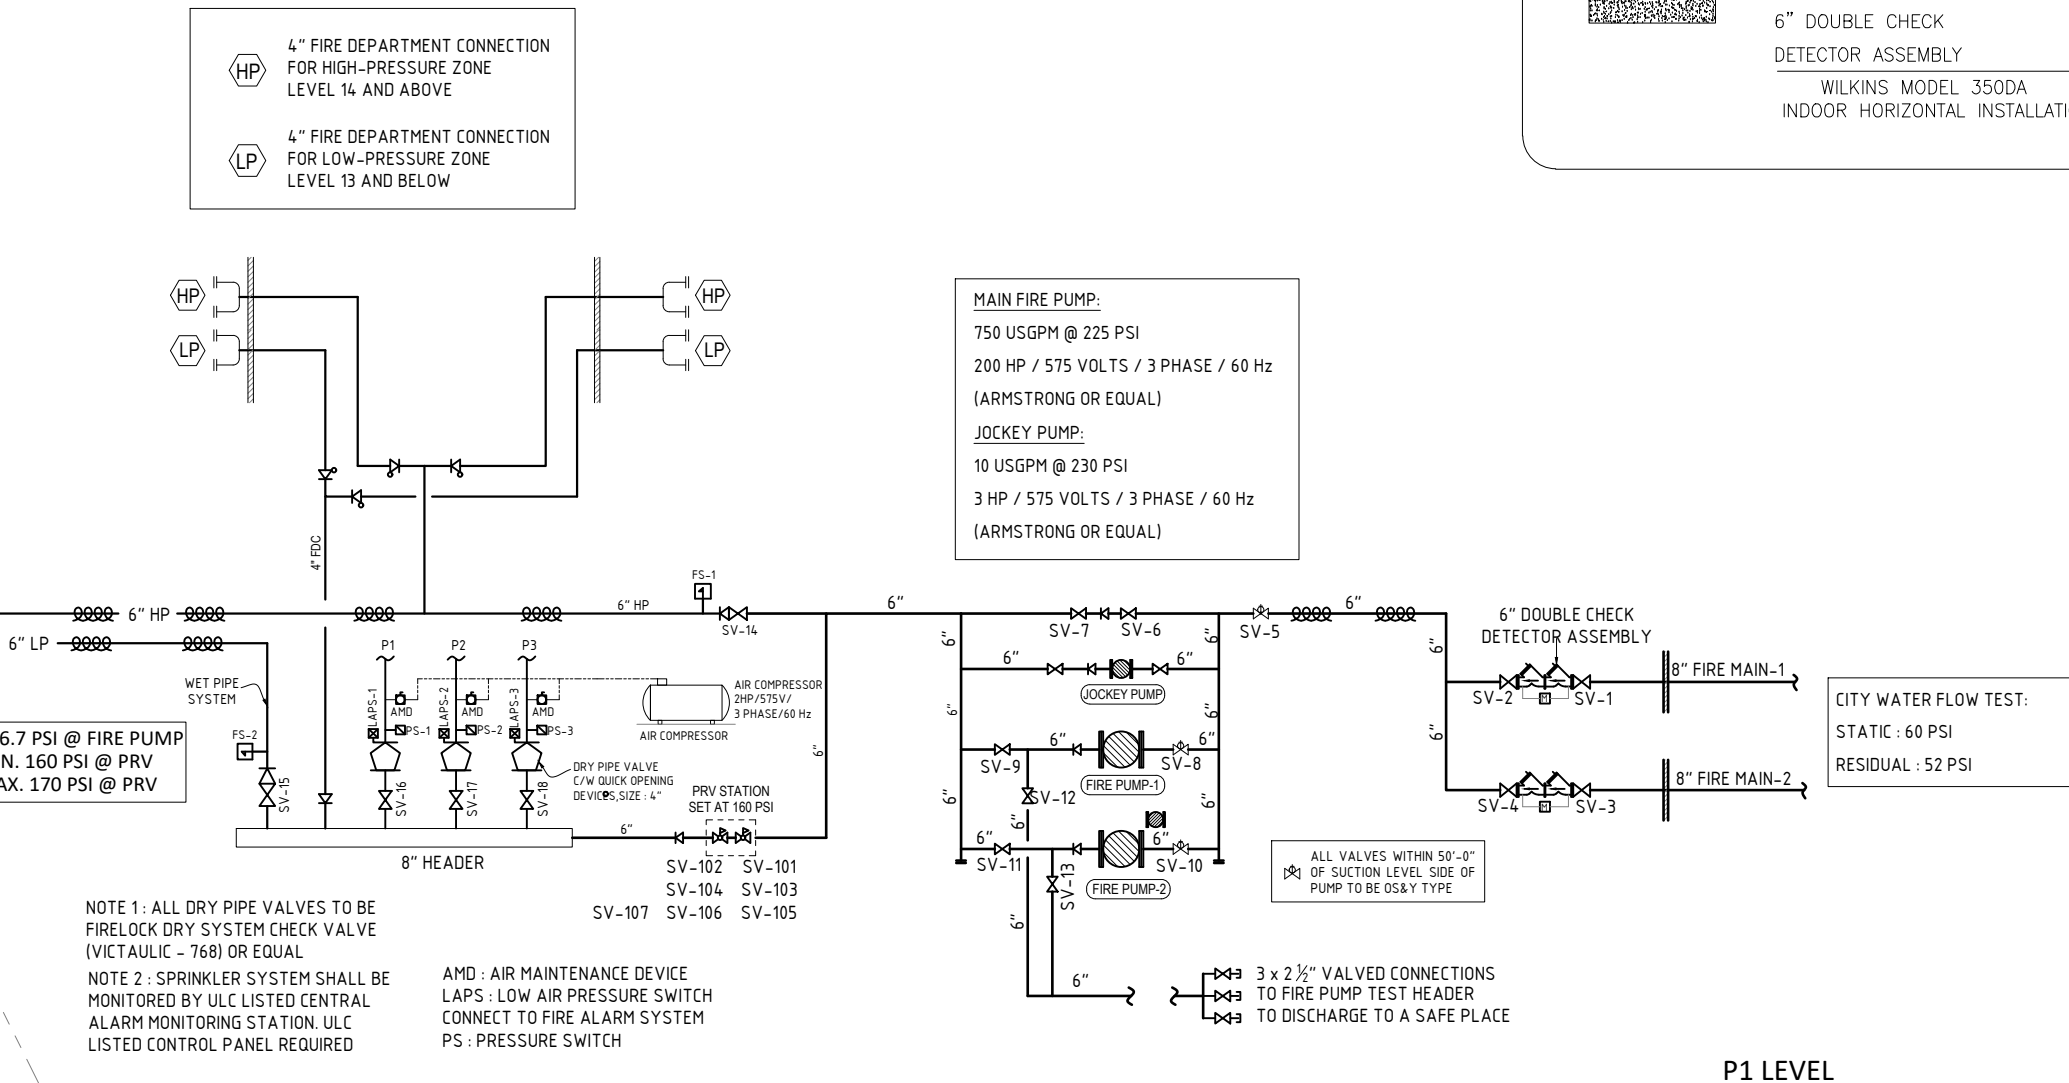

ISSUED/REVISION RECORD		
X	ISS XX/XXXX	XXXXXXXXXXXXXXXXXXXX
NO	DATE	DESCRIPTION

DRAWING TITLE

FIRE PROTECTION RISER
SCHEMATIC & DETAILS


PROJECT NORTH
TRUE NORTH

22-0007

PROJECT

SK	RJ
BY	REVIEWED


SP-05

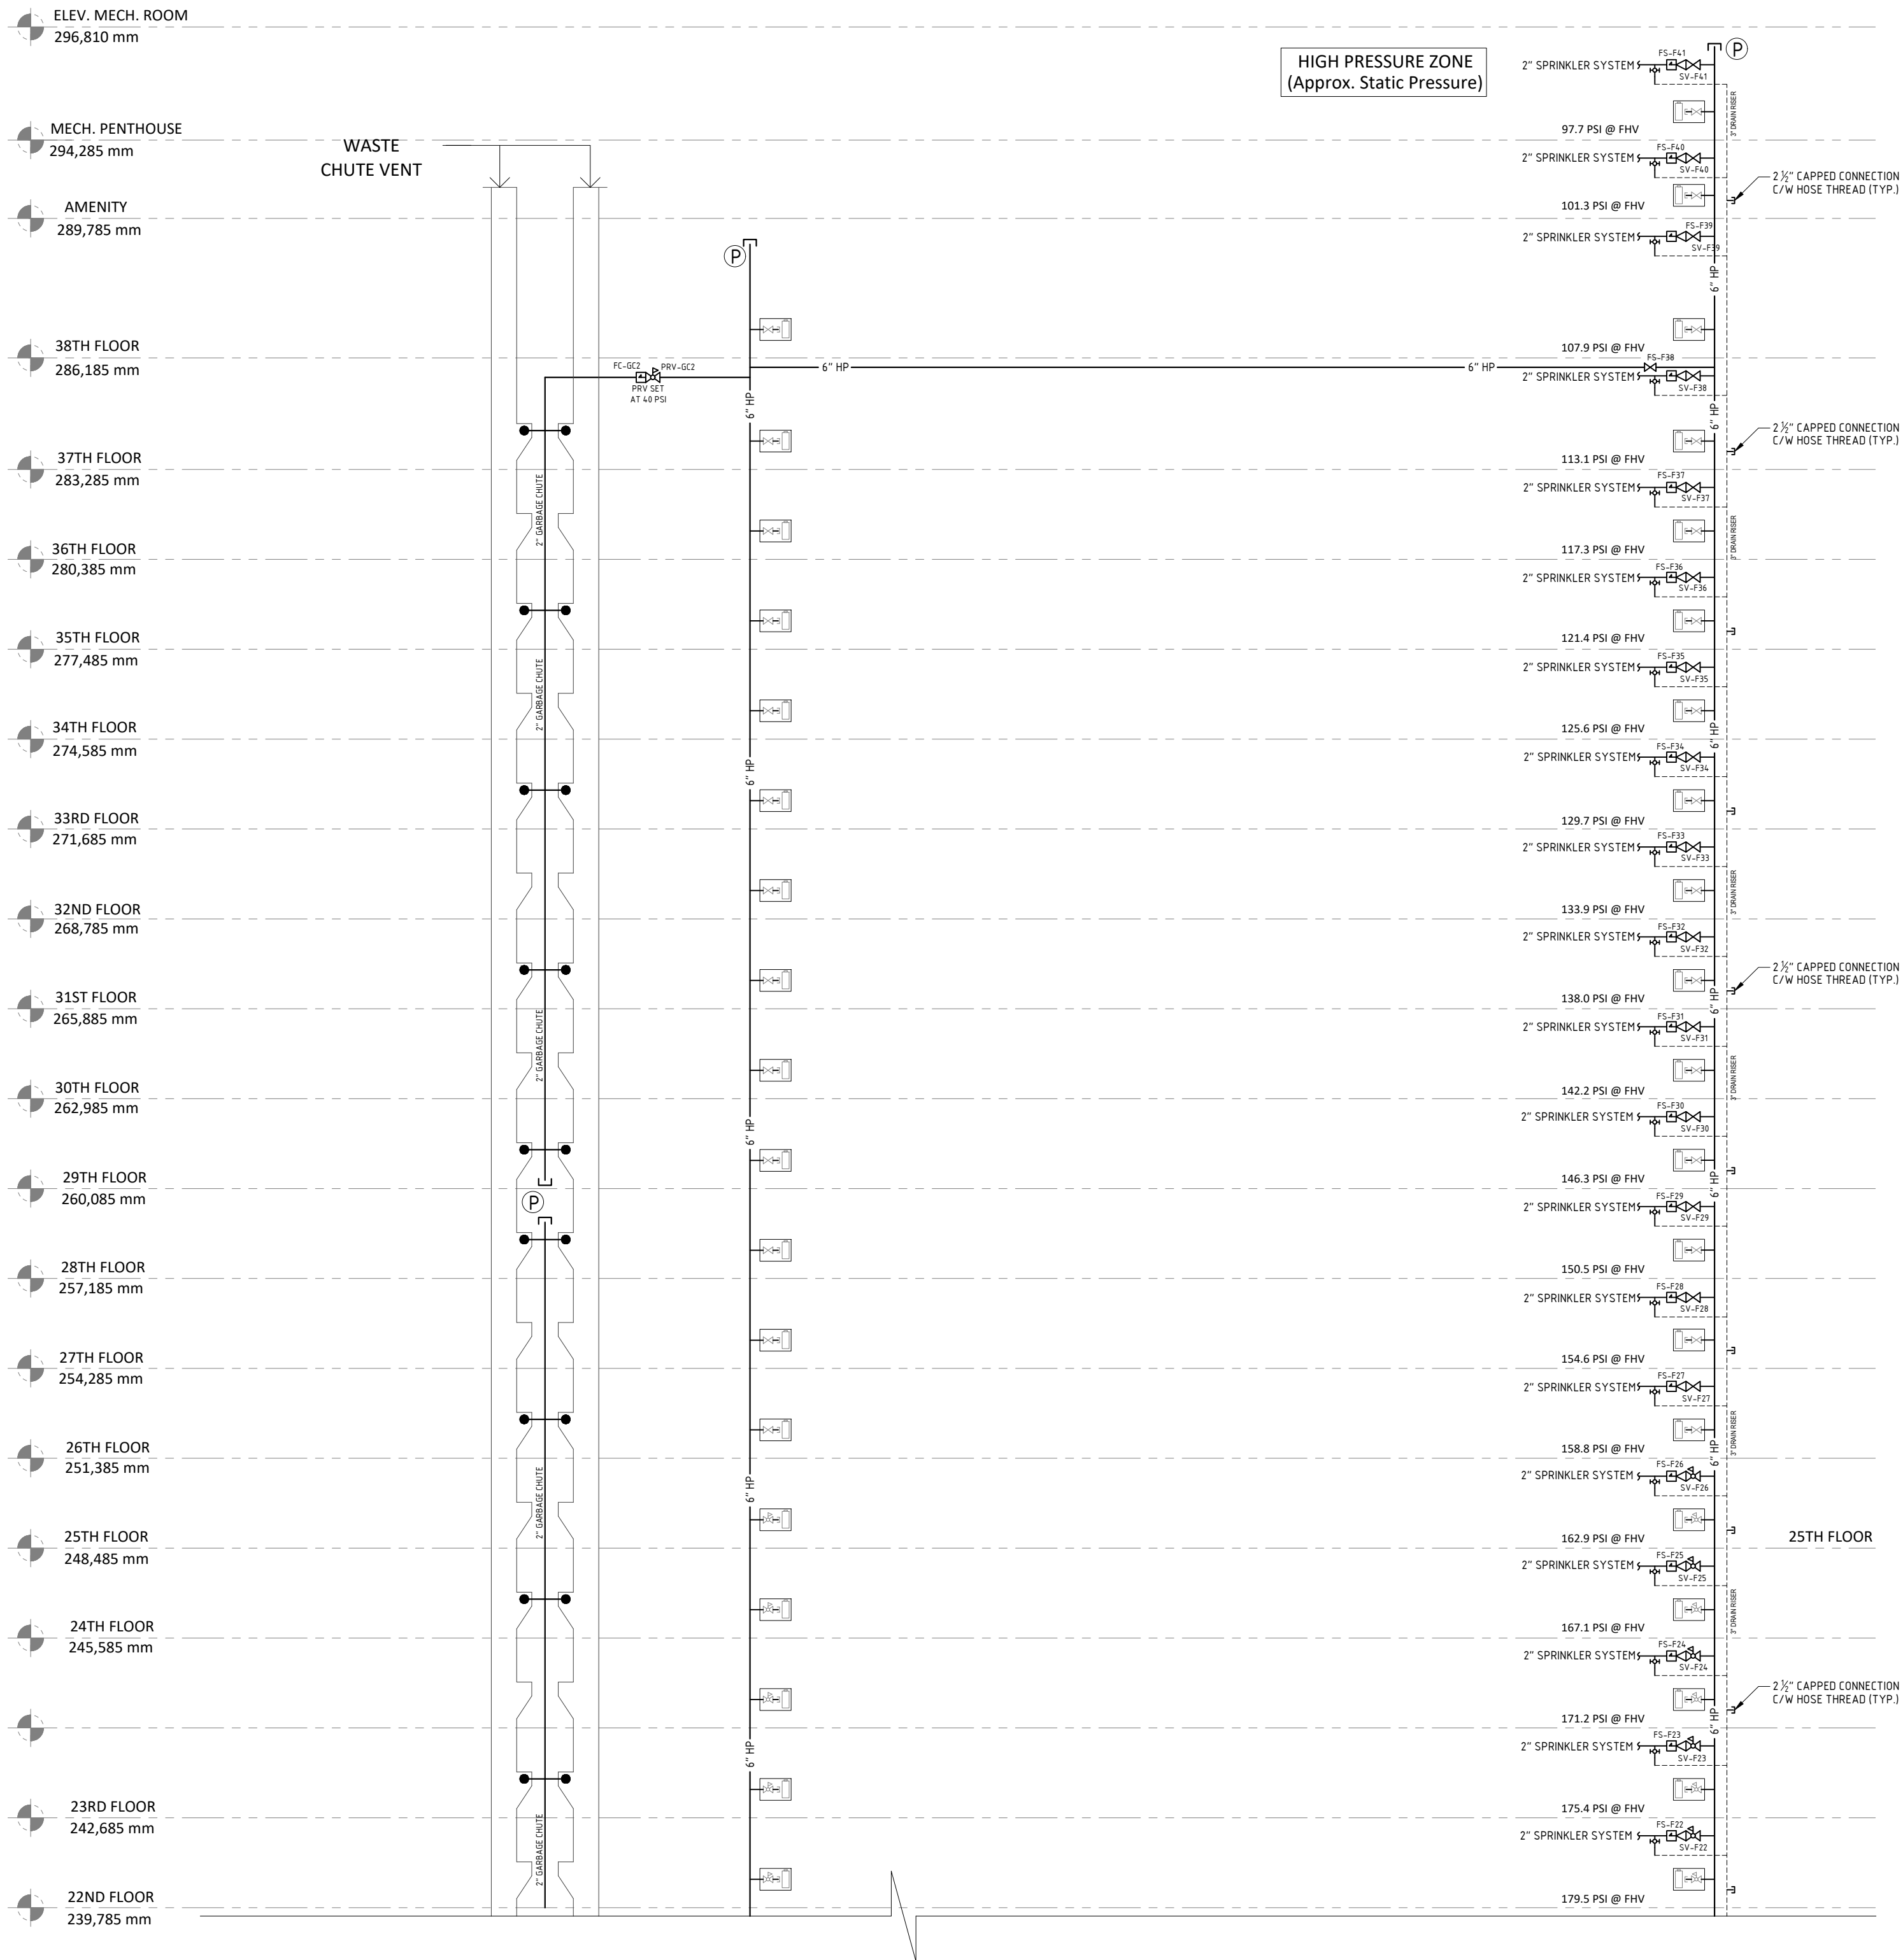



X	XX	XXXXXXXXXX
NO	DATE	DESCRIPTION
ISSUED/REVISION RECORD		

PROJECT
PROPOSED MIXED-USED DEVELOPMENT
ADDRESS:
775-783 Vaughan Rd & 670-680
Northcliffe Blvd, York, ON

DRAWING TITLE
FIRE PROTECTION RISER
SCHEMATIC & DETAILS
(CONT...)

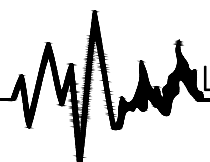
 LIFELINE FIRE PROTECTION
www.lifelinefireprotection.com
50 Casimir Court, Concord, ON
L4K 4J5
(416)850-9477

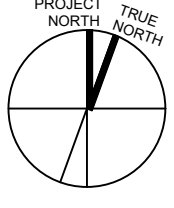
	PROJECT	22-0007
	BY	REVIEWED
SP-06		

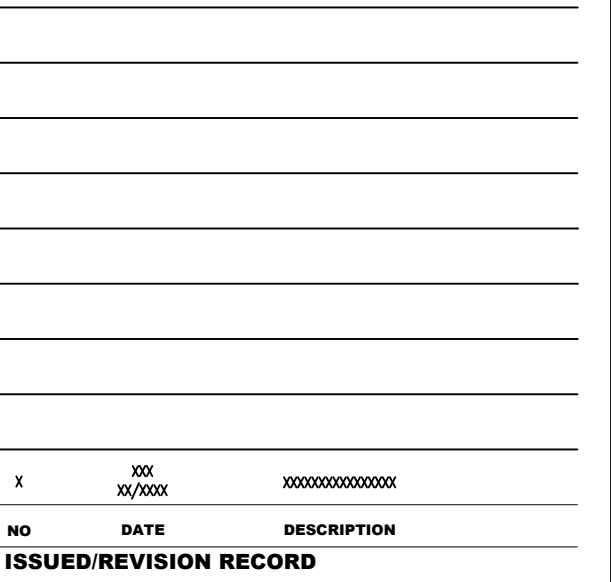

DRAWING TITLE

FIRE PROTECTION RISER
ISOMETRIC DIAGRAM
LOW PRESSURE ZONE

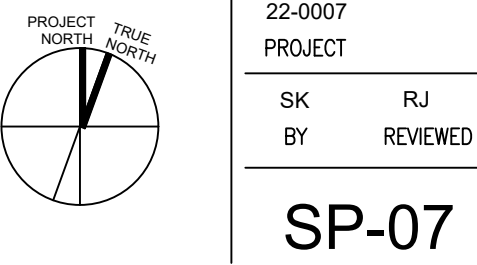

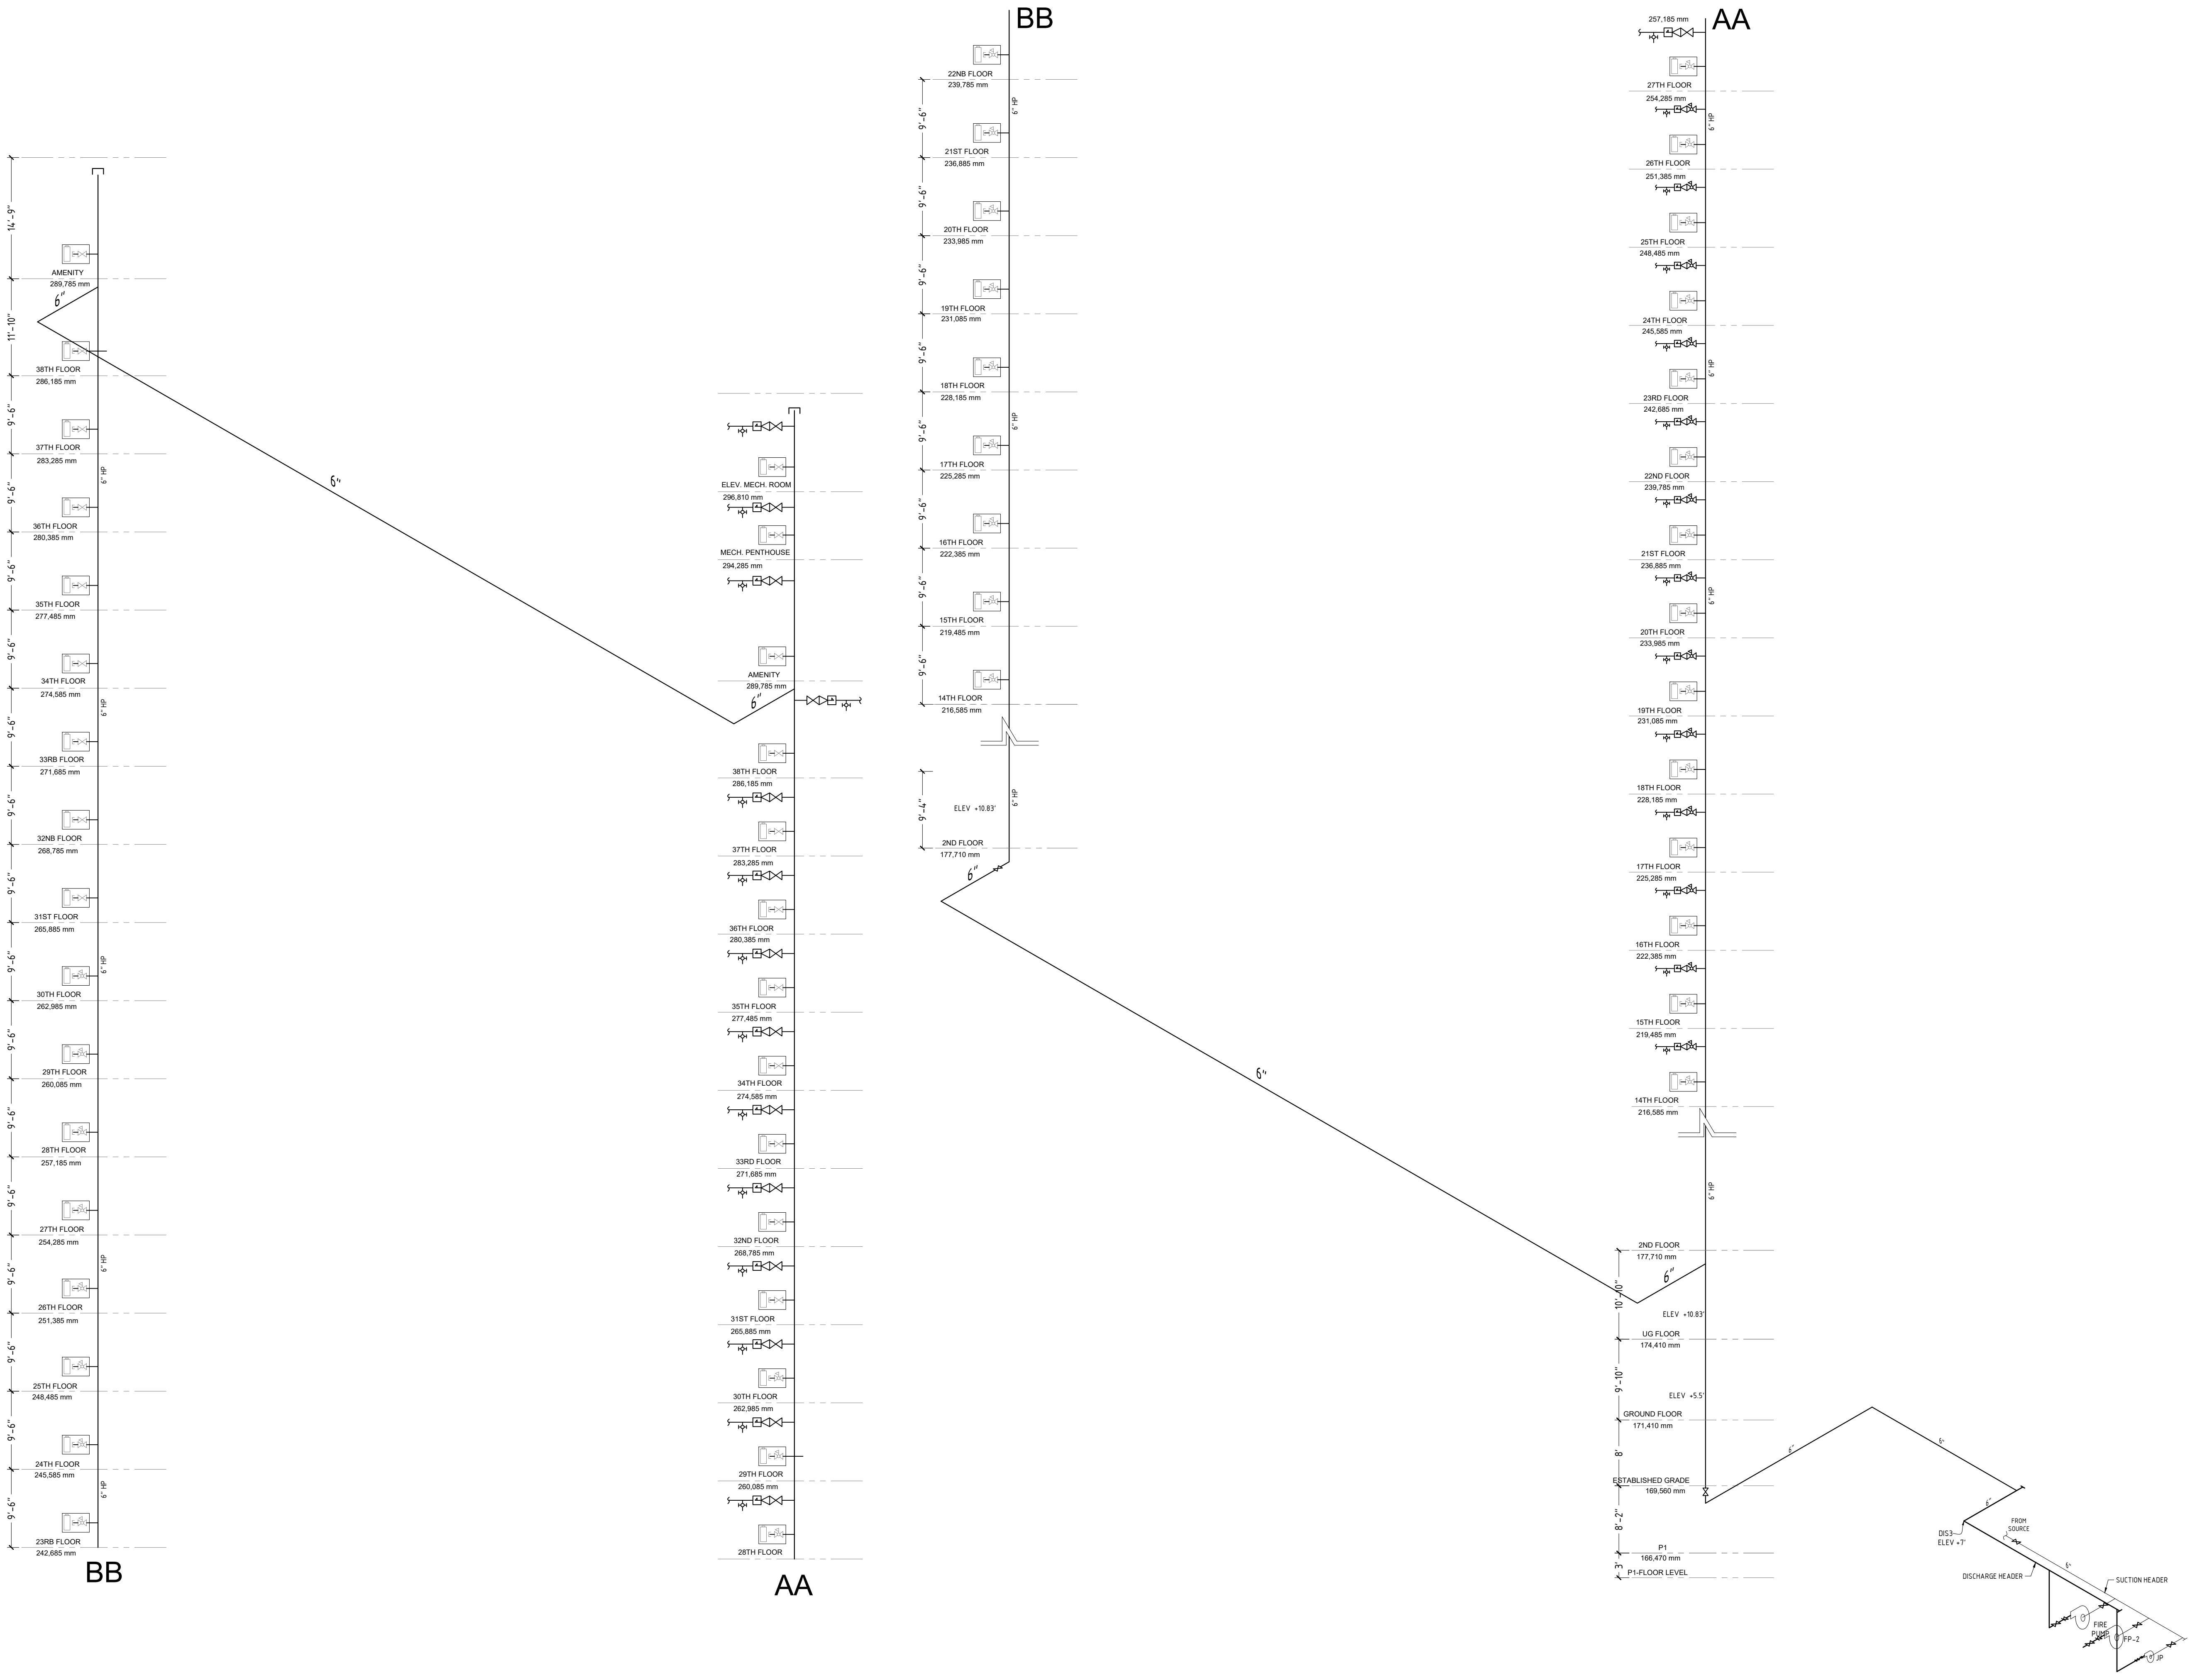


X	XX	XXXXXXX
NO	DATE	DESCRIPTION
ISSUED/REVISION RECORD		


PROJECT
PROPOSED MIXED-USED DEVELOPMENT
ADDRESS:
775-783 Vaughan Rd & 670-680
Northcliffe Blvd, York, ON

DRAWING TITLE

FIRE PROTECTION RISER
ISOMETRIC DIAGRAM
HIGH PRESSURE ZONE

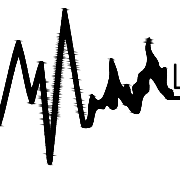 **LIFELINE FIRE PROTECTION**
www.lifelinefireprotection.com
50 Casimir Court, Concord, ON
L4K 4J5
(416)850-9477

PROJECT NORTH TRUE NORTH	22-0007 PROJECT SK BY RJ REVIEWED SP-08
-----------------------------------	--

 

SPRINKLER HEAD LEGEND


 C/W GUARD


 Q/R QUICK RESPONSE
E/C EXTENDED RESPONSE

	THREAD SIZE	K-FACTOR	TEMP. RATING	STYLE/MODEL	RESPONSE
	1/2"	14	155°F	EXTENDED COVERAGE UPRIGHT	S/R
	1/2"	5.6	165°F	UPRIGHT S/C	S/R
	1/2"	5.6	165°F	DRY UPRIGHT SPRINKLER HEAD	Q/R
	1/2"	5.6	165°F	STANDARD COVERAGE UPRIGHT	Q/R
	1/2"	5.6	212°F	STANDARD COVERAGE PENDENT	Q/R
	1"	5.6	155°F	FULLY CONCEALED DRY PENDENT S/C	Q/R
	1"	5.6	165°F	DRY PENDENT S/C	Q/R
	1/2"	11.2	200°F	EXTENDED COVERAGE SIDEWALL	S/R
	1/2"	5.6	155°F	WINDOW SPRINKLER	Q/R
	1/2"	5.6	165°F	STANDARD COVERAGE SIDEWALL	Q/R
	1/2"	5.8	200°F	RESIDENTIAL FULLY CONCEALED PENDENT	Q/R
	1/2"	5.8	200°F	RESIDENTIAL FULLY CONCEALED SIDEWALL	Q/R
	1/2"	5.6	165°F	CONCEALED PENDENT S/C	Q/R
	1/2"	5.6	212°F	RESIDENTIAL FULLY CONCEALED PENDENT S/C	Q/R
	1/2"	8.0	288°F	UPRIGHT IN LOCKER ROOM S/C	S/R
	2 1/2" STANDARD FIRE HOSE VALVE C/W THREADED CAP IN STAINLESS				
	2 1/2" FIRE HOSE VALVE IN CABINET C/W FIRE EXTINGUISHER				

DRAWING TITLE

UNDER GROUND PARKING LEVEL
P3- FIRE PROTECTION PLAN

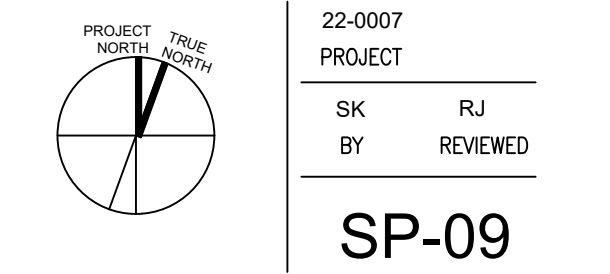

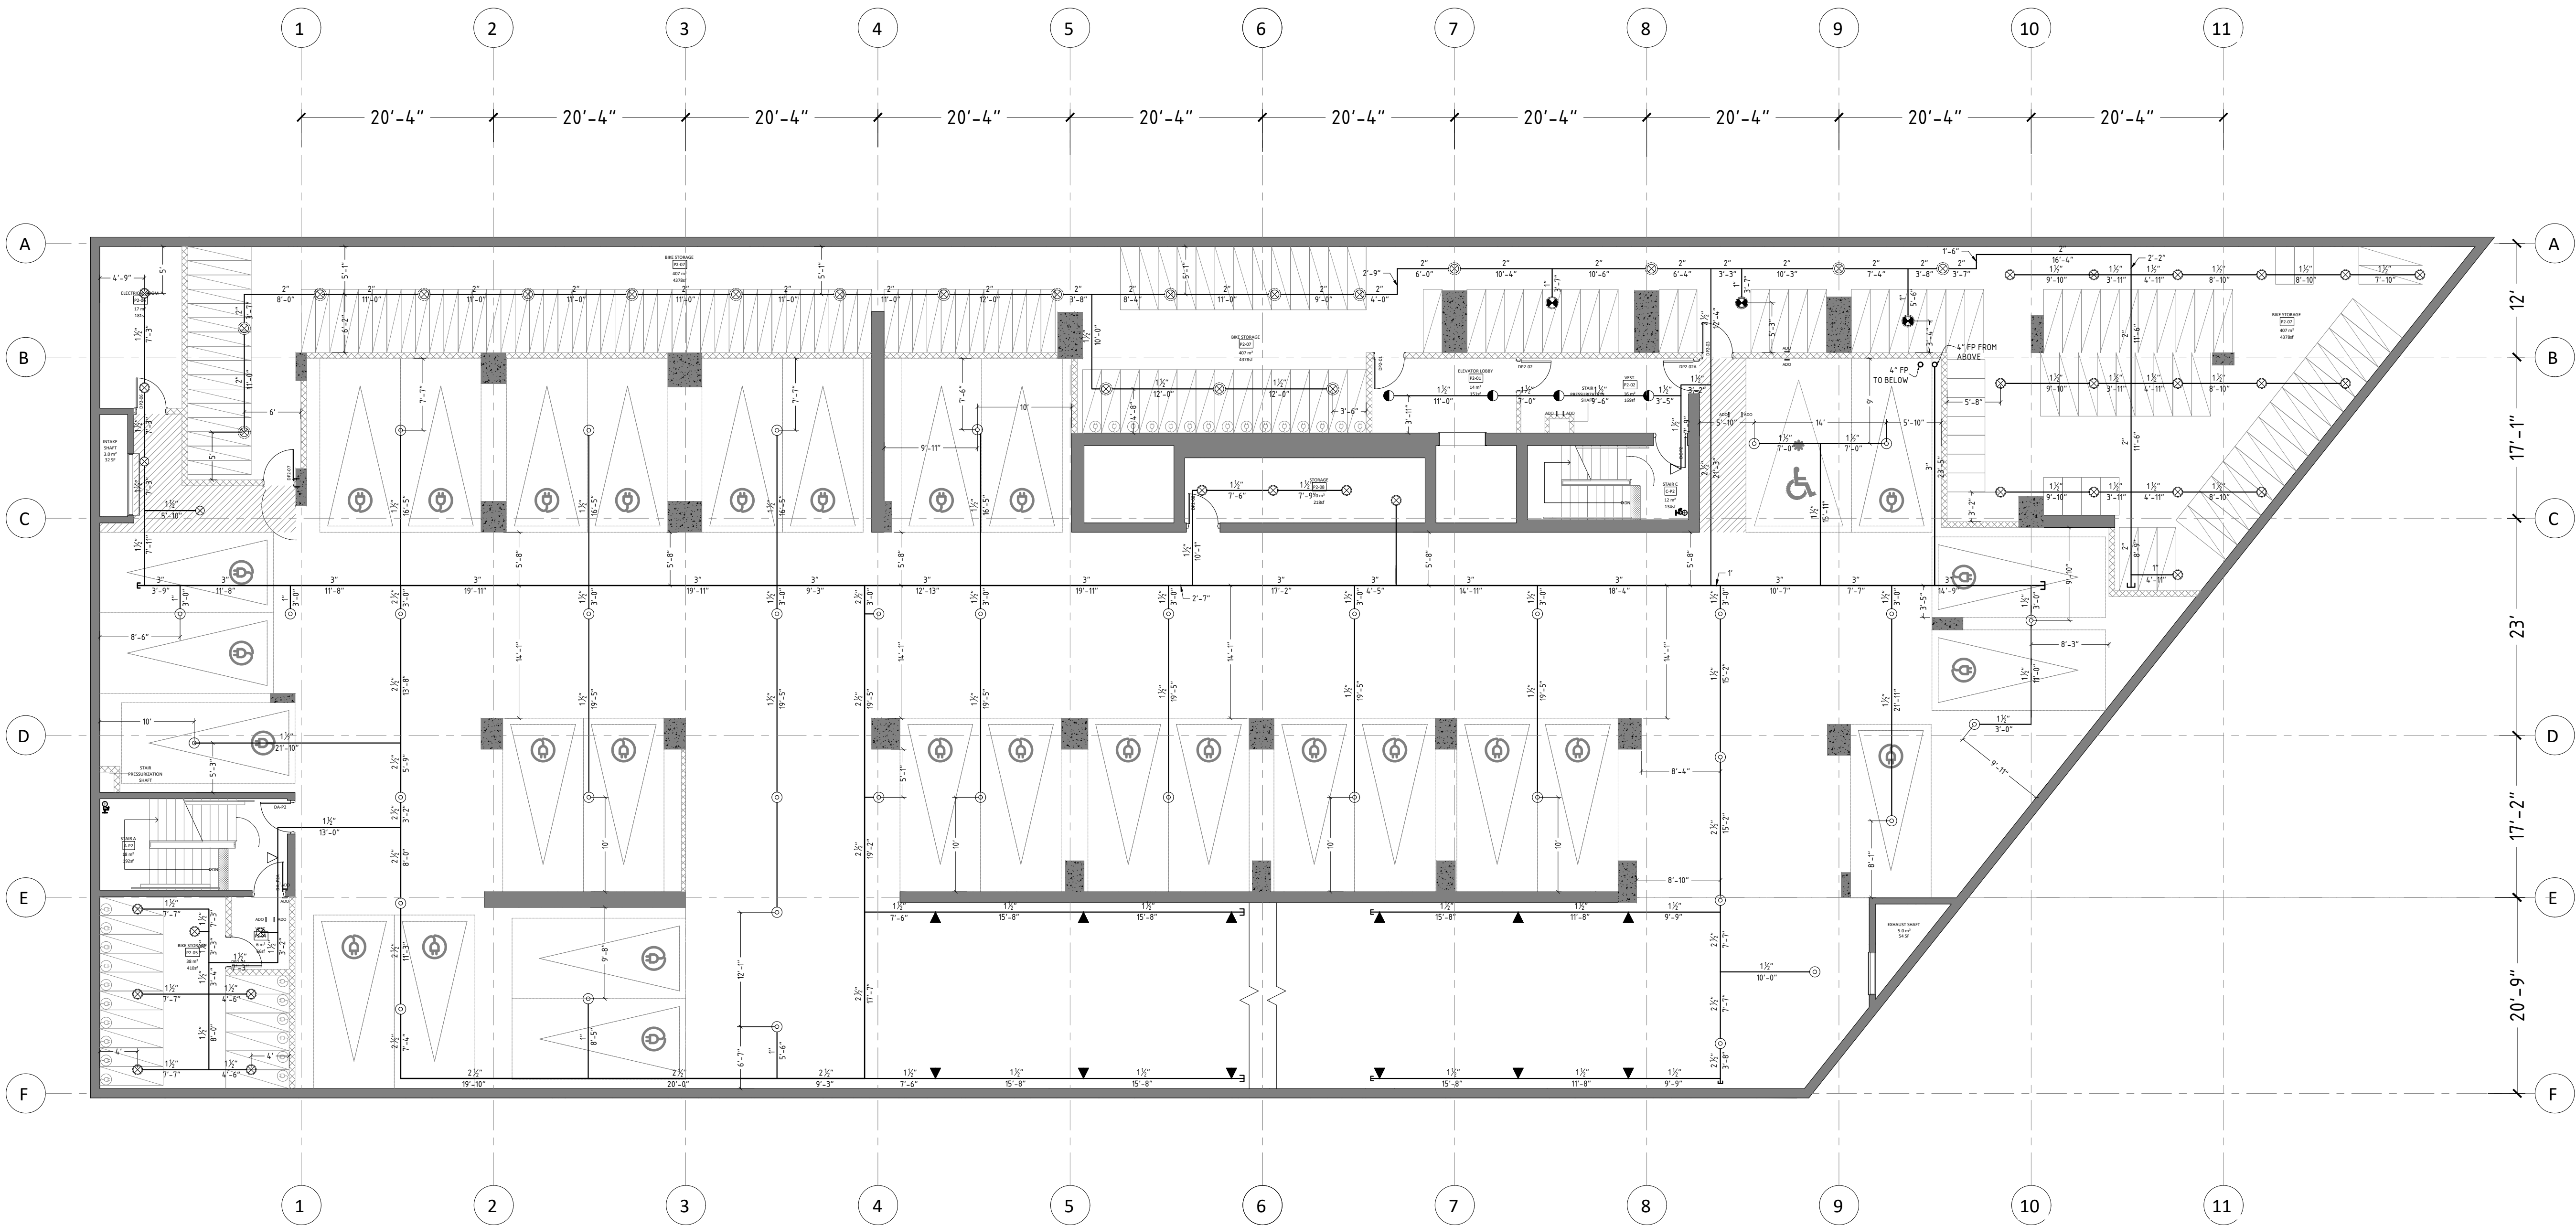

X	XX	XXXXXXXXXXXX
NO	DATE	DESCRIPTION
ISSUED/REVISION RECORD		

SPRINKLER HEAD LEGEND				
C/W GUARD				
S/R=STANDARD RESPONSE Q/R=QUICK RESPONSE				
S/C=STANDARD COVERAGE E/C=EXTENDED COVERAGE				
SYMBOL	THREAD SIZE	K-FACTOR	TEMP RATING	RESPONSE
⊙	1/2"	14	155°F	EXTENDED COVERAGE UPRIGHT
⊙	1/2"	5.6	165°F	UPRIGHT S/C
⊙	1/2"	5.6	165°F	DRY UPRIGHT SPRINKLER HEAD
⊙	1/2"	5.6	165°F	STANDARD COVERAGE UPRIGHT
⊙	1/2"	5.6	212°F	STANDARD COVERAGE UPRIGHT
⊙	1"	5.6	155°F	FULLY CONCEALED DRY PENDENT S/C
⊙	1"	5.6	165°F	DRY PENDENT S/C
⊙	1/2"	11.2	200°F	EXTENDED COVERAGE SIDEWALL
⊙	1/2"	5.6	155°F	WINDOW SPRINKLER
⊙	1/2"	5.6	165°F	STANDARD COVERAGE SIDEWALL
⊙	1/2"	5.8	200°F	RESIDENTIAL FULLY CONCEALED PENDENT
⊙	1/2"	5.8	200°F	RESIDENTIAL FULLY CONCEALED SIDEWALL
⊙	1/2"	5.6	165°F	CONCEALED PENDENT S/C
⊙	1/2"	5.6	212°F	RESIDENTIAL FULLY CONCEALED PENDENT S/C
⊙	1/2"	8.0	286°F	UPRIGHT IN LOCKER ROOM S/C
2 1/2" STANDARD FIRE HOSE VALVE				
C/W THREADED CAP IN STAIRWELL				
2 1/2" FIRE HOSE VALVE IN CABINET				
C/W FIRE EXTINGUISHER				


REFERENCE TO ALTERNATIVE SOLUTION REPORT :
LOCATE 65 mm DIA FIRE HOSE VALE (FHV)
CONNECTIONS WITHIN THE EXIT STAIRS
ENCLOSURES, CLASS 1 STANDPIPE SYSTEM,
PORTABLE FIRE EXTINGUISHERS PROVIDED
THROUGHOUT THE FLOORS.


PROJECT


PROPOSED MIXED-USED DEVELOPMENT
ADDRESS:
775-783 Vaughan Rd & 670-680
Northcliffe Blvd, York, ON

DRAWING TITLE

UNDER GROUND PARKING LEVEL
P2- FIRE PROTECTION PLAN

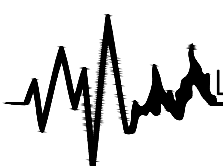 **LIFELINE FIRE PROTECTION**
www.lifelinefireprotection.com
50 Casimir Court, Concord, ON
L4K 4J5
(416)850-9477

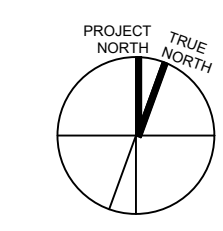	22-0007
	PROJECT
	SK RJ BY REVIEWED
SP-10	

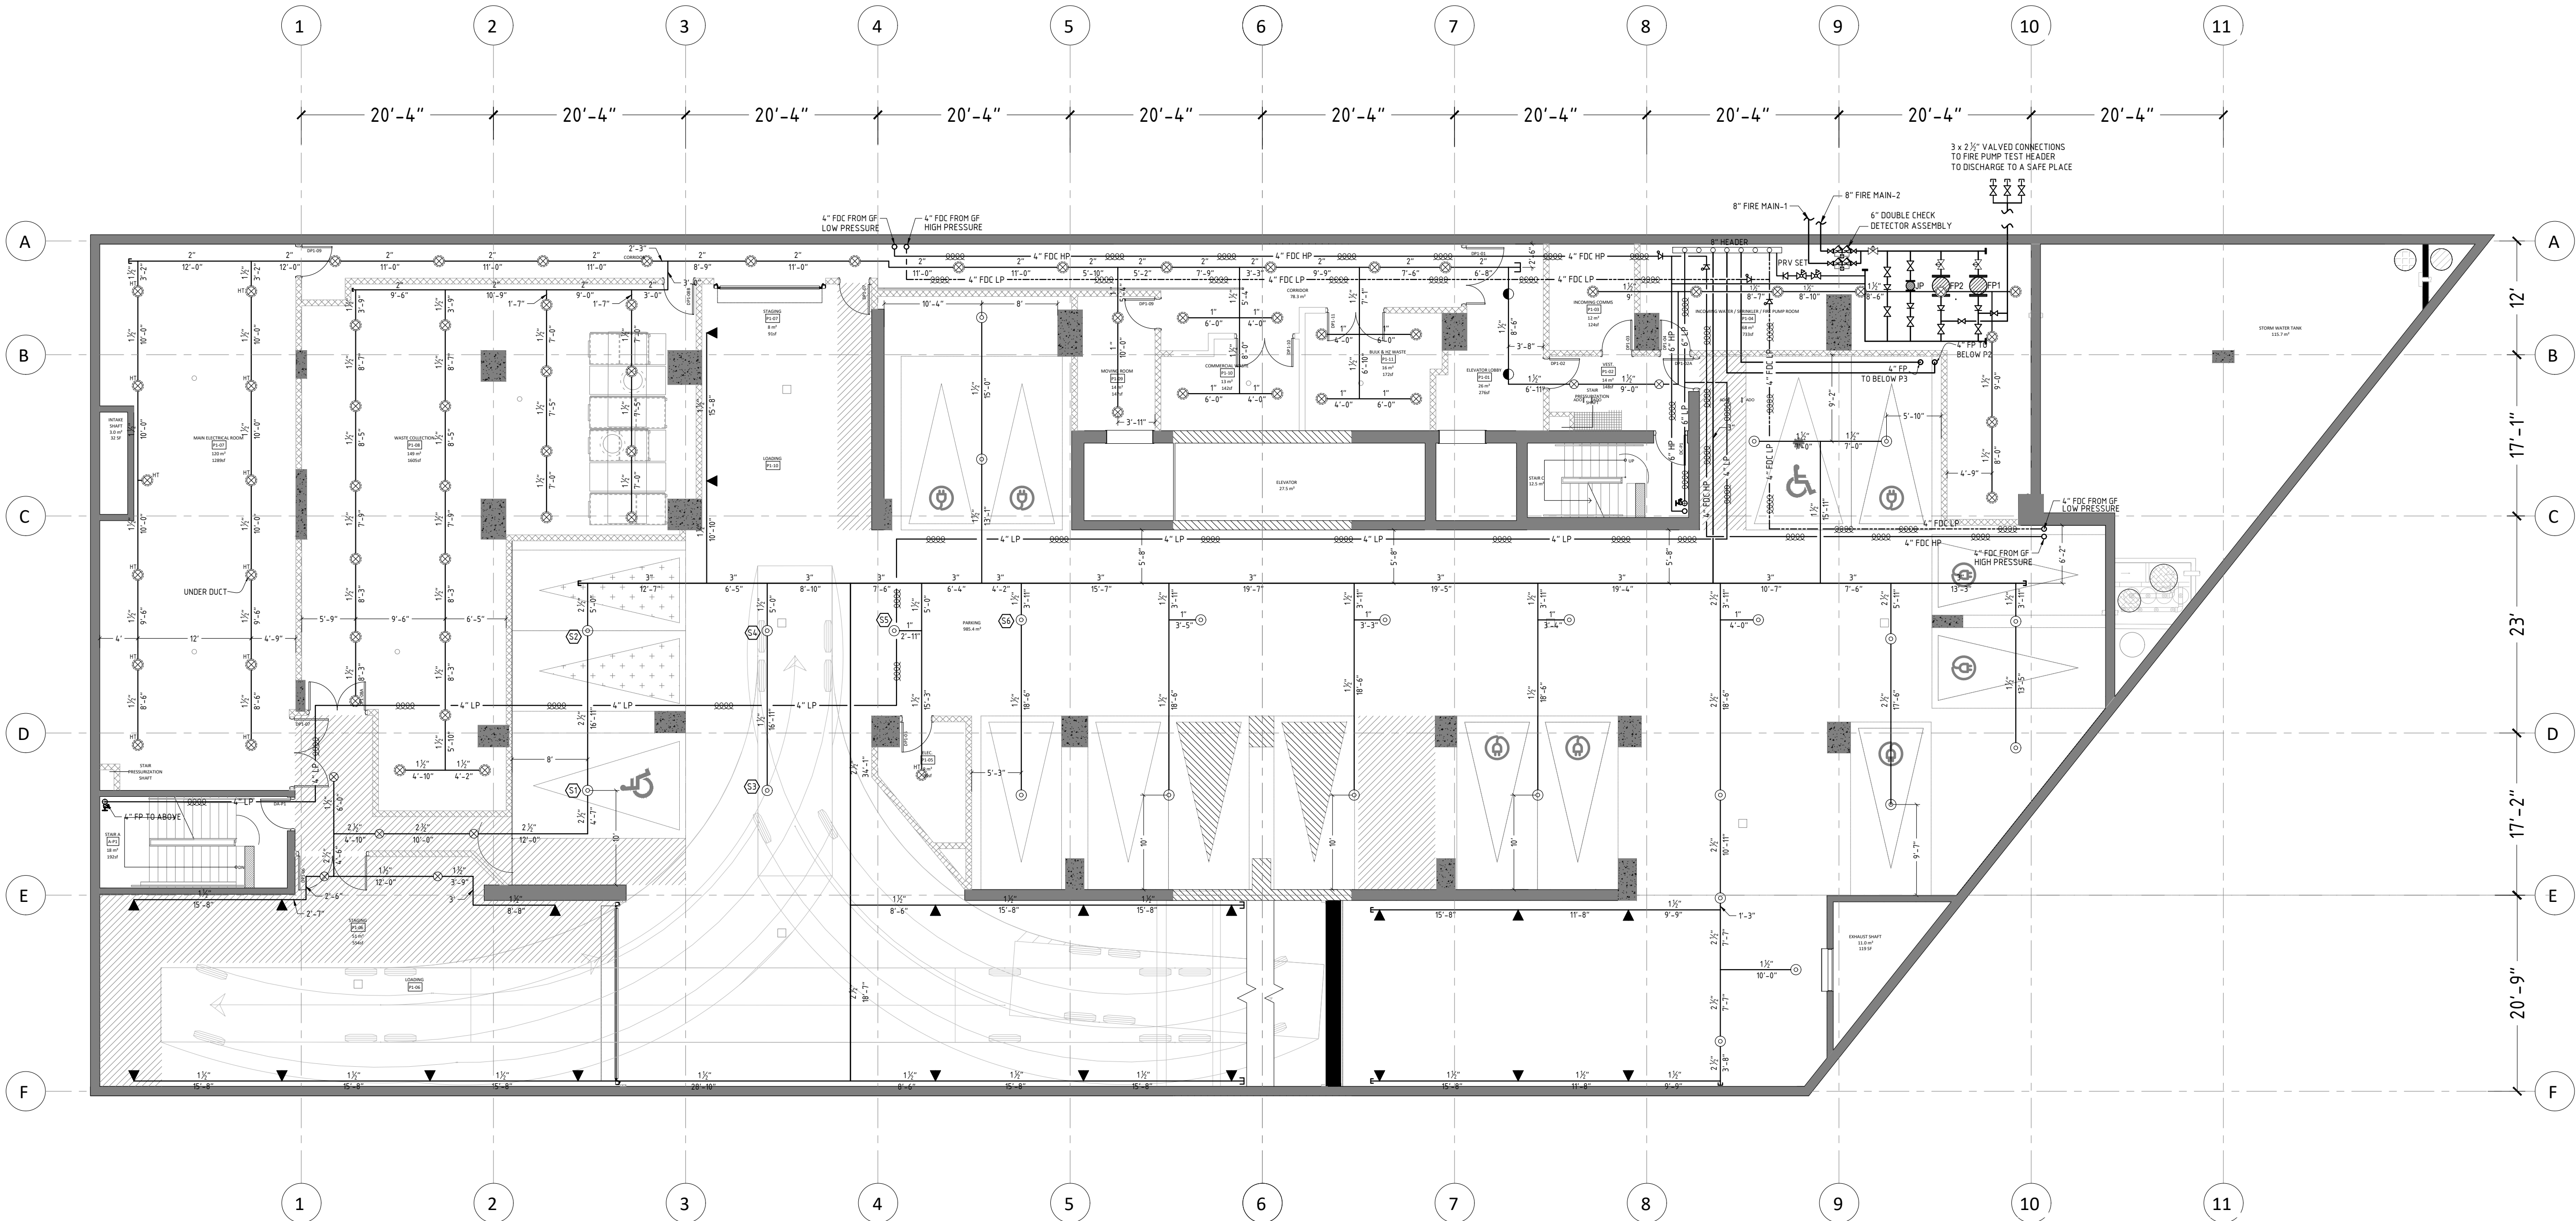

X	00	0000000000
NO	DATE	DESCRIPTION
ISSUED/REVISION RECORD		

SPRINKLER HEAD LEGEND

C/W GUARD				Q/R=QUICK RESPONSE E/C=EXTENDED COVERAGE	
S/R=STANDARD RESPONSE S/C=STANDARD COVERAGE					
	THREAD SIZE	K-FACTOR	TEMP RATING	STYLE/MODEL	RESPONSE
	1/2"	14	155°F	EXTENDED COVERAGE UPRIGHT	S/R
	1/2"	5.6	165°F	UPRIGHT S/C	S/R
	1/2"	5.6	165°F	DRY UPRIGHT SPRINKLER HEAD	Q/R
	1/2"	5.6	165°F	STANDARD COVERAGE UPRIGHT	Q/R
	1/2"	5.6	212°F	STANDARD COVERAGE UPRIGHT	Q/R
	1"	5.6	155°F	FULLY CONCEALED DRY PENDENT S/C	Q/R
	1"	5.6	165°F	DRY PENDENT S/C	Q/R
	1/2"	11.2	200°F	EXTENDED COVERAGE SIDEWALL	S/R
	1/2"	5.6	155°F	WINDOW SPRINKLER	Q/R
	1/2"	5.6	165°F	STANDARD COVERAGE SIDEWALL	Q/R
	1/2"	5.8	200°F	RESIDENTIAL FULLY CONCEALED PENDENT	Q/R
	1/2"	5.8	200°F	RESIDENTIAL FULLY CONCEALED SIDEWALL	Q/R
	1/2"	5.6	165°F	CONCEALED PENDENT S/C	Q/R
	1/2"	5.6	212°F	RESIDENTIAL FULLY CONCEALED PENDENT S/C	Q/R
	1/2"	8.0	286°F	UPRIGHT IN LOCKER ROOM S/C	S/R
	2 1/2" STANDARD FIRE HOSE VALVE C/W THREADED CAP IN STAIRWELL				
	2 1/2" FIRE HOSE VALVE IN CABINET C/W FIRE EXTINGUISHER				


REFERENCE TO ALTERNATIVE SOLUTION REPORT :
LOCATE 65 mm DIA FIRE HOSE VALE (FHV)
CONNECTIONS WITHIN THE EXIT STAIRS
ENCLOSURES, CLASS 1 STANDPIPE SYSTEM,
PORTABLE FIRE EXTINGUISHERS PROVIDED
THROUGHOUT THE FLOORS.


PROJECT


PROPOSED MIXED-USED DEVELOPMENT
ADDRESS:
775-783 Vaughan Rd & 670-680
Northcliffe Blvd, York, ON

DRAWING TITLE

UNDER GROUND PARKING LEVEL
P1- FIRE PROTECTION PLAN

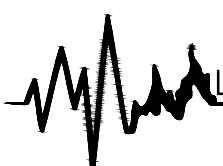 LIFELINE FIRE PROTECTION
www.lifelinefireprotection.com
50 Casimir Court, Concord, ON
L4K 4J5
(416)850-9477

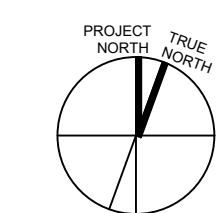	22-0007
	PROJECT
	SK RJ BY REVIEWED
SP-11	

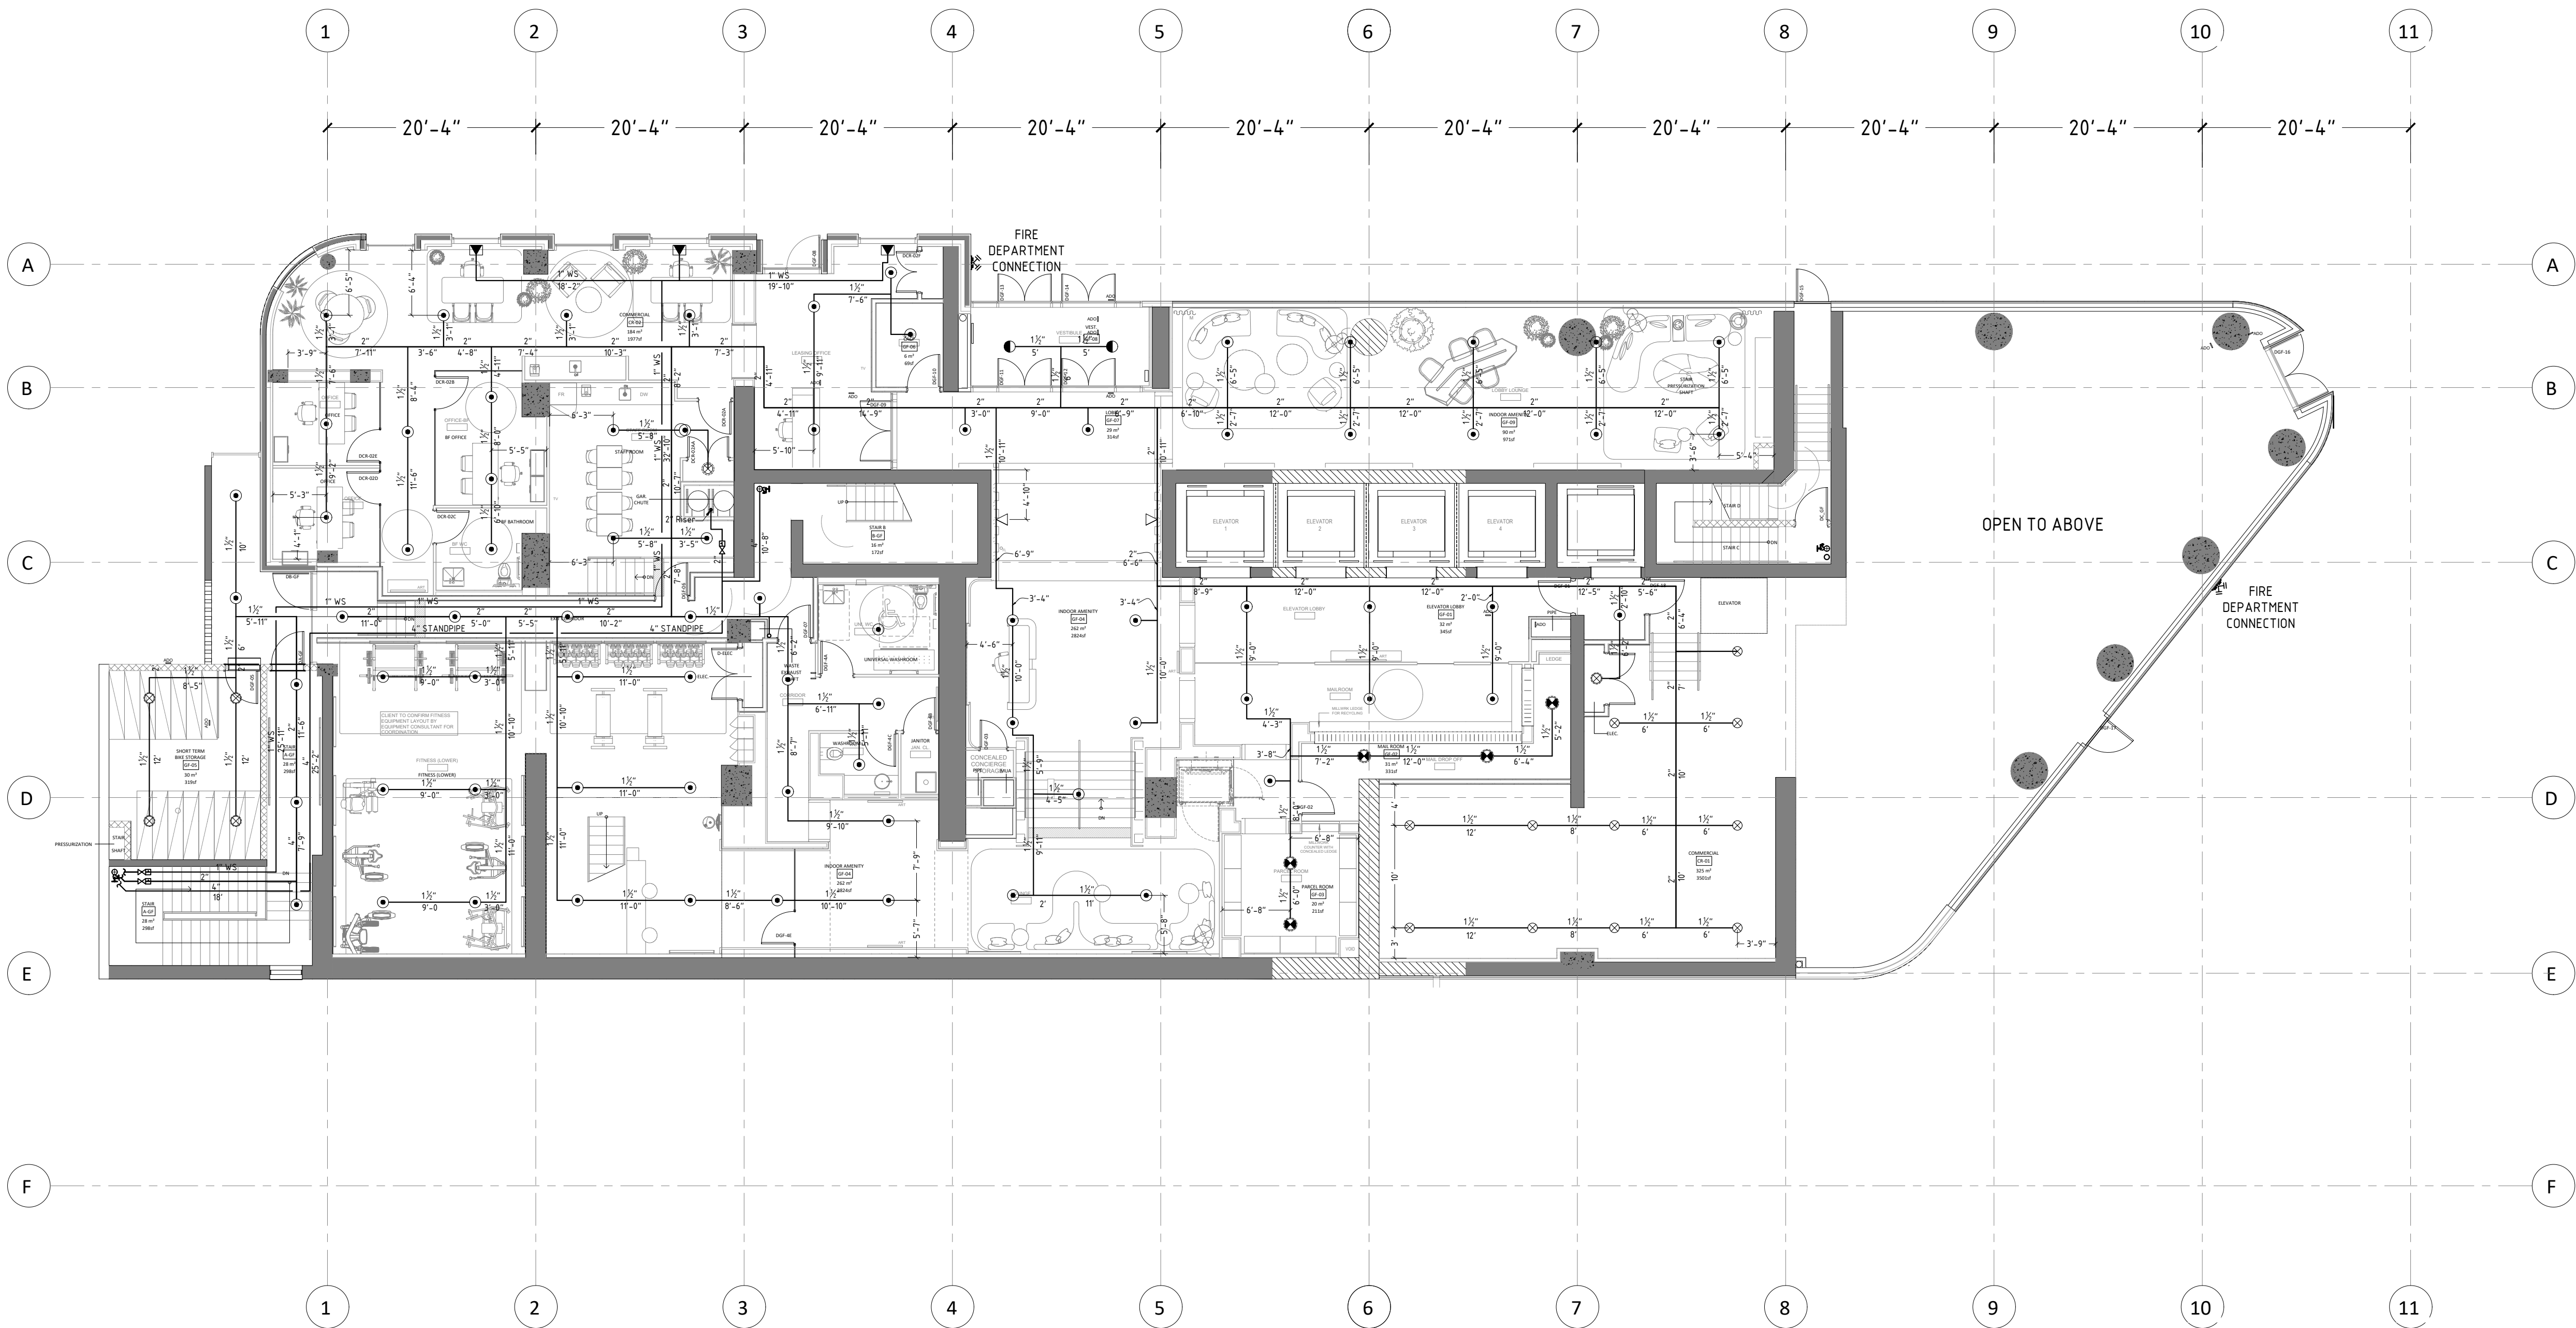

X	XX	XXXXXXXXXXXX
NO	DATE	DESCRIPTION
ISSUED/REVISION RECORD		

SPRINKLER HEAD LEGEND					
C / W GUARD					
S/R=STANDARD RESPONSE			Q/R=QUICK RESPONSE		
S/C=STANDARD COVERAGE			E/C=EXTENDED COVERAGE		
THREAD SIZE	K-FACTOR	TEMP RATING	STYLE(MODEL)	RESPONSE	
1/2"	14	155°	EXTENDED COVERAGE UPRIGHT	S/R	
1/2"	5.6	165°	UPRIGHT S/C	S/R	
1/2"	5.6	165°	DRY UPRIGHT SPRINKLER HEAD	Q/R	
1/2"	5.6	165°	STANDARD COVERAGE UPRIGHT	Q/R	
1/2"	5.6	212°	STANDARD COVERAGE UPRIGHT	Q/R	
1"	5.6	155°	FULLY CONCEALED DRY PENDENT S/C	Q/R	
1"	5.6	165°	DRY PENDENT S/C	Q/R	
1/2"	11.2	200°	EXTENDED COVERAGE SIDEWALL	S/R	
1/2"	5.6	155°	WINDOW SPRINKLER	Q/R	
1/2"	5.6	165°	STANDARD COVERAGE SIDEWALL	Q/R	
1/2"	5.8	200°	RESIDENTIAL FULLY CONCEALED PENDENT	Q/R	
1/2"	5.8	200°	RESIDENTIAL FULLY CONCEALED SIDEWALL	Q/R	
1/2"	5.6	165°	CONCEALED PENDENT S/C	Q/R	
1/2"	5.6	212°	RESIDENTIAL FULLY CONCEALED PENDENT S/C	Q/R	
1/2"	8.0	286°	UPRIGHT IN LOCKER ROOM S/C	S/R	
2 1/2" STANDARD FIRE HOSE VALVE					
C/W THREADED CAP IN STAIRWELL					
2 1/2" FIRE HOSE VALVE IN CABINET					
C/W FIRE EXTINGUISHER					


REFERENCE TO ALTERNATIVE SOLUTION REPORT :
LOCATE 65 mm DIA FIRE HOSE VALE (FHV)
CONNECTIONS WITHIN THE EXIT STAIRS
ENCLOSURES, CLASS 1 STANDPIPE SYSTEM,
PORTABLE FIRE EXTINGUISHERS PROVIDED
THROUGHOUT THE FLOORS.


PROJECT


PROPOSED MIXED-USED DEVELOPMENT
ADDRESS:
775-783 Vaughan Rd & 670-680
Northcliffe Blvd, York, ON

DRAWING TITLE

GROUND FLOOR
FIRE PROTECTION PLAN

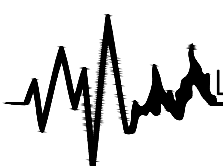 LIFELINE FIRE PROTECTION
www.lifelinefireprotection.com
50 Casimir Court, Concord, ON
L4K 4J5
(416)850-9477

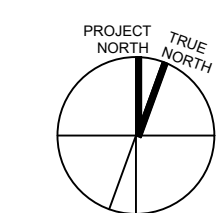PROJECT TRUE NORTH

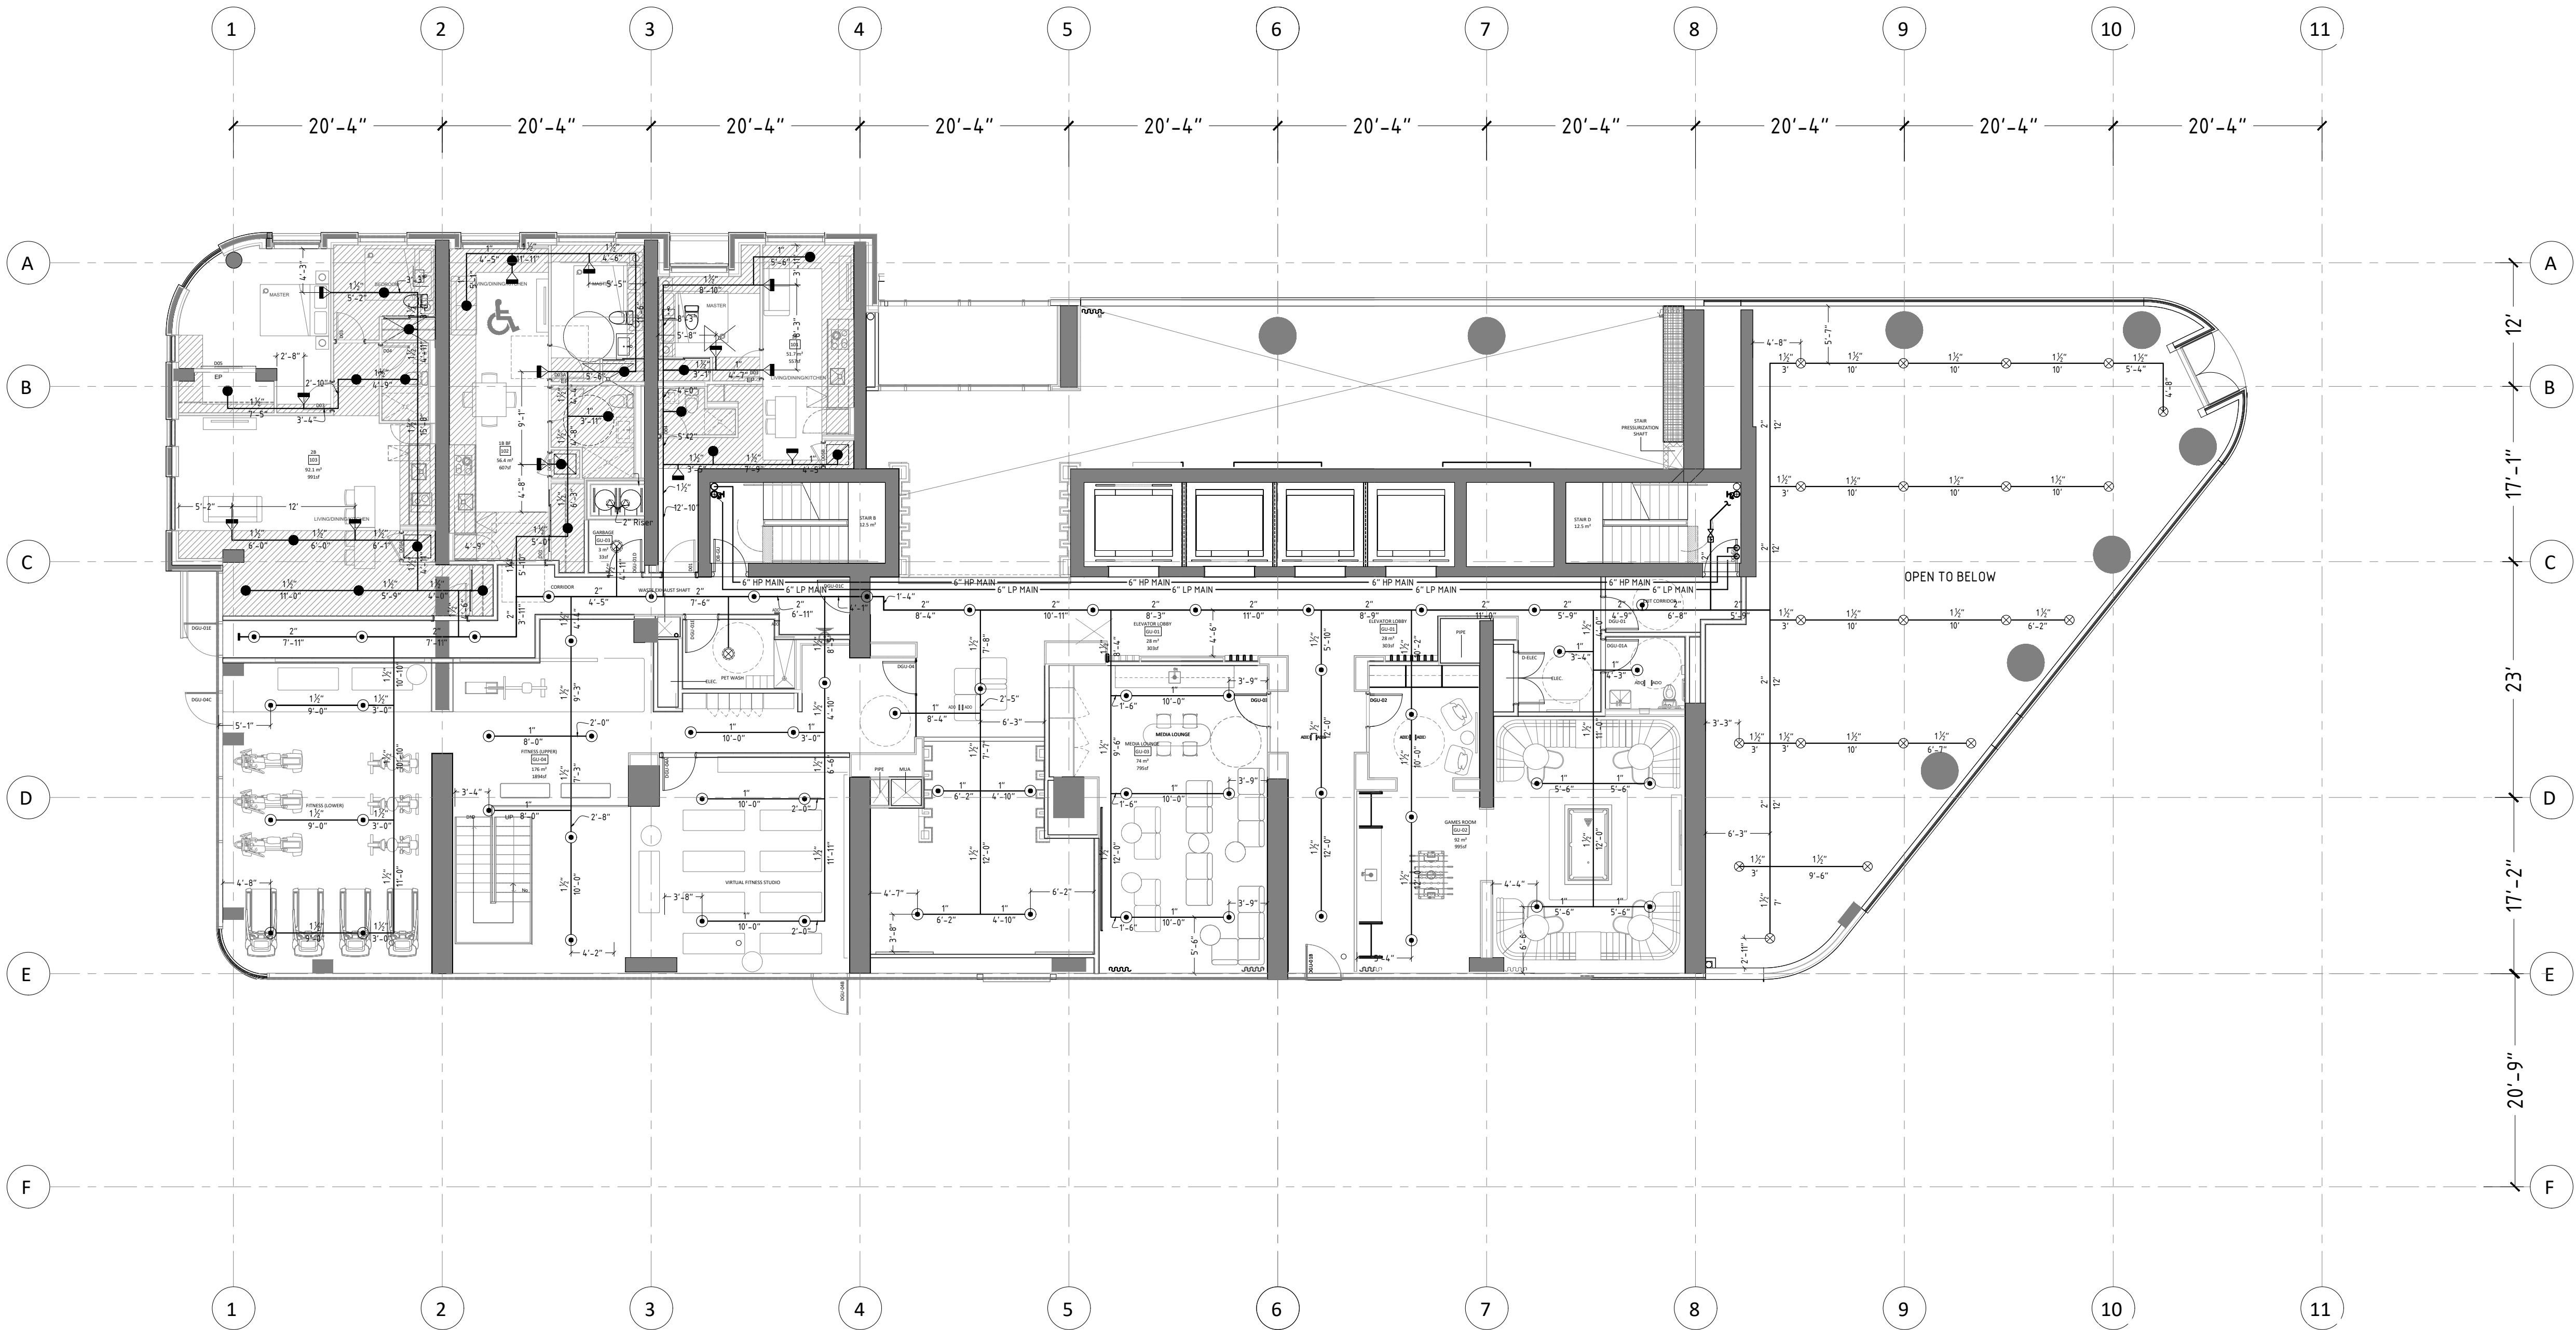22-0007
PROJECT
SK RJ
BY REVIEWED
SP-12



X	XX	XXXXXXXXXXXX
NO	DATE	DESCRIPTION
ISSUED/REVISION RECORD		

SPRINKLER HEAD LEGEND

S/R=STANDARD RESPONSE		C/W GUARD		Q/R=QUICK RESPONSE	
S/C=STANDARD COVERAGE				E/C=EXTENDED COVERAGE	
THREADED	K-F	TEMP	STYLE(MODEL)	RESPONSE	
SIZE	FACTOR	RATING	EXTENDED		
⊙	1/2"	14	155°F	COVERAGE UPRIGHT	S/R
○	1/2"	5.6	165°F	UPRIGHT S/C	S/R
⊗	1/2"	5.6	165°F	DRY UPRIGHT SPRINKLER HEAD	Q/R
⊗	1/2"	5.6	165°F	STANDARD COVERAGE UPRIGHT	Q/R
⊗	1/2"	5.6	212°F	STANDARD COVERAGE UPRIGHT	Q/R
⊗	1"	5.6	155°F	FULLY CONCEALED DRY PENDENT S/C	Q/R
⊗	1"	5.6	165°F	DRY PENDENT S/C	Q/R
⊗	1/2"	11.2	200°F	EXTENDED COVERAGE SIDEWALL	S/R
⊗	1/2"	5.6	155°F	WINDOW SPRINKLER	Q/R
⊗	1/2"	5.6	165°F	STANDARD COVERAGE SIDEWALL	Q/R
⊗	1/2"	5.8	200°F	RESIDENTIAL FULLY CONCEALED PENDENT	Q/R
⊗	1/2"	5.8	200°F	RESIDENTIAL FULLY CONCEALED SIDEWALL	Q/R
⊗	1/2"	5.6	165°F	CONCEALED PENDENT S/C	Q/R
⊗	1/2"	5.6	212°F	RESIDENTIAL FULLY CONCEALED PENDENT S/C	Q/R
⊗	1/2"	8.0	286°F	UPRIGHT IN LOCKER ROOM S/C	S/R
⊗	2 1/2" STANDARD FIRE HOSE VALVE				
⊗	C/W THREADED CAP IN STAIRWELL				
⊗	2 1/2" FIRE HOSE VALVE IN CABINET				
⊗	C/W FIRE EXTINGUISHER				


REFERENCE TO ALTERNATIVE SOLUTION REPORT :
LOCATE 65 mm DIA FIRE HOSE VALE (FHV)
CONNECTIONS WITHIN THE EXIT STAIRS
ENCLOSURES, CLASS 1 STANDPIPE SYSTEM,
PORTABLE FIRE EXTINGUISHERS PROVIDED
THROUGHOUT THE FLOORS.


PROJECT

PROPOSED MIXED-USED DEVELOPMENT
ADDRESS:
775-783 Vaughan Rd & 670-680
Northcliffe Blvd, York, ON

DRAWING TITLE

UPPER GROUND FLOOR
FIRE PROTECTION PLAN

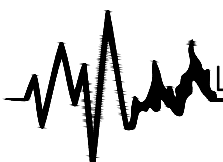 LIFELINE FIRE PROTECTION
www.lifelinefireprotection.com
50 Casimir Court, Concord, ON
L4K 4J5
(416)850-9477

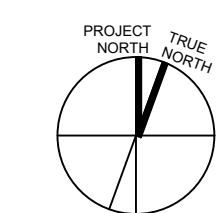PROJECT TRUE NORTH

22-0007
PROJECT
SK RJ
BY REVIEWED
SP-13



REFERENCE TO ALTERNATIVE SOLUTION REPORT :
LOCATE 65 mm DIA FIRE HOSE VALE (FHV)
CONNECTIONS WITHIN THE EXIT STAIRS
ENCLOSURES. CLASS 1 STANDPIPE SYSTEM.
PORTABLE FIRE EXTINGUISHERS PROVIDED
THROUGHOUT THE FLOORS.


PROJECT


PROPOSED MIXED-USED DEVELOPMENT

ADDRESS:
775-783 Vaughan Rd & 670-680
Northcliffe Blvd, York, ON

DRAWING TITLE

2ND FLOOR
FIRE PROTECTION PLAN

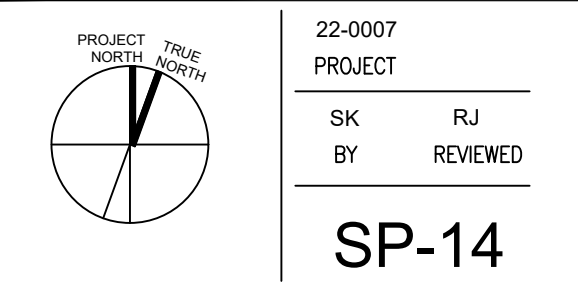

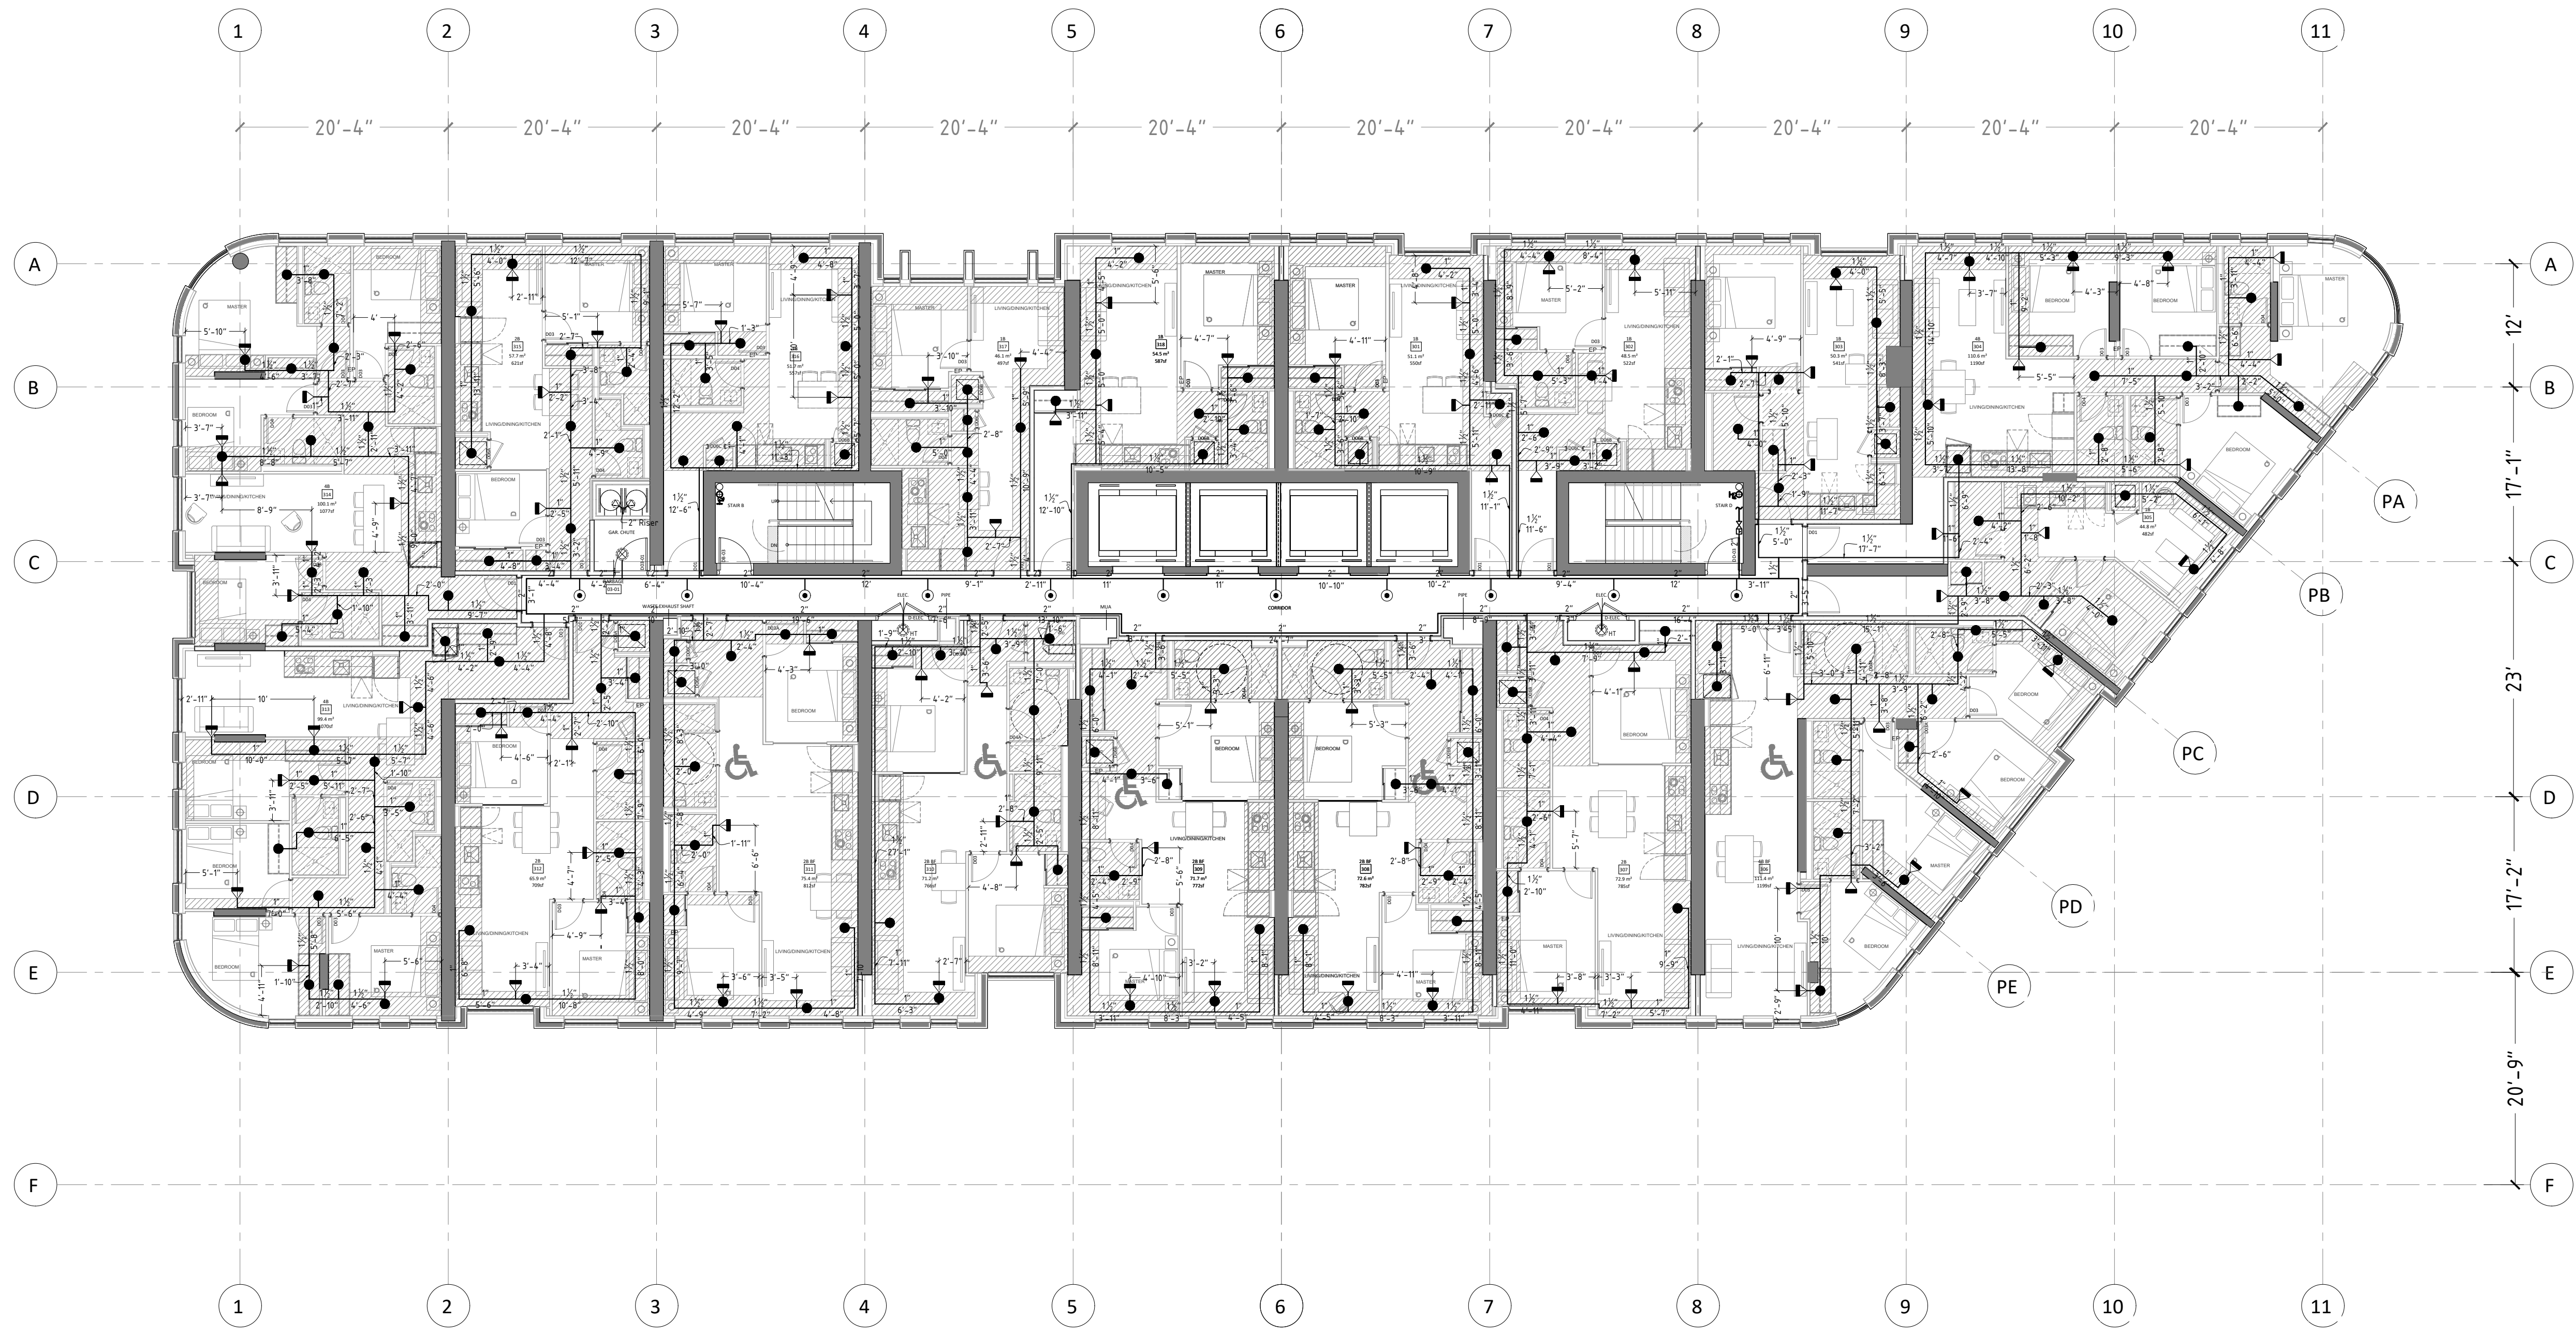

X		000	XXXXXXXXXXXX
NO		DATE	DESCRIPTION
ISSUED/REVISION RECORD			
SPRINKLER HEAD LEGEND			
S/R=STANDARD RESPONSE S/C=STANDARD COVERAGE			
Q/R=QUICK RESPONSE E/C=EXTENDED COVERAGE			
THREADED	K	TEMP	STYLE/MODEL
SIZE	FACTOR	RATING	EXTENDED COVERAGE UPRIGHT
1/2"	14	155°F	UPRIGHT S/C
1/2"	5.6	165°F	UPRIGHT SPRINKLER HEAD
1/2"	5.6	165°F	STANDARD COVERAGE UPRIGHT
1/2"	5.6	212°F	STANDARD COVERAGE UPRIGHT
1"	5.6	155°F	FULLY CONCEALED DRY PENDENT S/C
1"	5.6	165°F	DRY PENDENT S/C
1/2"	11.2	200°F	EXTENDED COVERAGE SIDEWALL
1/2"	5.6	155°F	WINDOW SPRINKLER
1/2"	5.6	165°F	STANDARD COVERAGE SIDEWALL
1/2"	5.8	200°F	RESIDENTIAL FULLY CONCEALED PENDENT
1/2"	5.8	200°F	RESIDENTIAL FULLY CONCEALED SIDEWALL
1/2"	5.6	165°F	CONCEALED PENDENT S/C
1/2"	5.6	212°F	RESIDENTIAL FULLY CONCEALED PENDENT S/C
1/2"	8.0	286°F	UPRIGHT IN LOCKER ROOM S/C
2 1/2"	STANDARD FIRE HOSE VALVE		
2 1/2"	FIRE HOSE VALVE IN CABINET		
1/2"	THREADED CAP IN STAIRWELL		
1/2"	FIRE EXTINGUISHER		

REFERENCE TO ALTERNATIVE SOLUTION REPORT :
LOCATE 65 mm DIA FIRE HOSE VALL (FHV)
CONNECTIONS WITHIN THE EXIT STAIRS
ENCLOSURES CLASS 1 STANDPIPE SYSTEM
PORTABLE FIRE EXTINGUISHERS PROVIDED
THROUGHOUT THE FLOORS.

PROJECT


PROPOSED MIXED-USED DEVELOPMENT
ADDRESS:
775-783 Vaughan Rd & 670-680
Northcliffe Blvd, York, ON

DRAWING TITLE

3RD - 5TH FLOOR
FIRE PROTECTION PLAN

 LIFELINE FIRE PROTECTION
www.lifelinefireprotection.com
50 Casimir Court, Concord, ON
L4K 4J5
(416)850-9477

PROJECT TRUE NORTH
22-0007
PROJECT
SK RJ
BY REVIEWED
SP-15

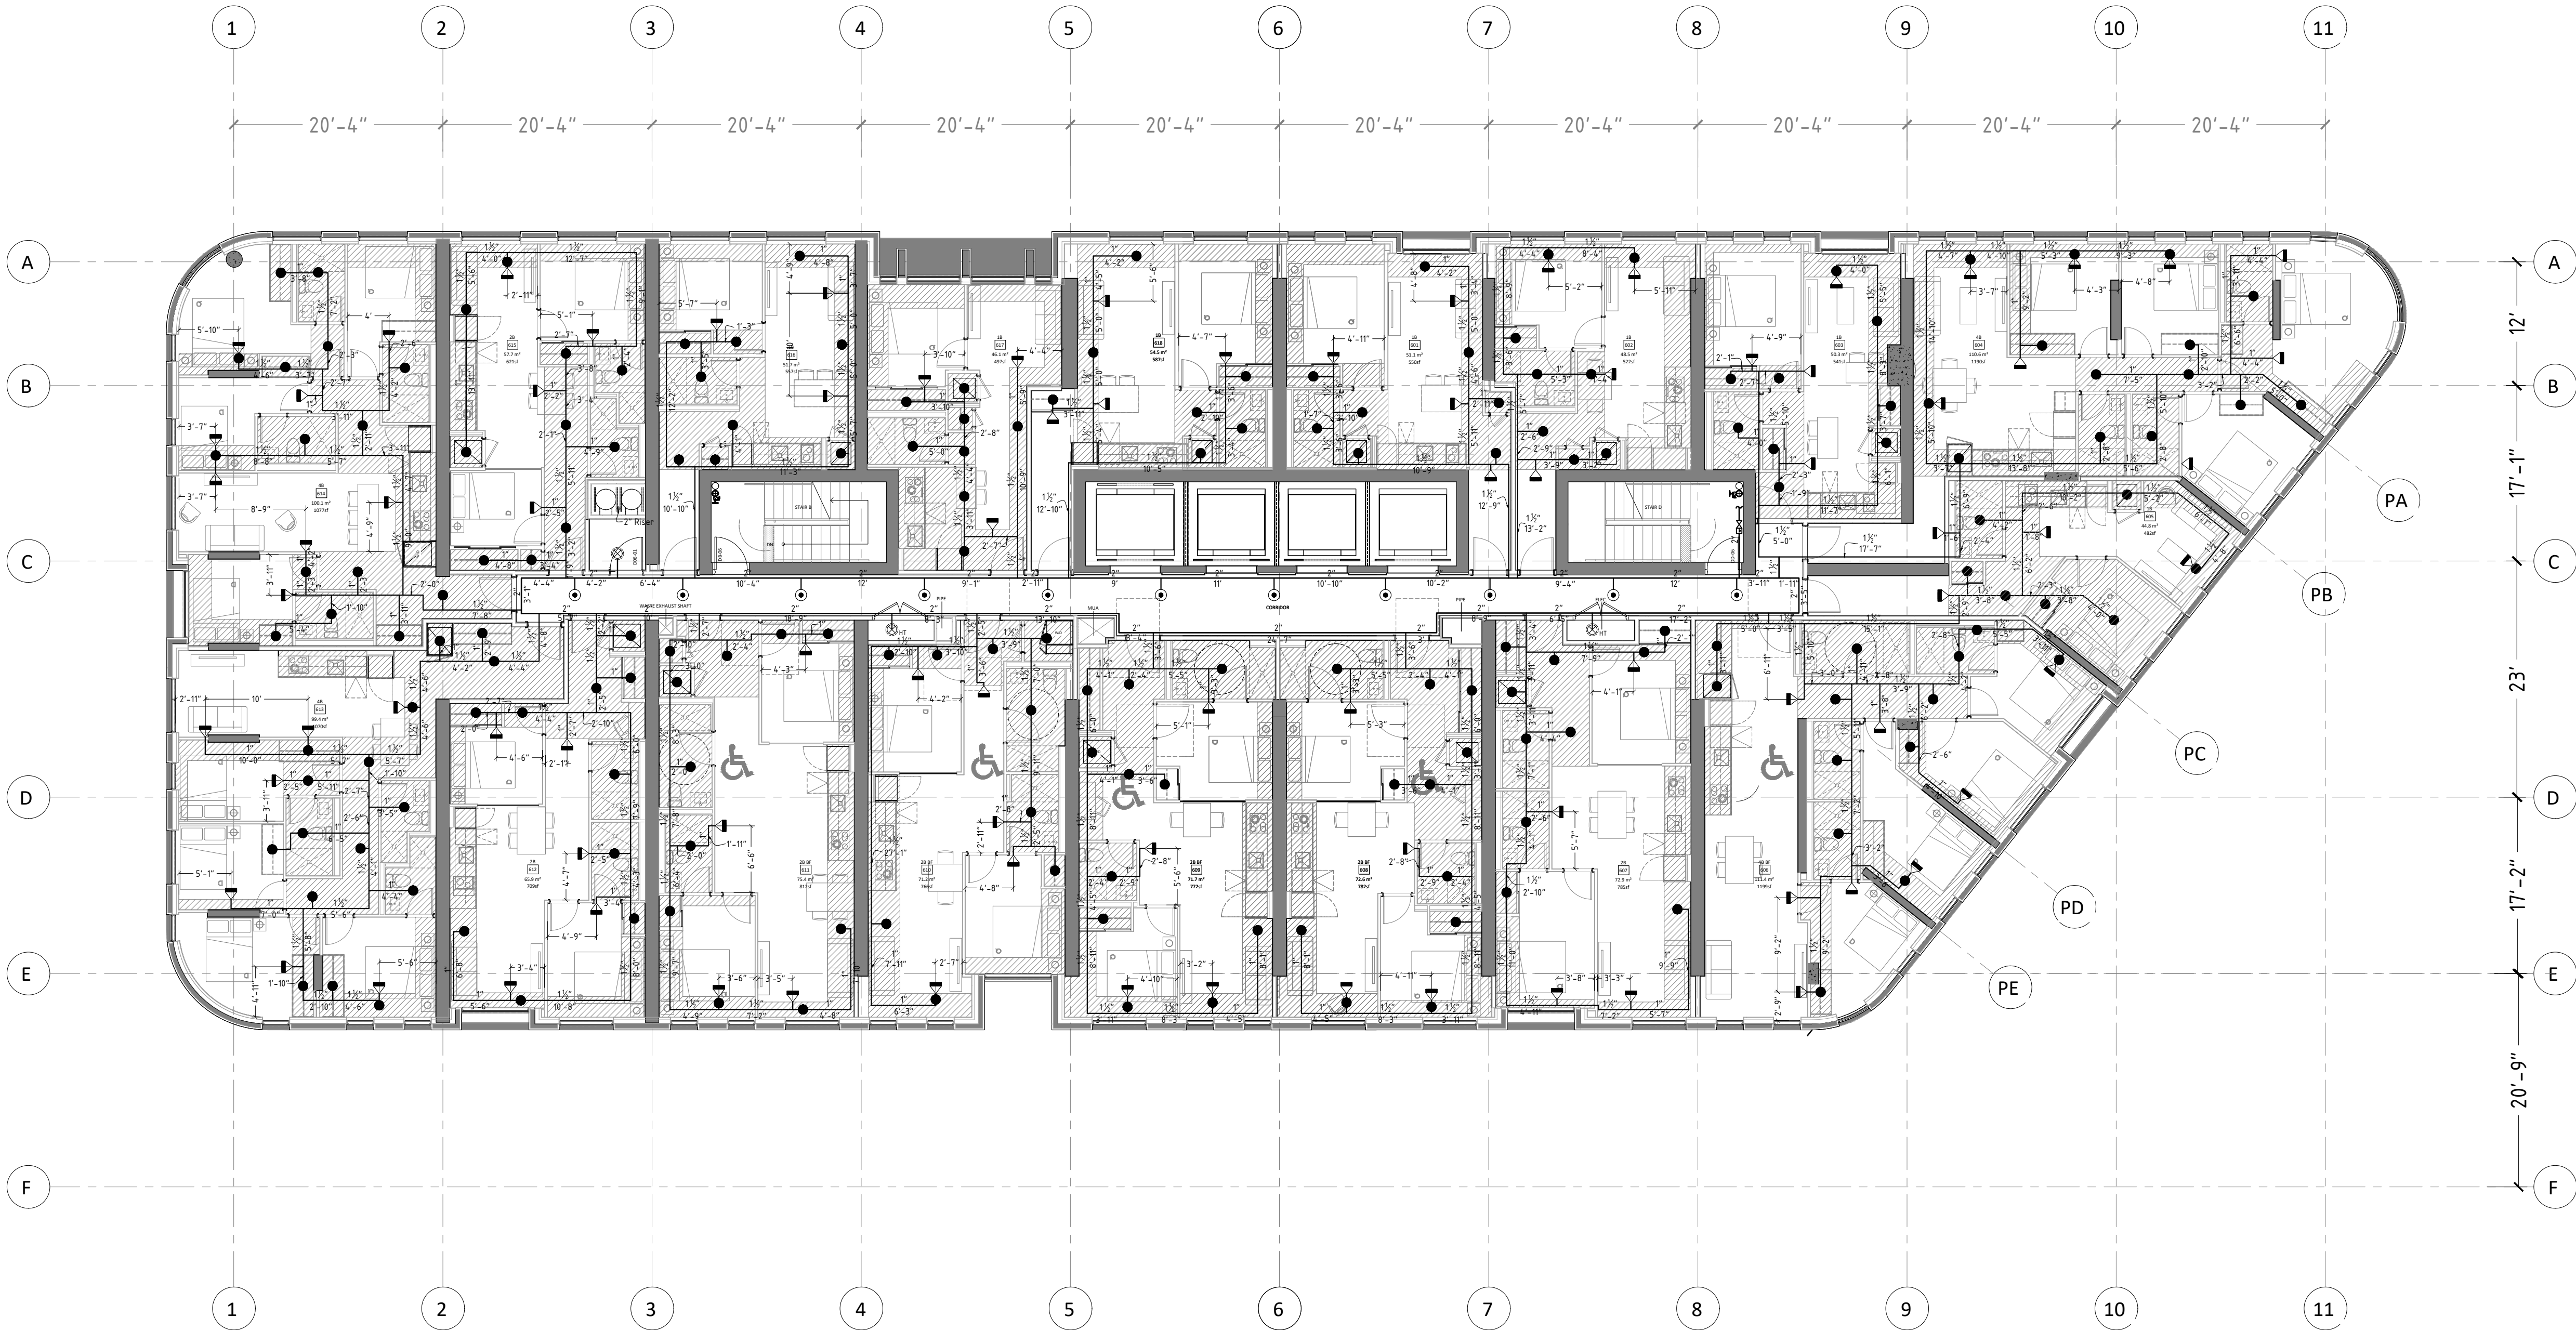

X	00	0000000000
NO	DATE	DESCRIPTION
ISSUED/REVISION RECORD		

SPRINKLER HEAD LEGEND				
C/W GUARD				
S/R=STANDARD RESPONSE		Q/R=QUICK RESPONSE		
S/C=STANDARD COVERAGE		E/C=EXTENDED COVERAGE		
SYMBOL	THREAD SIZE	K-FACTOR	TEMP RATING	RESPONSE
⊙	1/2"	14	155°F	EXTENDED COVERAGE UPRIGHT
○	1/2"	5.6	165°F	UPRIGHT S/C
⊗	1/2"	5.6	165°F	DRY UPRIGHT SPRINKLER HEAD
⊙	1/2"	5.6	165°F	STANDARD COVERAGE UPRIGHT
⊗	1/2"	5.6	212°F	STANDARD COVERAGE UPRIGHT
⊙	1"	5.6	155°F	FULLY CONCEALED DRY PENDENT S/C
⊗	1"	5.6	165°F	DRY PENDENT S/C
⊙	1/2"	11.2	200°F	EXTENDED COVERAGE SIDEWALL
⊗	1/2"	5.6	155°F	WINDOW SPRINKLER
⊙	1/2"	5.6	165°F	STANDARD COVERAGE SIDEWALL
⊗	1/2"	5.8	200°F	RESIDENTIAL FULLY CONCEALED PENDENT
⊙	1/2"	5.8	200°F	RESIDENTIAL FULLY CONCEALED PENDENT
⊗	1/2"	5.6	165°F	CONCEALED PENDENT S/C
⊙	1/2"	5.6	212°F	RESIDENTIAL FULLY CONCEALED PENDENT S/C
⊗	1/2"	8.0	286°F	UPRIGHT IN LOCKER ROOM S/C
⊙	2 1/2" STANDARD FIRE HOSE VALVE			
⊗	2 1/2" FIRE HOSE VALVE IN CABINET			
⊙	C/W FIRE EXTINGUISHER			


REFERENCE TO ALTERNATIVE SOLUTION REPORT :
LOCATE 65 mm DIA FIRE HOSE VALL (FHV)
CONNECTIONS WITHIN THE EXIT STAIRS
ENCLOSURES CLASS 1 STANDPIPE SYSTEM
PORTABLE FIRE EXTINGUISHERS PROVIDED
THROUGHOUT THE FLOORS.


PROJECT


PROPOSED MIXED-USED DEVELOPMENT
ADDRESS:
775-783 Vaughan Rd & 670-680
Northcliffe Blvd, York, ON

DRAWING TITLE

6TH FLOOR
FIRE PROTECTION PLAN

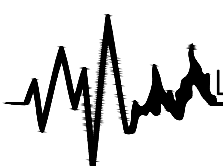 LIFELINE FIRE PROTECTION
www.lifelinefireprotection.com
50 Casimir Court, Concord, ON
L4K 4J5
(416)850-9477

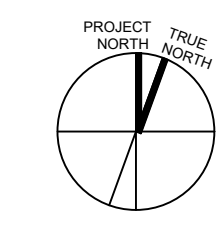PROJECT TRUE NORTH

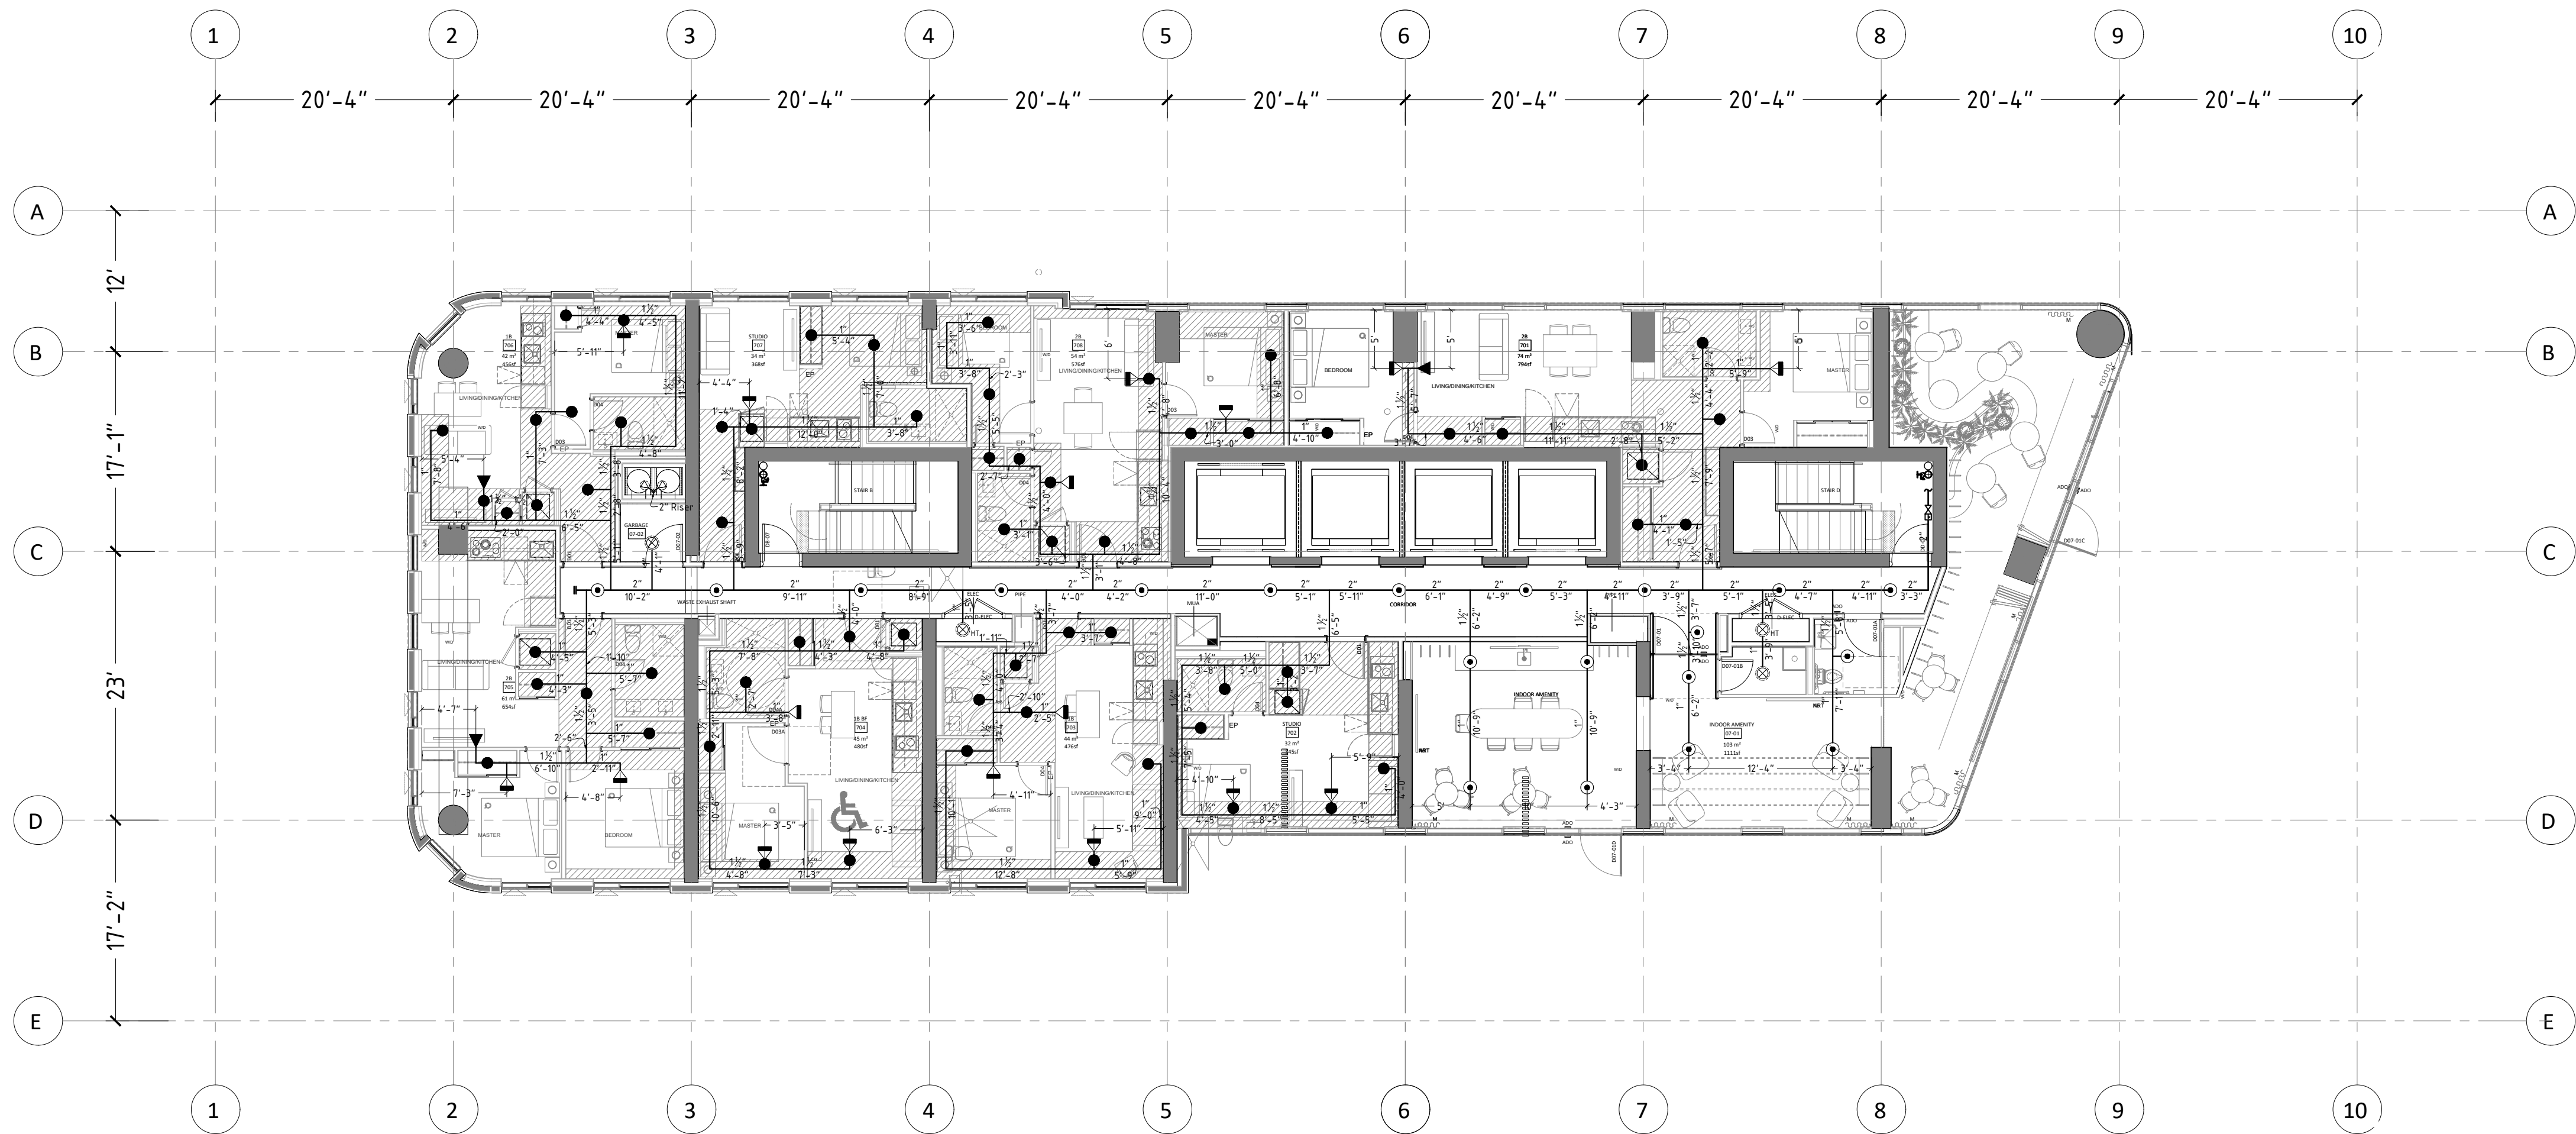22-0007
PROJECT
SK RJ
BY REVIEWED
SP-16



X	00	XXXXXXXXXX
NO	DATE	DESCRIPTION
ISSUED/REVISION RECORD		

SPRINKLER HEAD LEGEND

C/W GUARD					
S/R=STANDARD RESPONSE				Q/R=QUICK RESPONSE	
S/C=STANDARD COVERAGE				E/C=EXTENDED COVERAGE	
THREADED SIZE	K-FACTOR	TEMP RATING	STYLE/MODEL	RESPONSE	
⊙	1/2"	14	155°F	EXTENDED COVERAGE UPRIGHT	S/R
○	1/2"	5.6	165°F	UPRIGHT S/C	S/R
⊗	1/2"	5.6	165°F	DRY UPRIGHT SPRINKLER HEAD	Q/R
⊗	1/2"	5.6	165°F	STANDARD COVERAGE UPRIGHT	Q/R
⊗	1/2"	5.6	212°F	STANDARD COVERAGE UPRIGHT	Q/R
⊗	1"	5.6	155°F	FULLY CONCEALED DRY PENDENT S/C	Q/R
⊗	1"	5.6	165°F	DRY PENDENT S/C	Q/R
⊗	1/2"	11.2	200°F	EXTENDED COVERAGE SIDEWALL	S/R
⊗	1/2"	5.6	155°F	WINDOW SPRINKLER	Q/R
⊗	1/2"	5.6	165°F	STANDARD COVERAGE SIDEWALL	Q/R
⊗	1/2"	5.8	200°F	RESIDENTIAL FULLY CONCEALED PENDENT	Q/R
⊗	1/2"	5.8	200°F	RESIDENTIAL FULLY CONCEALED SIDEWALL	Q/R
⊗	1/2"	5.6	165°F	CONCEALED PENDENT S/C	Q/R
⊗	1/2"	5.6	212°F	RESIDENTIAL FULLY CONCEALED PENDENT S/C	Q/R
⊗	1/2"	8.0	286°F	UPRIGHT IN LOCKER ROOM S/C	S/R
2 1/2" STANDARD FIRE HOSE VALVE					
C/W THREADED CAP IN STAIRWELL					
2 1/2" FIRE HOSE VALVE IN CABINET					
C/W FIRE EXTINGUISHER					


REFERENCE TO ALTERNATIVE SOLUTION REPORT :
LOCATE 65 mm DIA FIRE HOSE VALE (FHV)
CONNECTIONS WITHIN THE EXIT STAIRS
ENCLOSURES, CLASS 1 STANDPIPE SYSTEM,
PORTABLE FIRE EXTINGUISHERS PROVIDED
THROUGHOUT THE FLOORS.


PROJECT


PROPOSED MIXED-USED DEVELOPMENT
ADDRESS:
775-783 Vaughan Rd & 670-680
Northcliffe Blvd, York, ON

DRAWING TITLE

7TH FLOOR
FIRE PROTECTION PLAN

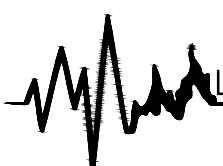 LIFELINE FIRE PROTECTION
www.lifelinefireprotection.com
50 Casimir Court, Concord, ON
L4K 4J5
(416)850-9477

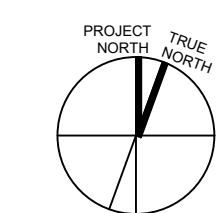	22-0007
	PROJECT
	SK RJ BY REVIEWED
SP-17	

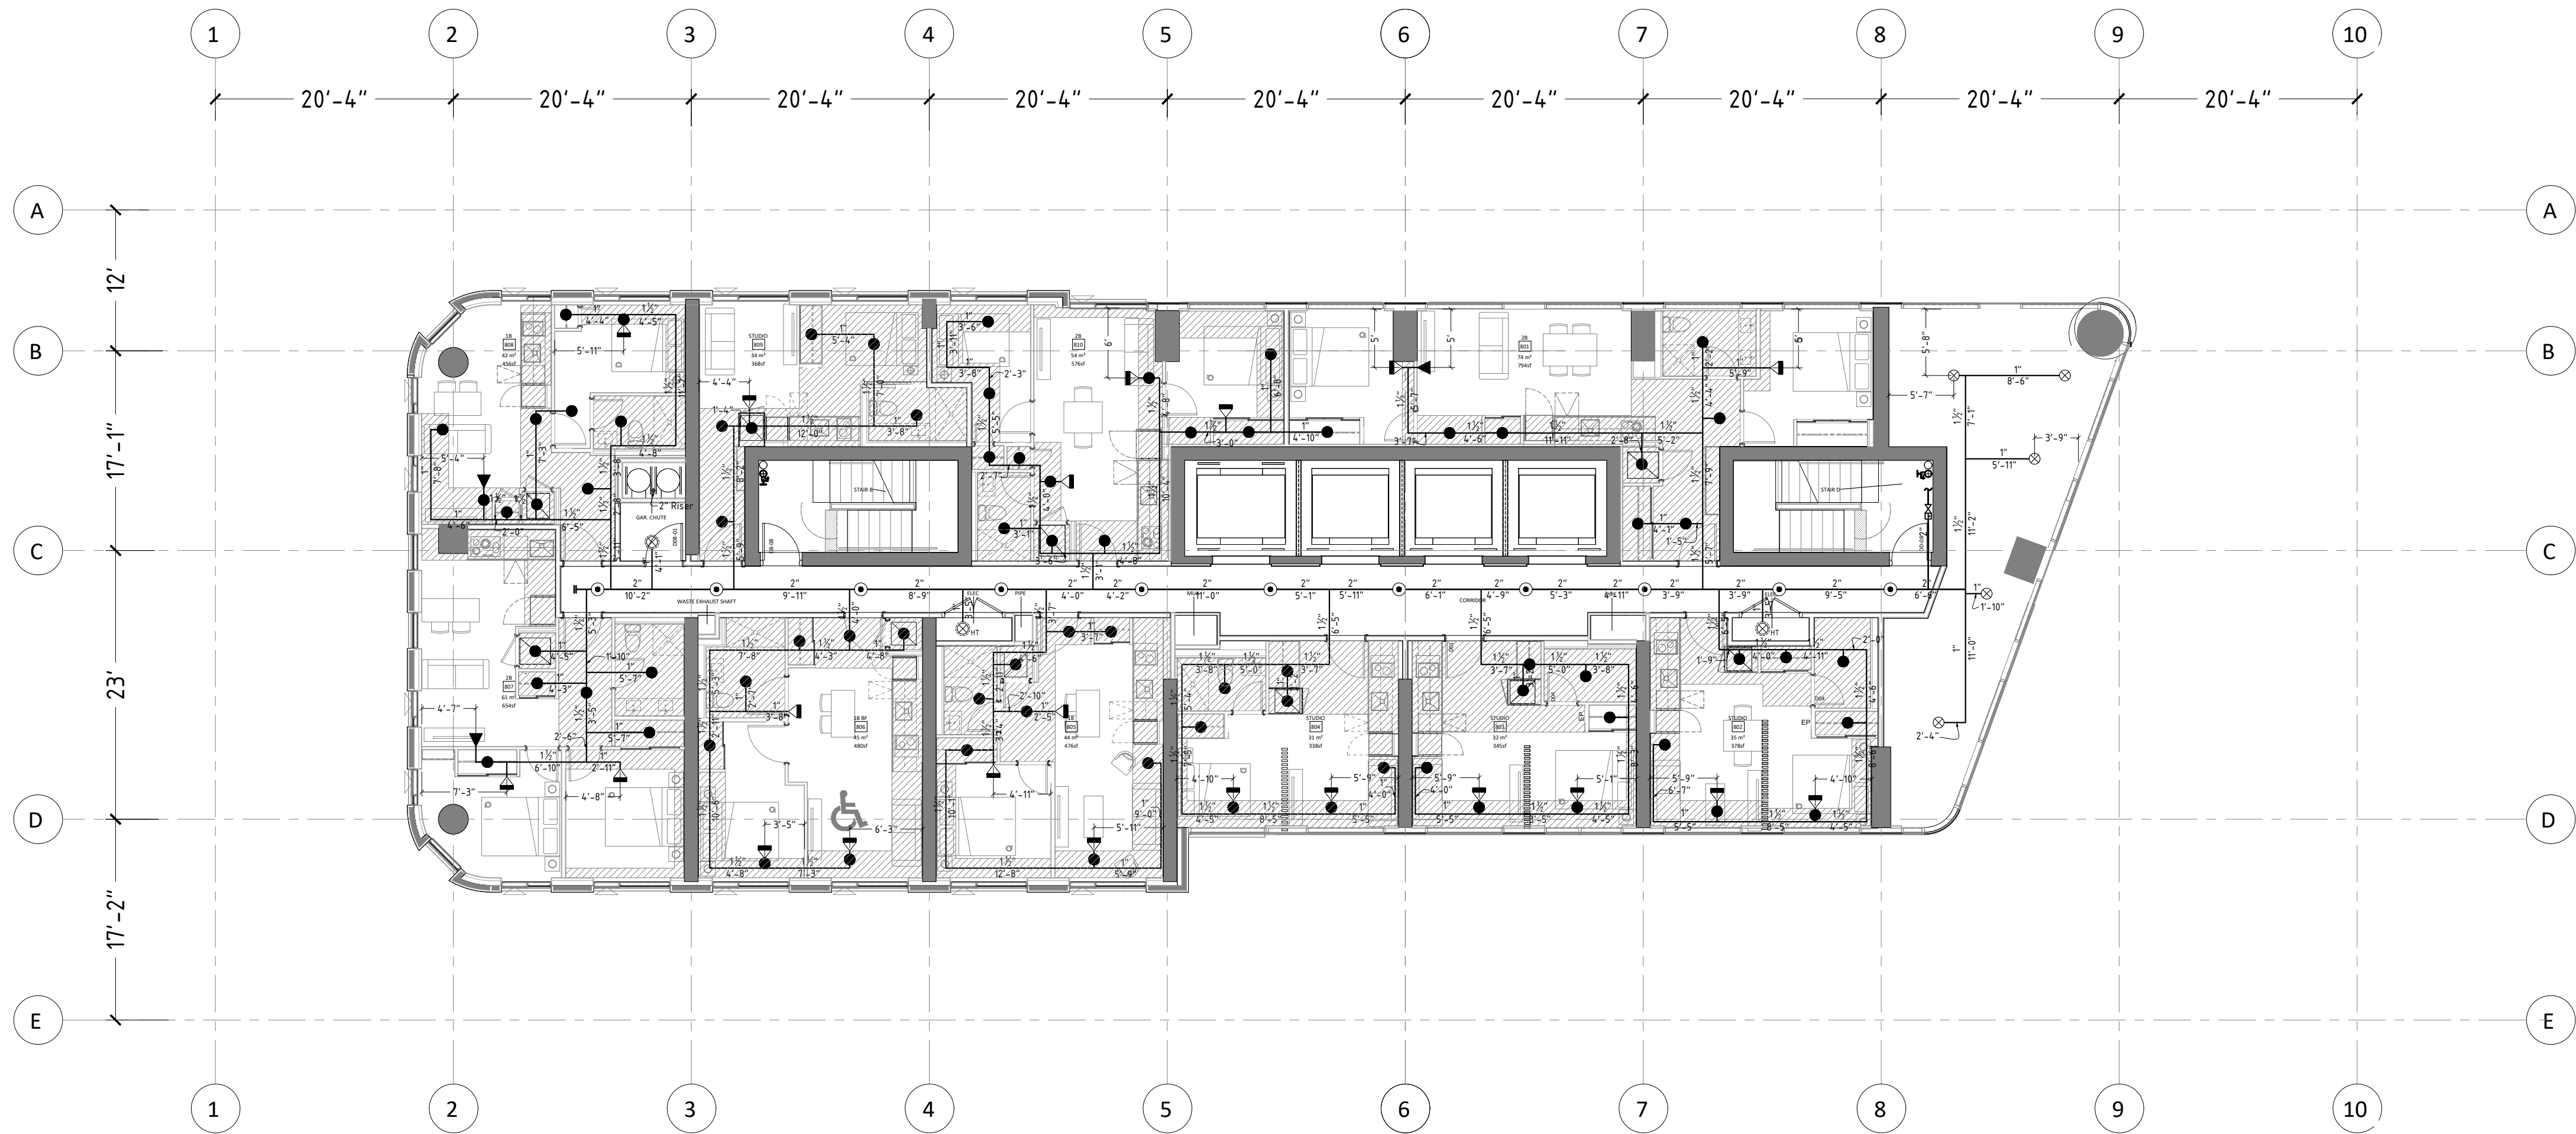

X	00	XXXXXXXXXXXX
NO	DATE	DESCRIPTION
ISSUED/REVISION RECORD		

SPRINKLER HEAD LEGEND					
C / W GUARD					
S/R=STANDARD RESPONSE			Q/R=QUICK RESPONSE		
S/C=STANDARD COVERAGE			E/C=EXTENDED COVERAGE		
	THREADED SIZE	K-FACTOR	TEMP RATING	STYLE(MODEL)	RESPONSE
⊙	1/2"	14	155°F	EXTENDED COVERAGE UPRIGHT	S/R
○	1/2"	5.6	165°F	UPRIGHT S/C	S/R
⊗	1/2"	5.6	165°F	DRY UPRIGHT SPRINKLER HEAD	Q/R
⊙	1/2"	5.6	165°F	STANDARD COVERAGE UPRIGHT	Q/R
⊗	1/2"	5.6	212°F	STANDARD COVERAGE UPRIGHT	Q/R
⊙	1"	5.6	155°F	FULLY CONCEALED DRY PENDENT S/C	Q/R
⊗	1"	5.6	165°F	DRY PENDENT S/C	Q/R
⊙	1/2"	11.2	200°F	EXTENDED COVERAGE SIDEWALL	S/R
⊗	1/2"	5.6	155°F	WINDOW SPRINKLER	Q/R
⊙	1/2"	5.6	165°F	STANDARD COVERAGE SIDEWALL	Q/R
⊗	1/2"	5.8	200°F	RESIDENTIAL FULLY CONCEALED PENDENT	Q/R
⊙	1/2"	5.8	200°F	RESIDENTIAL FULLY CONCEALED SIDEWALL	Q/R
⊗	1/2"	5.6	165°F	CONCEALED PENDENT S/C	Q/R
⊙	1/2"	5.6	212°F	RESIDENTIAL FULLY CONCEALED PENDENT S/C	Q/R
⊗	1/2"	8.0	286°F	UPRIGHT IN LOCKER ROOM S/C	S/R
2 1/2" STANDARD FIRE HOSE VALVE					
C/W THREADED CAP IN STAIRWELL					
2 1/2" FIRE HOSE VALVE IN CABINET					
C/W FIRE EXTINGUISHER					


REFERENCE TO ALTERNATIVE SOLUTION REPORT :
LOCATE 65 mm DIA FIRE HOSE VALE (FHV)
CONNECTIONS WITHIN THE EXIT STAIRS
ENCLOSURES, CLASS 1 STANDPIPE SYSTEM,
PORTABLE FIRE EXTINGUISHERS PROVIDED
THROUGHOUT THE FLOORS.


PROJECT


PROPOSED MIXED-USED DEVELOPMENT
ADDRESS:
775-783 Vaughan Rd & 670-680
Northcliffe Blvd, York, ON

DRAWING TITLE

8TH FLOOR
FIRE PROTECTION PLAN

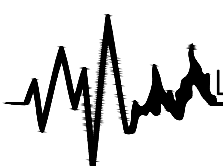 LIFELINE FIRE PROTECTION
www.lifelinefireprotection.com
50 Casimir Court, Concord, ON
L4K 4J5
(416)850-9477

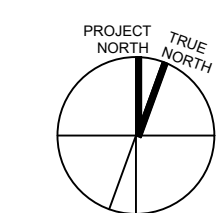PROJECT TRUE NORTH

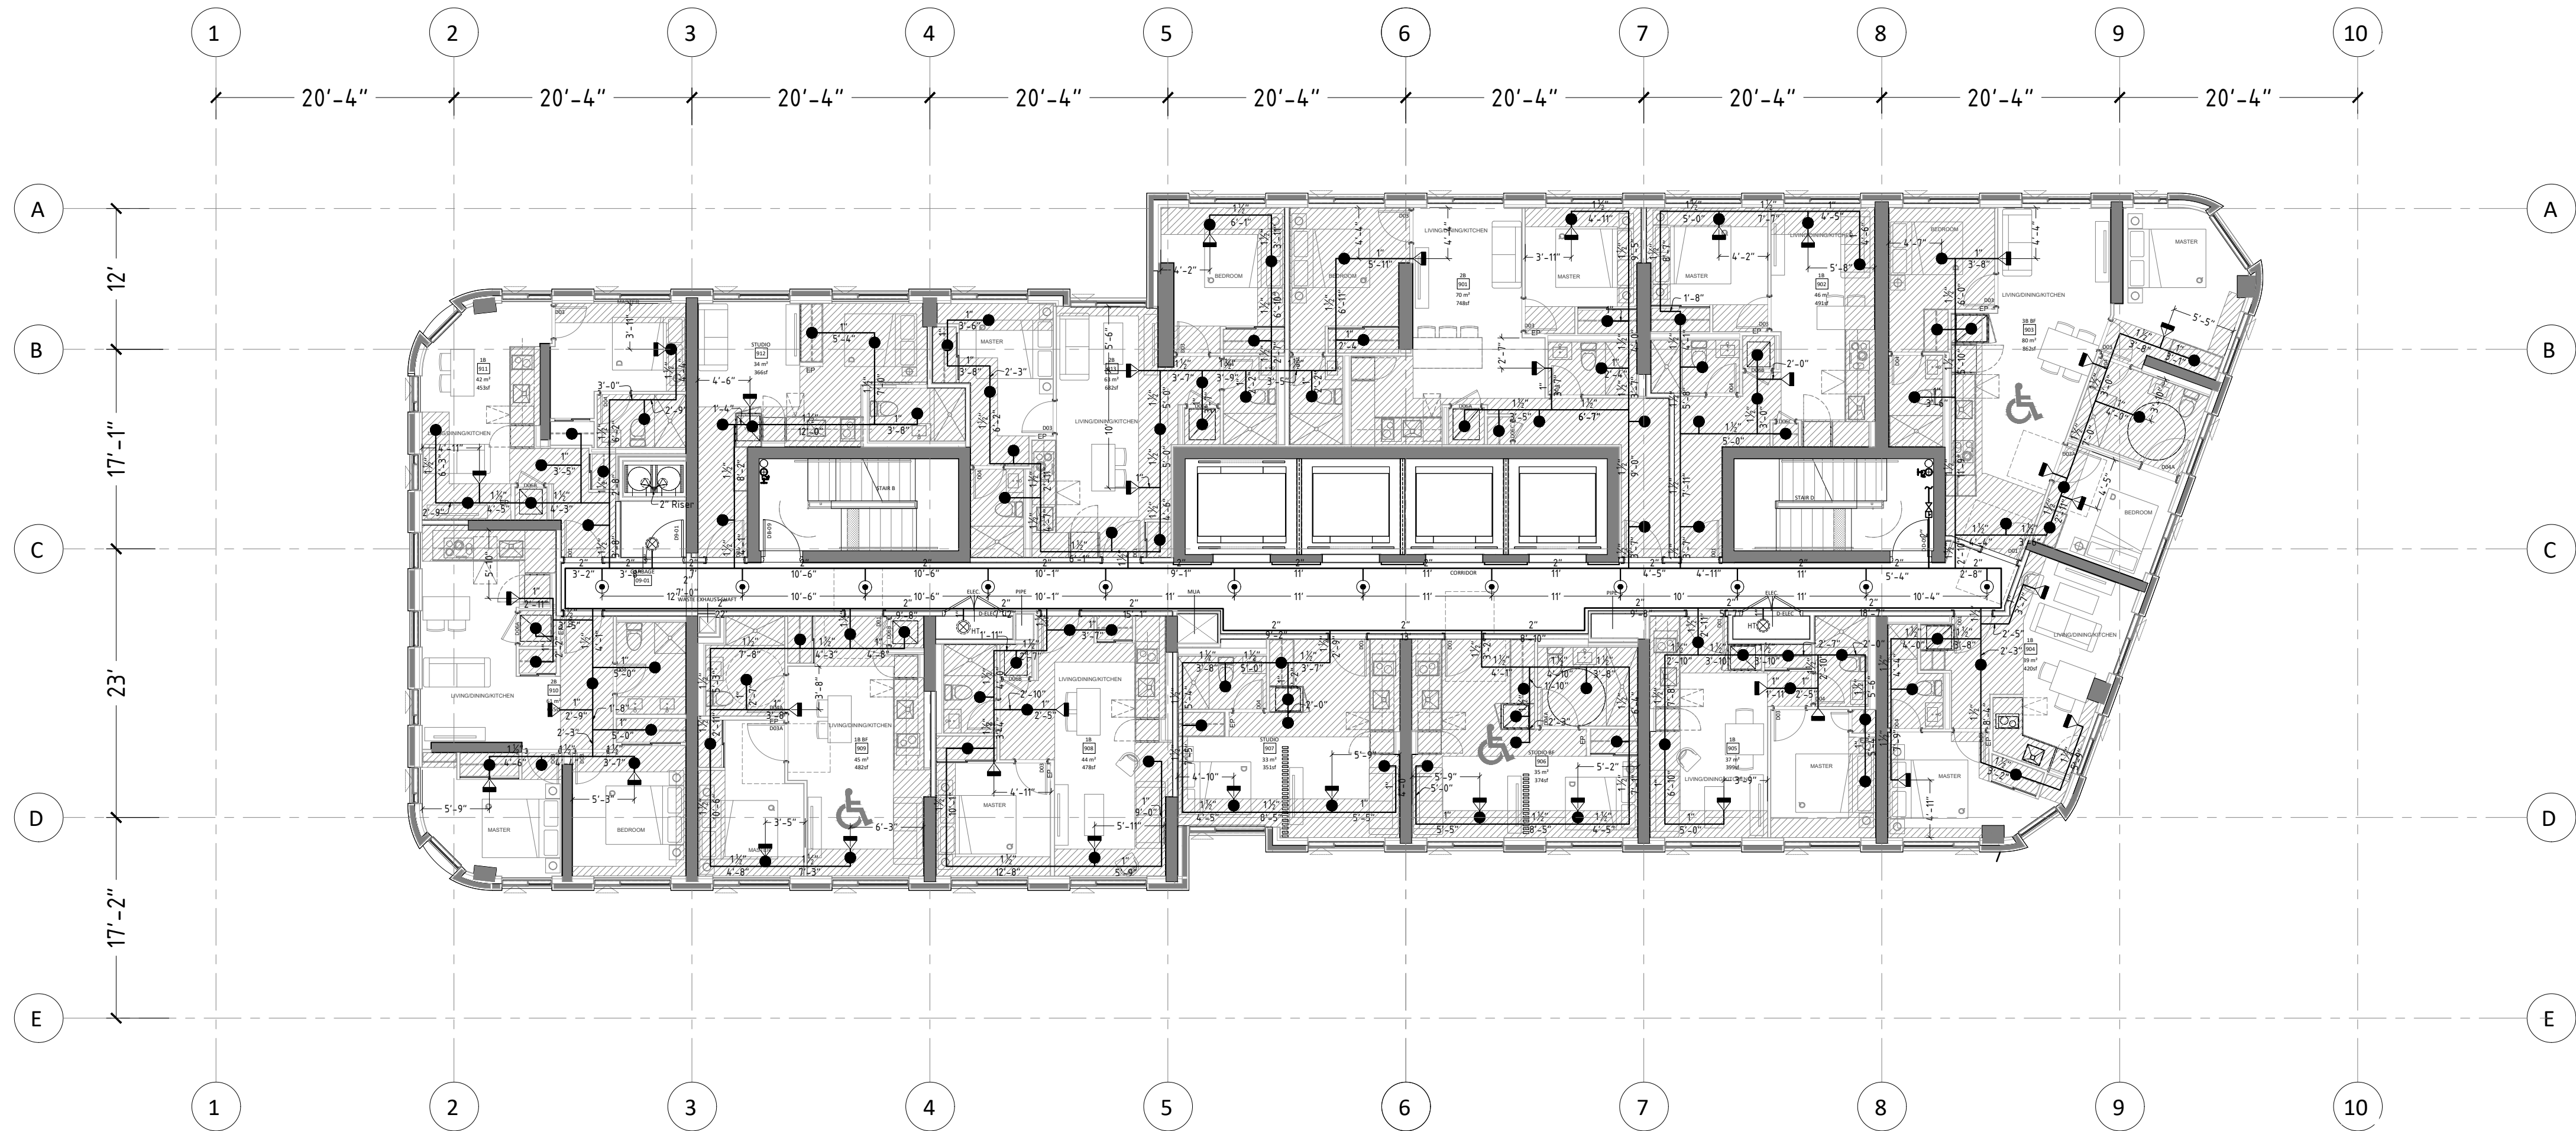22-0007
PROJECT
SK RJ
BY REVIEWED
SP-18



X	00	0000000000
NO	DATE	DESCRIPTION
ISSUED/REVISION RECORD		

SPRINKLER HEAD LEGEND				
C/W GUARD				
S/R=STANDARD RESPONSE		Q/R=QUICK RESPONSE		
S/C=STANDARD COVERAGE		E/C=EXTENDED COVERAGE		
SYMBOL	THREAD SIZE	K-FACTOR	TEMP RATING	STYLE(MODEL)
⊙	1/2"	14	155°F	EXTENDED COVERAGE UPRIGHT
○	1/2"	5.6	165°F	UPRIGHT S/C
⊗	1/2"	5.6	165°F	DRY UPRIGHT SPRINKLER HEAD
⊙	1/2"	5.6	165°F	STANDARD COVERAGE UPRIGHT
⊗	1/2"	5.6	212°F	STANDARD COVERAGE UPRIGHT
⊙	1"	5.6	155°F	FULLY CONCEALED DRY PENDENT S/C
⊗	1"	5.6	165°F	DRY PENDENT S/C
◀	1/2"	11.2	200°F	EXTENDED COVERAGE SIDEWALL
▶	1/2"	5.6	155°F	WINDOW SPRINKLER
◀	1/2"	5.6	165°F	STANDARD COVERAGE SIDEWALL
●	1/2"	5.8	200°F	RESIDENTIAL FULLY CONCEALED PENDENT
●	1/2"	5.8	200°F	RESIDENTIAL FULLY CONCEALED SIDEWALL
⊙	1/2"	5.6	165°F	CONCEALED PENDENT S/C
⊗	1/2"	5.6	212°F	RESIDENTIAL FULLY CONCEALED PENDENT S/C
⊗	1/2"	8.0	286°F	UPRIGHT IN LOCKER ROOM S/C
2 1/2" STANDARD FIRE HOSE VALVE				
C/W THREADED CAP IN STAIRWELL				
2 1/2" FIRE HOSE VALVE IN CABINET				
C/W FIRE EXTINGUISHER				


REFERENCE TO ALTERNATIVE SOLUTION REPORT :
LOCATE 65 mm DIA FIRE HOSE VALE (FHV)
CONNECTIONS WITHIN THE EXIT STAIRS
ENCLOSURES, CLASS 1 STANDPIPE SYSTEM,
PORTABLE FIRE EXTINGUISHERS PROVIDED
THROUGHOUT THE FLOORS.


PROJECT


PROPOSED MIXED-USED DEVELOPMENT
ADDRESS:
775-783 Vaughan Rd & 670-680
Northcliffe Blvd, York, ON

DRAWING TITLE

9TH FLOOR
FIRE PROTECTION PLAN

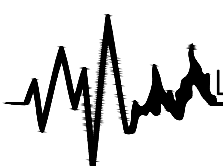 LIFELINE FIRE PROTECTION
www.lifelinefireprotection.com
50 Casimir Court, Concord, ON
L4K 4J5
(416)850-9477

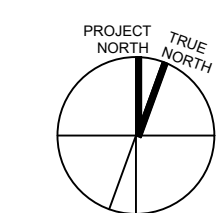	22-0007
	PROJECT
	SK RJ BY REVIEWED
SP-19	

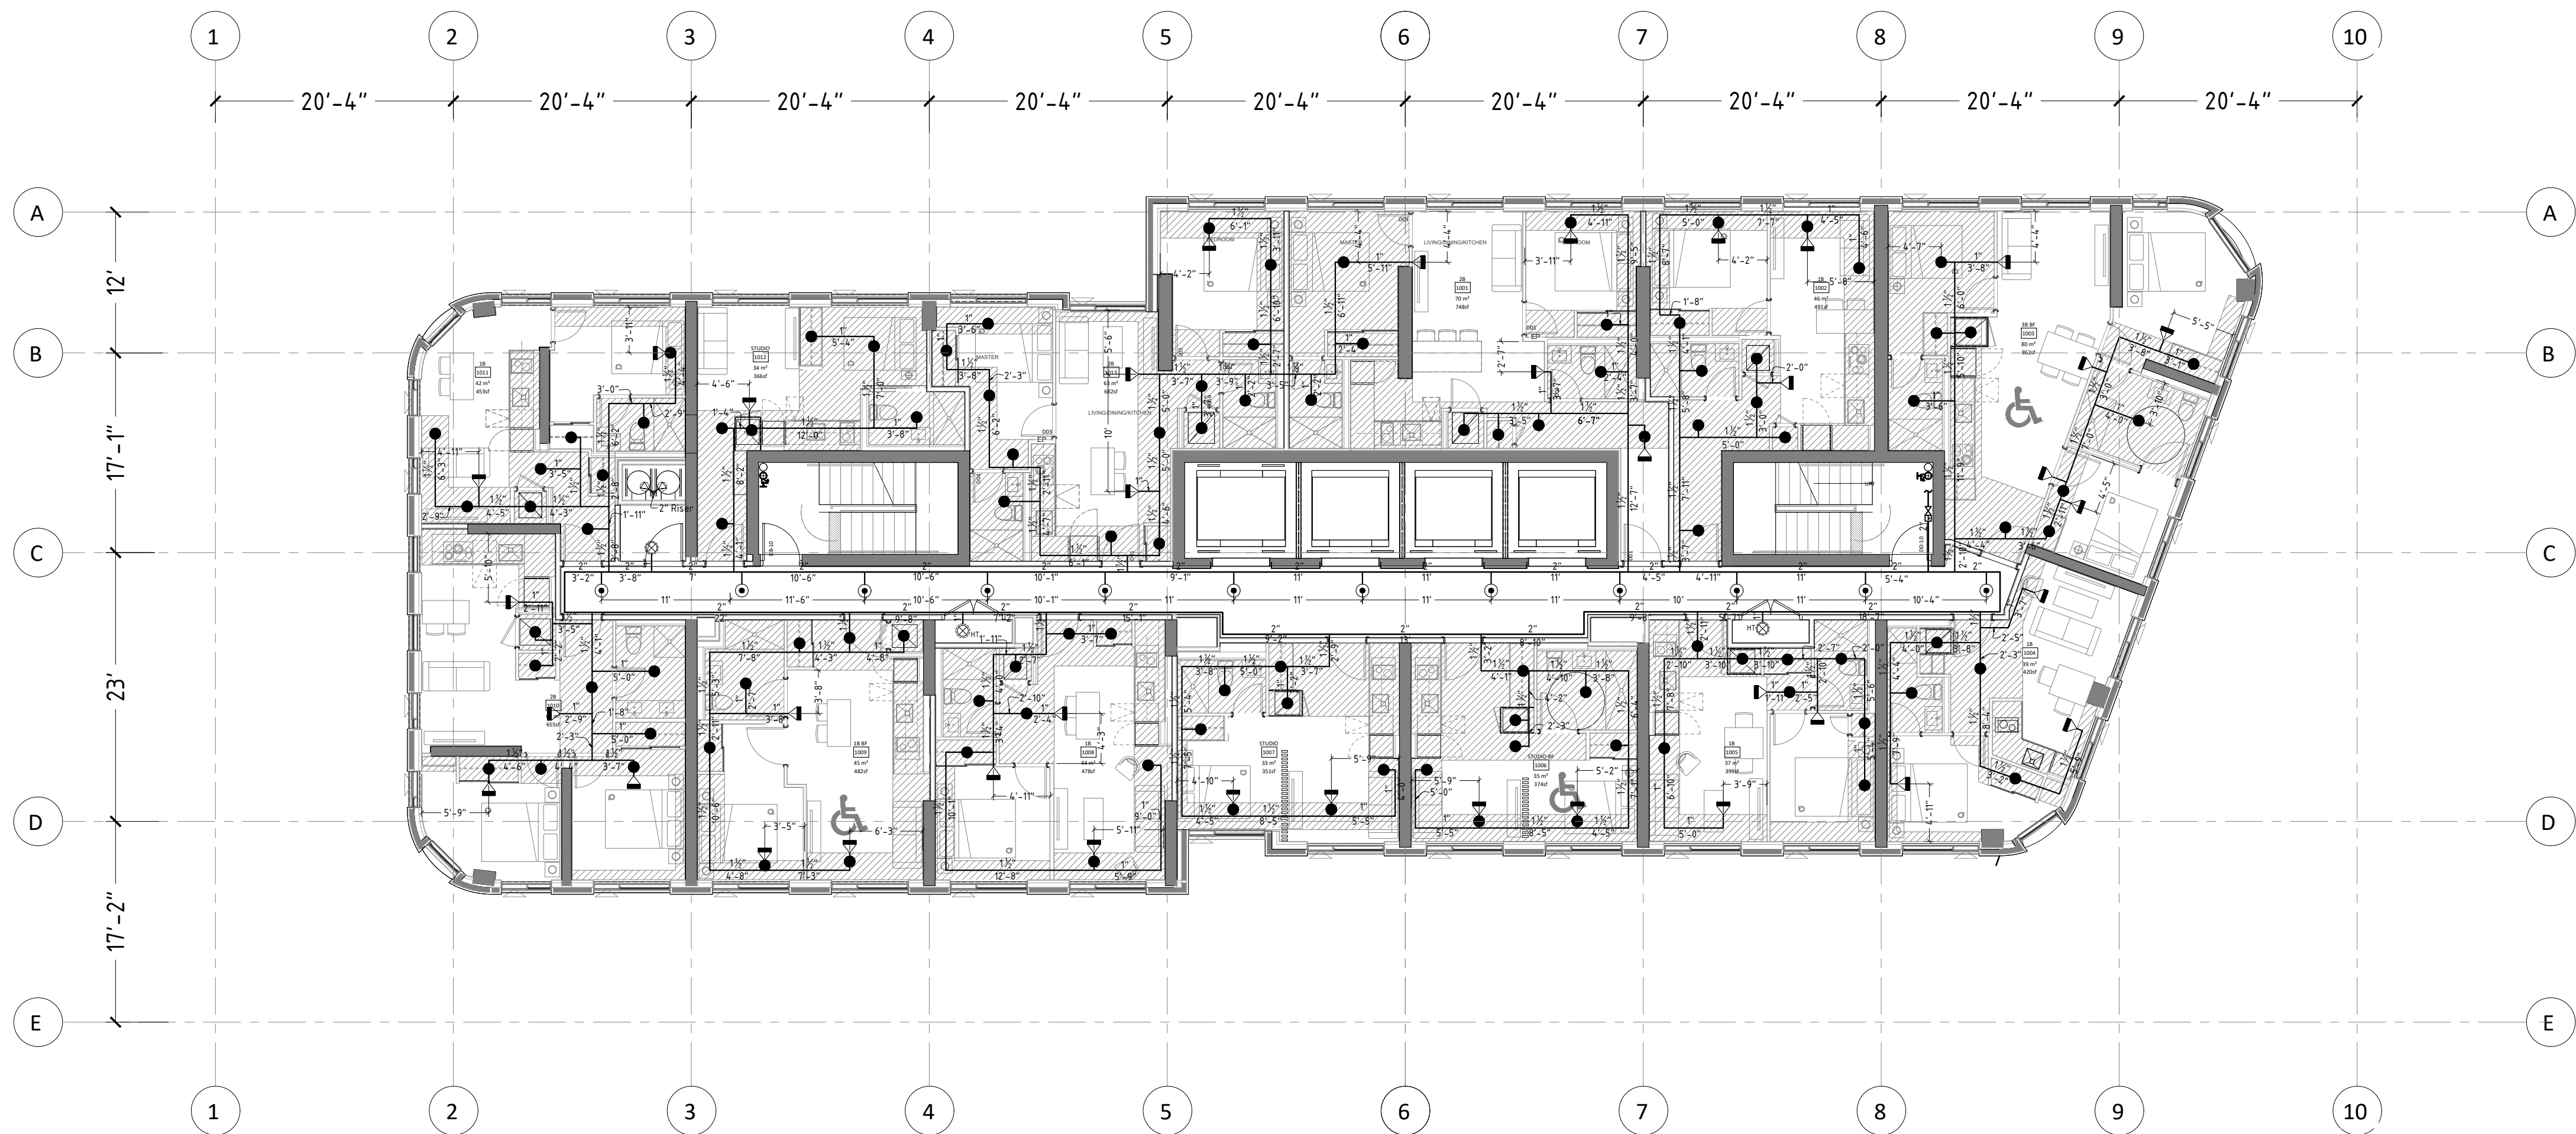

X	XX	XXXXXXXXXXXX
NO	DATE	DESCRIPTION
ISSUED/REVISION RECORD		

SPRINKLER HEAD LEGEND

S/R=STANDARD RESPONSE S/C=STANDARD COVERAGE			C/W GUARD	Q/R=QUICK RESPONSE E/C=EXTENDED COVERAGE
THREADED SIZE	K- FACTOR	TEMP RATING	STYLE(MODEL)	RESPONSE
⊙	1/2"	14	EXTENDED COVERAGE UPRIGHT	S/R
○	1/2"	5.6	UPRIGHT S/C	S/R
⊗	1/2"	5.6	DRY UPRIGHT SPRINKLER HEAD	Q/R
⊙	1/2"	5.6	STANDARD COVERAGE UPRIGHT	Q/R
⊗	1/2"	5.6	STANDARD COVERAGE UPRIGHT	Q/R
⊙	1"	5.6	FULLY CONCEALED DRY PENDENT S/C	Q/R
⊗	1"	5.6	DRY PENDENT S/C	Q/R
⊙	1/2"	11.2	EXTENDED COVERAGE SIDEWALL	S/R
⊙	1/2"	5.6	WINDOW SPRINKLER	Q/R
⊙	1/2"	5.6	STANDARD COVERAGE SIDEWALL	Q/R
⊙	1/2"	5.8	RESIDENTIAL FULLY CONCEALED PENDENT	Q/R
⊙	1/2"	5.8	RESIDENTIAL FULLY CONCEALED SIDEWALL	Q/R
⊙	1/2"	5.6	CONCEALED PENDENT S/C	Q/R
⊙	1/2"	5.6	RESIDENTIAL FULLY CONCEALED PENDENT S/C	Q/R
⊙	1/2"	5.8	UPRIGHT IN LOCKER ROOM S/C	S/R
hpd	2 1/2" STANDARD FIRE HOSE VALVE C/W THREADED CAP IN STAIRWELL			
ext	2 1/2" FIRE HOSE VALVE IN CABINET C/W FIRE EXTINGUISHER			


REFERENCE TO ALTERNATIVE SOLUTION REPORT :
LOCATE 65 mm DIA FIRE HOSE VALE (FHV)
CONNECTIONS WITHIN THE EXIT STAIRS
ENCLOSURES CLASS 1 STANDPIPE SYSTEM.
PORTABLE FIRE EXTINGUISHERS PROVIDED
THROUGHOUT THE FLOORS.

PROJECT

PROPOSED MIXED-USED DEVELOPMENT
ADDRESS:
775-783 Vaughan Rd & 670-680
Northcliffe Blvd, York, ON

DRAWING TITLE

10TH-12TH FLOOR
FIRE PROTECTION PLAN

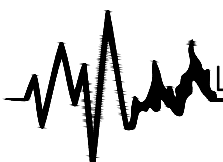 LIFELINE FIRE PROTECTION
www.lifelinefireprotection.com
50 Casimir Court, Concord, ON
L4K 4J5
(416)850-9477

PROJECT NORTH NORTH	22-0007 PROJECT SK RJ BY REVIEWED
SP-20	



S/R: STANDARD RESPONSE			C/W: GUARD		Q/R: QUICK RESPONSE	
S/C: STANDARD RESPONSE					E/C: EXTENDED COVERAGE	
THREAD SIZE	K-FACTOR	TEMP. RATING	STYLE(MODEL)	RESPONSE		
⊙	1/2"	14"	155°F	EXTENDED COVERAGE UPRIGHT		S/R
○	3/4"	5.6	165°F	UPRIGHT S/C		
⊙	3/4"	5.6	165°F	DRY UPRIGHT SPRINKLER HEAD		Q/R
⊗	1/2"	5.6	165°F	STANDARD COVERAGE UPRIGHT		Q/R
⊗	3/4"	5.6	212°F	STANDARD COVERAGE UPRIGHT		Q/R
⊗	1"	5.6	155°F	FULLY CONCEALED DRY PENDENT S/C		Q/R
⊗	1"	5.6	165°F	DRY PENDENT S/C		Q/R
⊗	1/2"	11.2	200°F	EXTENDED COVERAGE SIDEWALL		S/R
⊗	3/4"	5.6	155°F	WINDOW SPRINKLER		S/R
⊗	3/4"	5.6	165°F	STANDARD COVERAGE SIDEWALL		
⊗	3/4"	5.8	200°F	RESIDENTIAL PLY CONCEALED PENDENT		Q/R
⊗	3/4"	5.8	200°F	RESIDENTIAL PLY CONCEALED SIDEWALL		
⊗	3/4"	5.6	165°F	RESIDENTIAL PLY CONCEALED S/C		
⊗	3/4"	5.6	212°F	RESIDENTIAL PLY CONCEALED PENDENT S/C		
⊗	3/4"	8.0	288°F	UPRIGHT IN LOCKER ROOM S/C		S/R
hpf	2 1/2" STANDARD FIRE HOSE VALVE C/W THREADED CAP IN STAINWELL					
hpf	2 1/2" FIRE HOSE VALVE IN CABINET C/W FIRE EXTINGUISHER					


PROJECT


PROPOSED MIXED-USED DEVELOPMENT

ADDRESS:
775-783 Vaughan Rd & 670-680
Northcliffe Blvd, York, ON

 **LIFELINE FIRE PROTECTION**
www.lifelinefireprotection.com

50 Cosmair Court, Concord, ON
L4K 4J5
(416)850-9477

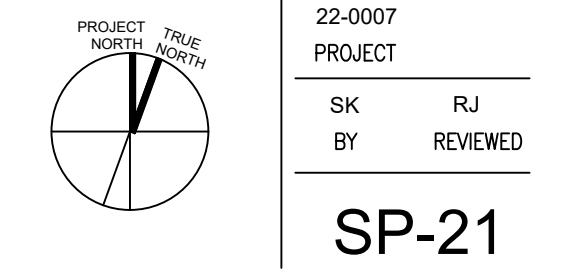

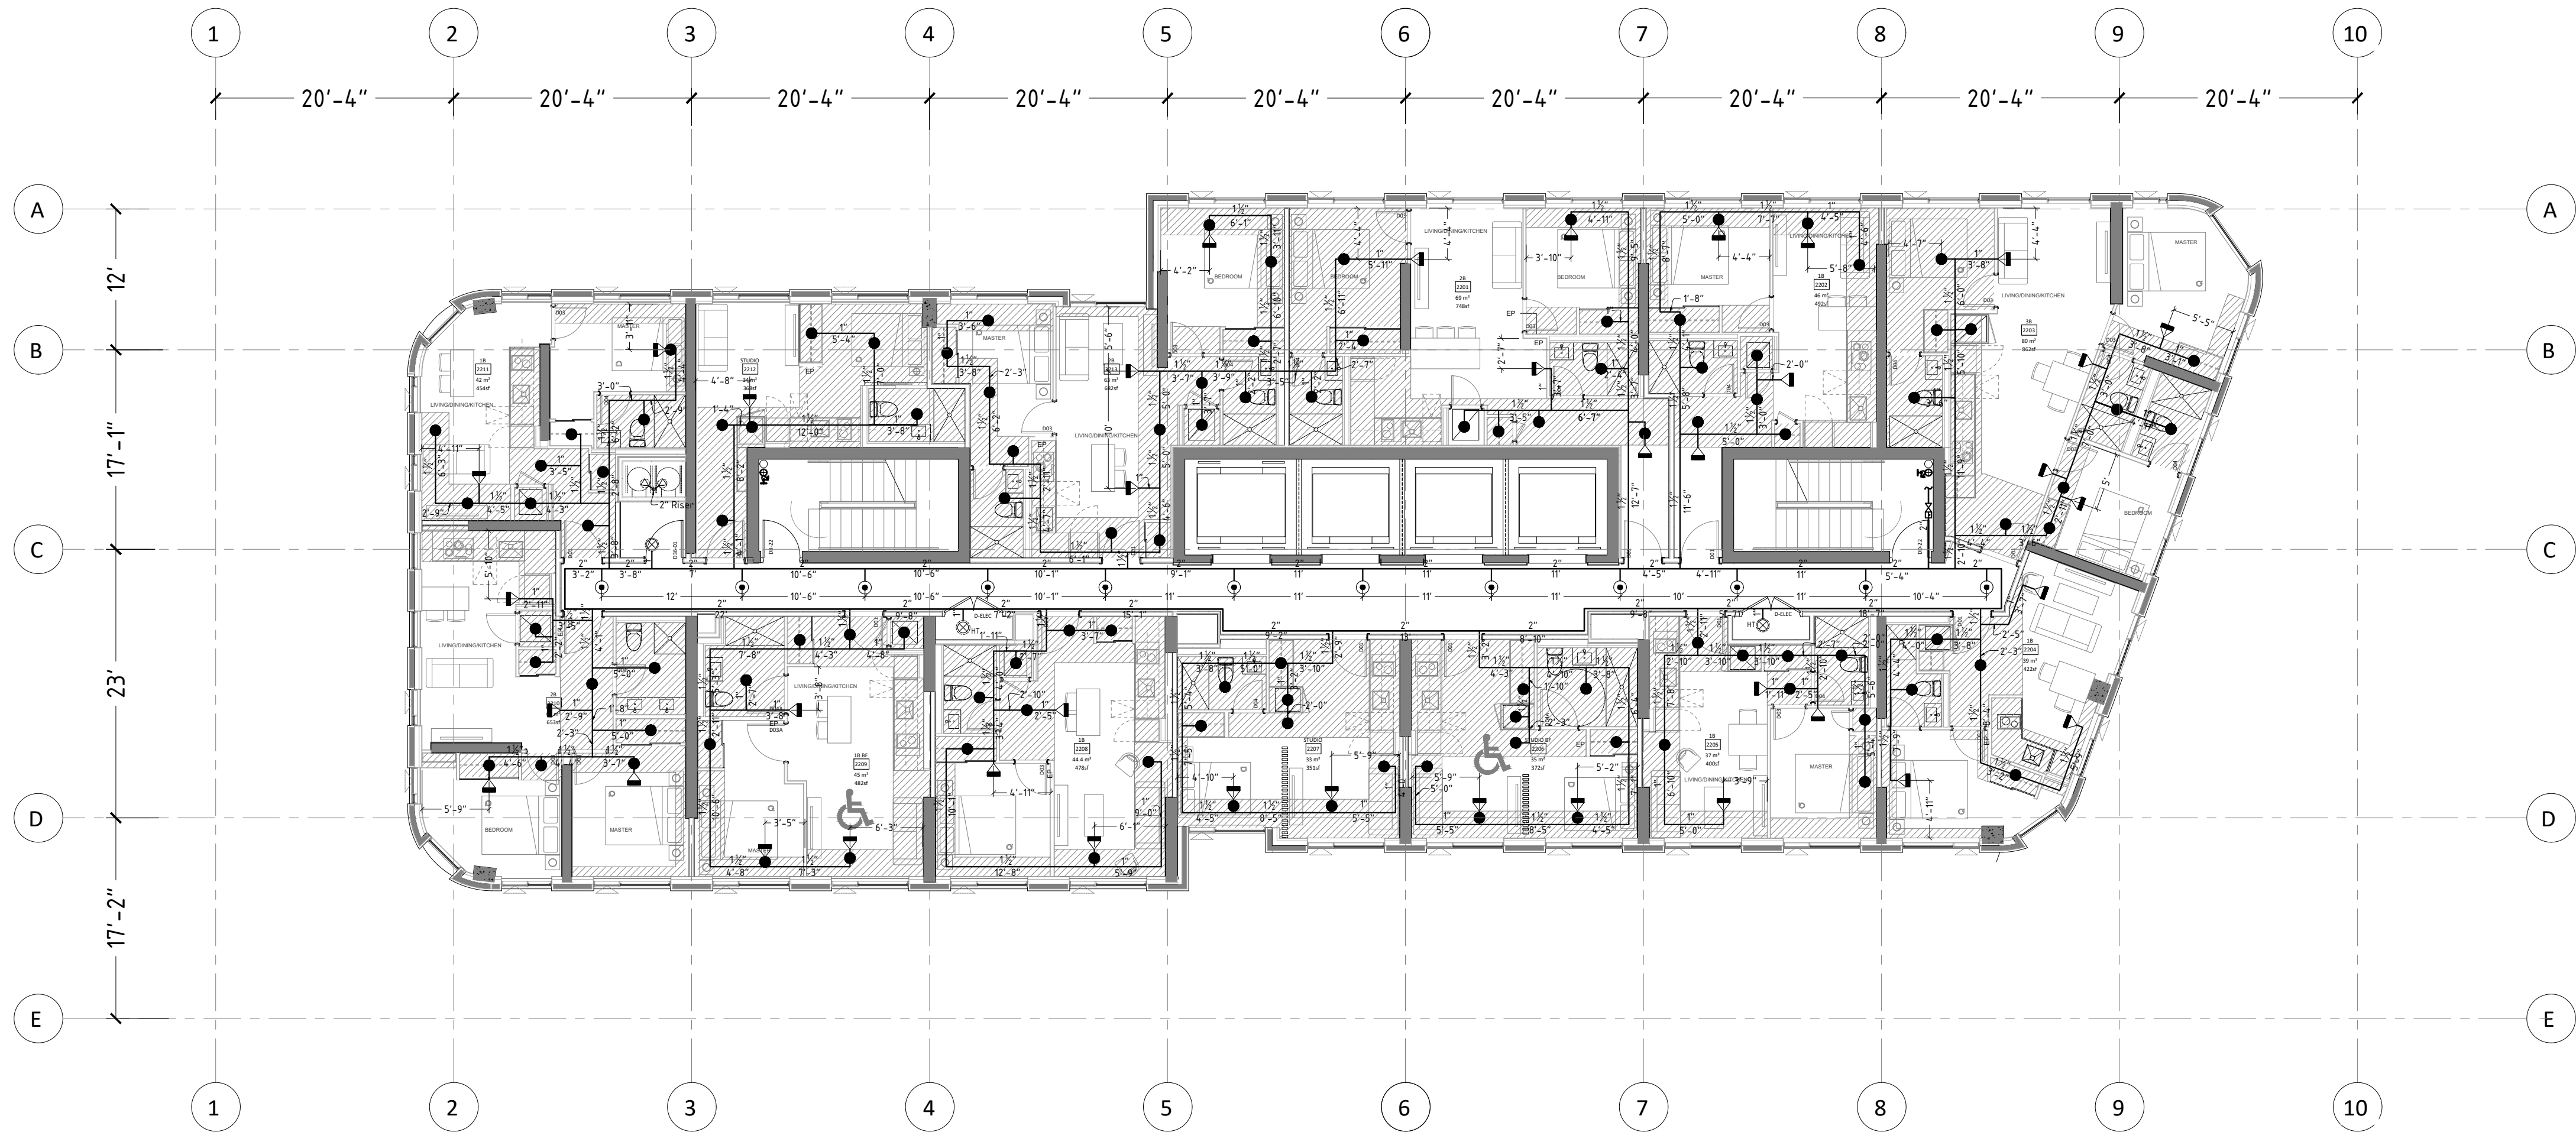

X	00	XXXXXXXXXXXX
NO	DATE	DESCRIPTION
ISSUED/REVISION RECORD		

SPRINKLER HEAD LEGEND


S/R=STANDARD RESPONSE S/C=STANDARD COVERAGE				C/W GUARD	Q/R=QUICK RESPONSE E/C=EXTENDED COVERAGE
	THREAD SIZE	K- FACTOR	TEMP RATING	STYLE(MODEL)	RESPONSE
	1/2"	14	155°F	EXTENDED COVERAGE UPRIGHT	S/R
	1/2"	5.6	165°F	UPRIGHT S/C	S/R
	1/2"	5.6	165°F	DRY UPRIGHT SPRINKLER HEAD	Q/R
	1/2"	5.6	165°F	STANDARD COVERAGE UPRIGHT	Q/R
	1/2"	5.6	212°F	STANDARD COVERAGE UPRIGHT	Q/R
	1"	5.6	155°F	FULLY CONCEALED DRY PENDENT S/C	Q/R
	1"	5.6	165°F	DRY PENDENT S/C	Q/R
	1/2"	11.2	200°F	EXTENDED COVERAGE SIDEWALL	S/R
	1/2"	5.6	155°F	WINDOW SPRINKLER	Q/R
	1/2"	5.6	165°F	STANDARD COVERAGE SIDEWALL	Q/R
	1/2"	5.8	200°F	RESIDENTIAL FULLY CONCEALED PENDENT	Q/R
	1/2"	5.8	200°F	RESIDENTIAL FULLY CONCEALED SIDEWALL	Q/R
	1/2"	5.6	165°F	CONCEALED PENDENT S/C	Q/R
	1/2"	5.6	212°F	RESIDENTIAL FULLY CONCEALED PENDENT S/C	Q/R
	1/2"	8.0	286°F	UPRIGHT IN LOCKER ROOM S/C	S/R
	2 1/2" STANDARD FIRE HOSE VALVE C/W THREADED CAP IN STAIRWELL				
	2 1/2" FIRE HOSE VALVE IN CABINET C/W FIRE EXTINGUISHER				

PROJECT
PROPOSED MIXED-USED DEVELOPMENT
ADDRESS:
775-783 Vaughan Rd & 670-680
Northcliffe Blvd, York, ON

DRAWING TITLE
22TH-23TH FLOOR
FIRE PROTECTION PLAN

LIFELINE FIRE PROTECTION
www.lifelinefireprotection.com
50 Casimir Court, Concord, ON
L4K 4J5
(416)850-9477

PROJECT TRUE
NORTH NORTH
22-0007
PROJECT
SK RJ
BY REVIEWED
SP-22

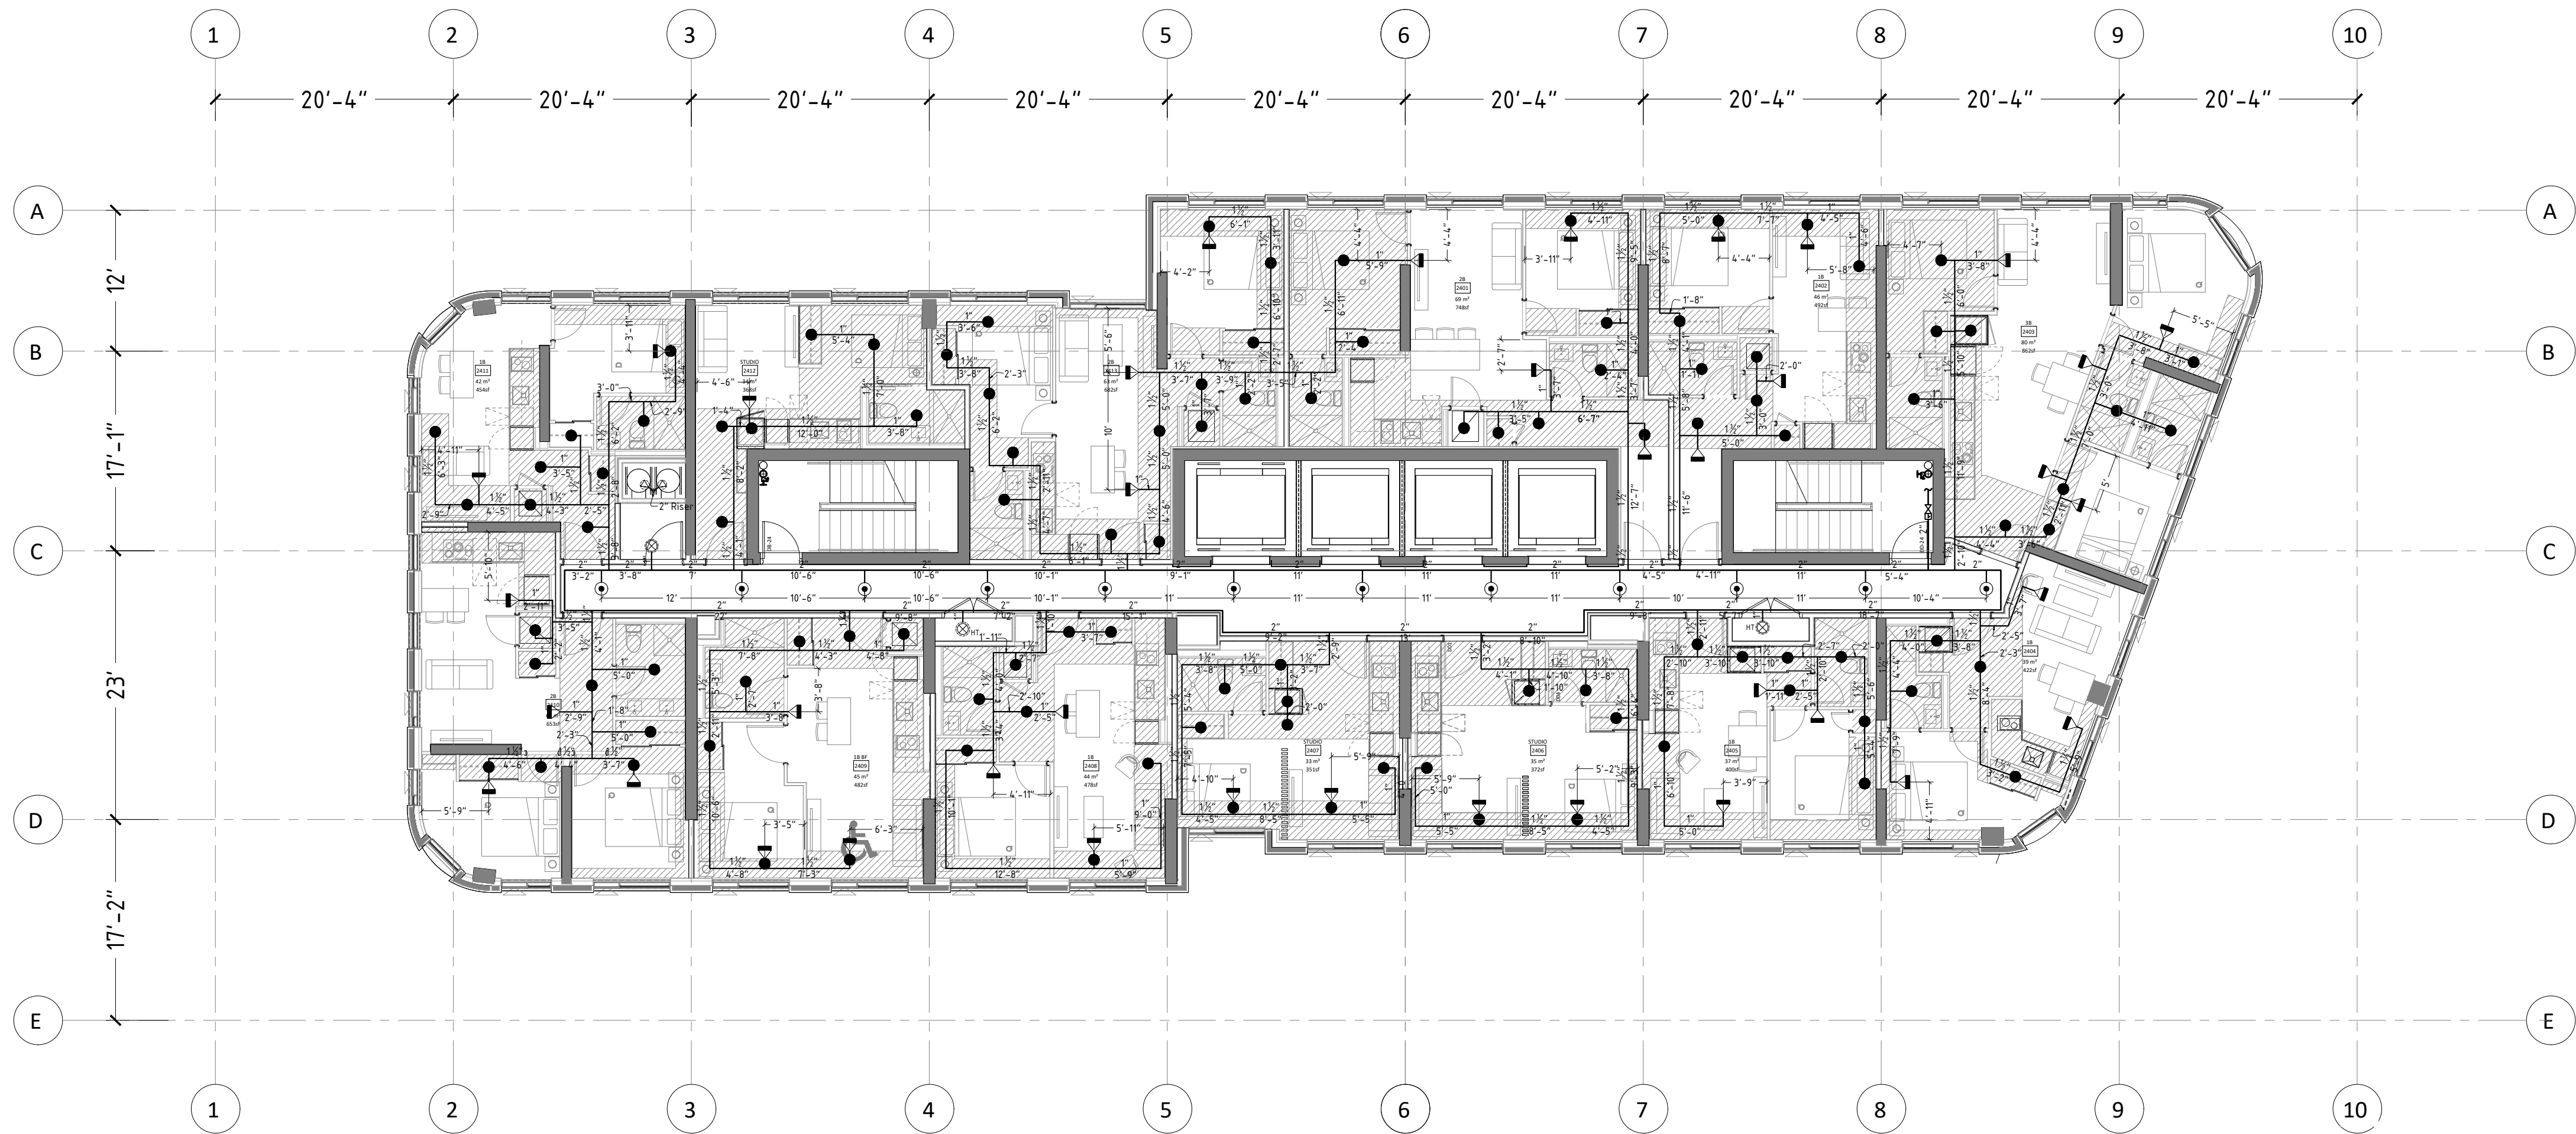


X	XX	XXXXXXXXXXXX
NO	DATE	DESCRIPTION
ISSUED/REVISION RECORD		

SPRINKLER HEAD LEGEND


S/R=STANDARD RESPONSE S/C=STANDARD COVERAGE			C/W GUARD	Q/R=QUICK RESPONSE E/C=EXTENDED COVERAGE
THREADED SIZE	K- FACTOR	TEMP RATING	STYLE(MODEL)	RESPONSE
⊙	1/2"	145°F	EXTENDED COVERAGE UPRIGHT	S/R
○	1/2"	165°F	UPRIGHT S/C	S/R
⊗	1/2"	165°F	DRY UPRIGHT SPRINKLER HEAD	Q/R
⊙	1/2"	165°F	STANDARD COVERAGE UPRIGHT	Q/R
⊗	1/2"	165°F	STANDARD COVERAGE UPRIGHT	Q/R
⊙	1"	155°F	FULLY CONCEALED DRY PENDENT S/C	S/R
⊙	1"	165°F	DRY PENDENT S/C	Q/R
⊙	1/2"	200°F	EXTENDED COVERAGE SIDEWALL	S/R
⊙	1/2"	155°F	WINDOW SPRINKLER	Q/R
⊙	1/2"	165°F	STANDARD COVERAGE SIDEWALL	Q/R
⊙	1/2"	200°F	RESIDENTIAL FULLY CONCEALED PENDENT	Q/R
⊙	1/2"	200°F	RESIDENTIAL FULLY CONCEALED SIDEWALL	Q/R
⊙	1/2"	165°F	CONCEALED PENDENT S/C	Q/R
⊙	1/2"	165°F	CONCEALED PENDENT S/C	Q/R
⊙	1/2"	212°F	UPRIGHT IN LOCKER ROOM S/C	S/R
⊙	1/2"	284°F	UPRIGHT IN LOCKER ROOM S/C	S/R
2 1/2" STANDARD FIRE HOSE VALVE C/W THREADED CAP IN STAIRWELL				
2 1/2" FIRE HOSE VALVE IN CABINET C/W FIRE EXTINGUISHER				

PROJECT
PROPOSED MIXED-USED DEVELOPMENT
ADDRESS:
775-783 Vaughan Rd & 670-680
Northcliffe Blvd, York, ON

DRAWING TITLE
24TH-33TH FLOOR
FIRE PROTECTION PLAN

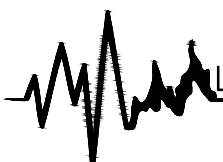 LIFELINE FIRE PROTECTION
www.lifelinefireprotection.com
50 Casimir Court, Concord, ON
L4K 4J5
(416)850-9477

PROJECT TRUE
NORTH NORTH
22-0007
PROJECT
SK RJ
BY REVIEWED
SP-23

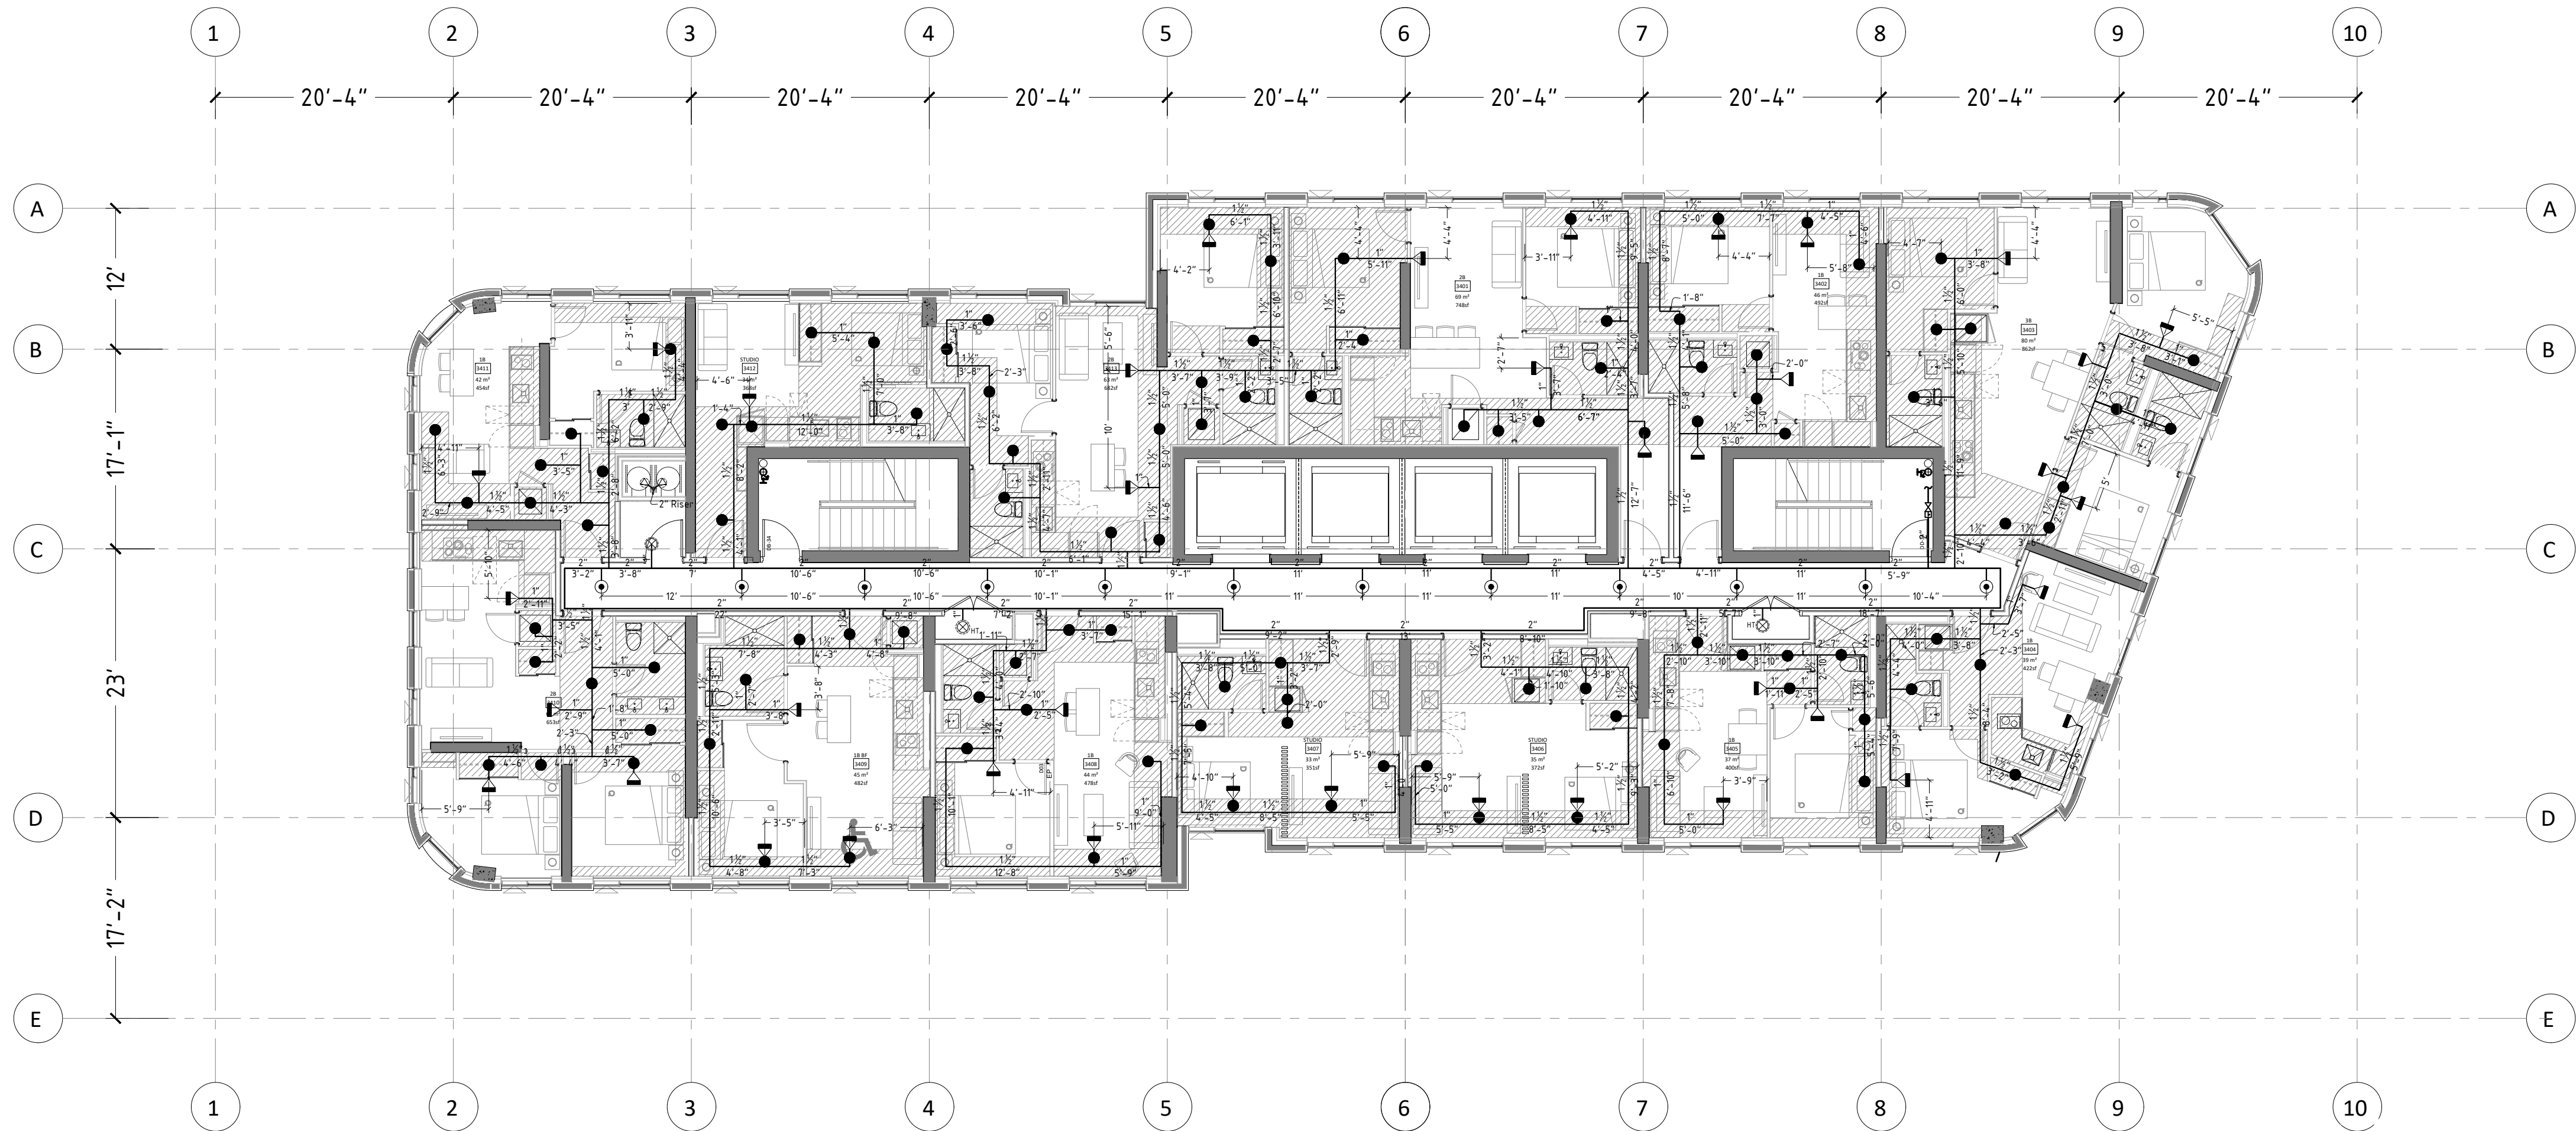

X	00	XXXXXXXXXXXX
NO	DATE	DESCRIPTION
ISSUED/REVISION RECORD		

SPRINKLER HEAD LEGEND


S/R=STANDARD RESPONSE S/C=STANDARD COVERAGE				C/W GUARD	Q/R=QUICK RESPONSE E/C=EXTENDED COVERAGE
	THREAD SIZE	K-FACTOR	TEMP RATING	STYLE(MODEL)	RESPONSE
⊙	1/2"	14	155°F	EXTENDED COVERAGE UPRIGHT	S/R
○	1/2"	5.6	165°F	UPRIGHT S/C	S/R
⊗	1/2"	5.6	165°F	DRY UPRIGHT SPRINKLER HEAD	Q/R
⊙	1/2"	5.6	165°F	STANDARD COVERAGE UPRIGHT	Q/R
⊗	1/2"	5.6	212°F	STANDARD COVERAGE UPRIGHT	Q/R
⊙	1"	5.6	155°F	FULLY CONCEALED DRY PENDENT S/C	Q/R
⊙	1"	5.6	165°F	DRY PENDENT S/C	Q/R
◀	1/2"	11.2	200°F	EXTENDED COVERAGE SIDEWALL	S/R
▶	1/2"	5.6	155°F	WINDOW SPRINKLER	Q/R
◀	1/2"	5.6	165°F	STANDARD COVERAGE SIDEWALL	Q/R
●	1/2"	5.8	200°F	RESIDENTIAL FULLY CONCEALED PENDENT	Q/R
●	1/2"	5.8	200°F	RESIDENTIAL FULLY CONCEALED SIDEWALL	Q/R
⊙	1/2"	5.6	165°F	CONCEALED PENDENT S/C	Q/R
⊙	1/2"	5.6	212°F	RESIDENTIAL FULLY CONCEALED PENDENT S/C	Q/R
⊙	1/2"	8.0	286°F	UPRIGHT IN LOCKER ROOM S/C	S/R
hpd	2 1/2" STANDARD FIRE HOSE VALVE C/W THREADED CAP IN STAIRWELL				
hpd	2 1/2" FIRE HOSE VALVE IN CABINET C/W FIRE EXTINGUISHER				

PROJECT
PROPOSED MIXED-USED DEVELOPMENT
ADDRESS:
775-783 Vaughan Rd & 670-680
Northcliffe Blvd, York, ON

DRAWING TITLE
34TH FLOOR
FIRE PROTECTION PLAN

LIFELINE FIRE PROTECTION
www.lifelinefireprotection.com
50 Casimir Court, Concord, ON
L4K 4J5
(416)850-9477

PROJECT TRUE NORTH
22-0007
PROJECT
SK RJ
BY REVIEWED
SP-24

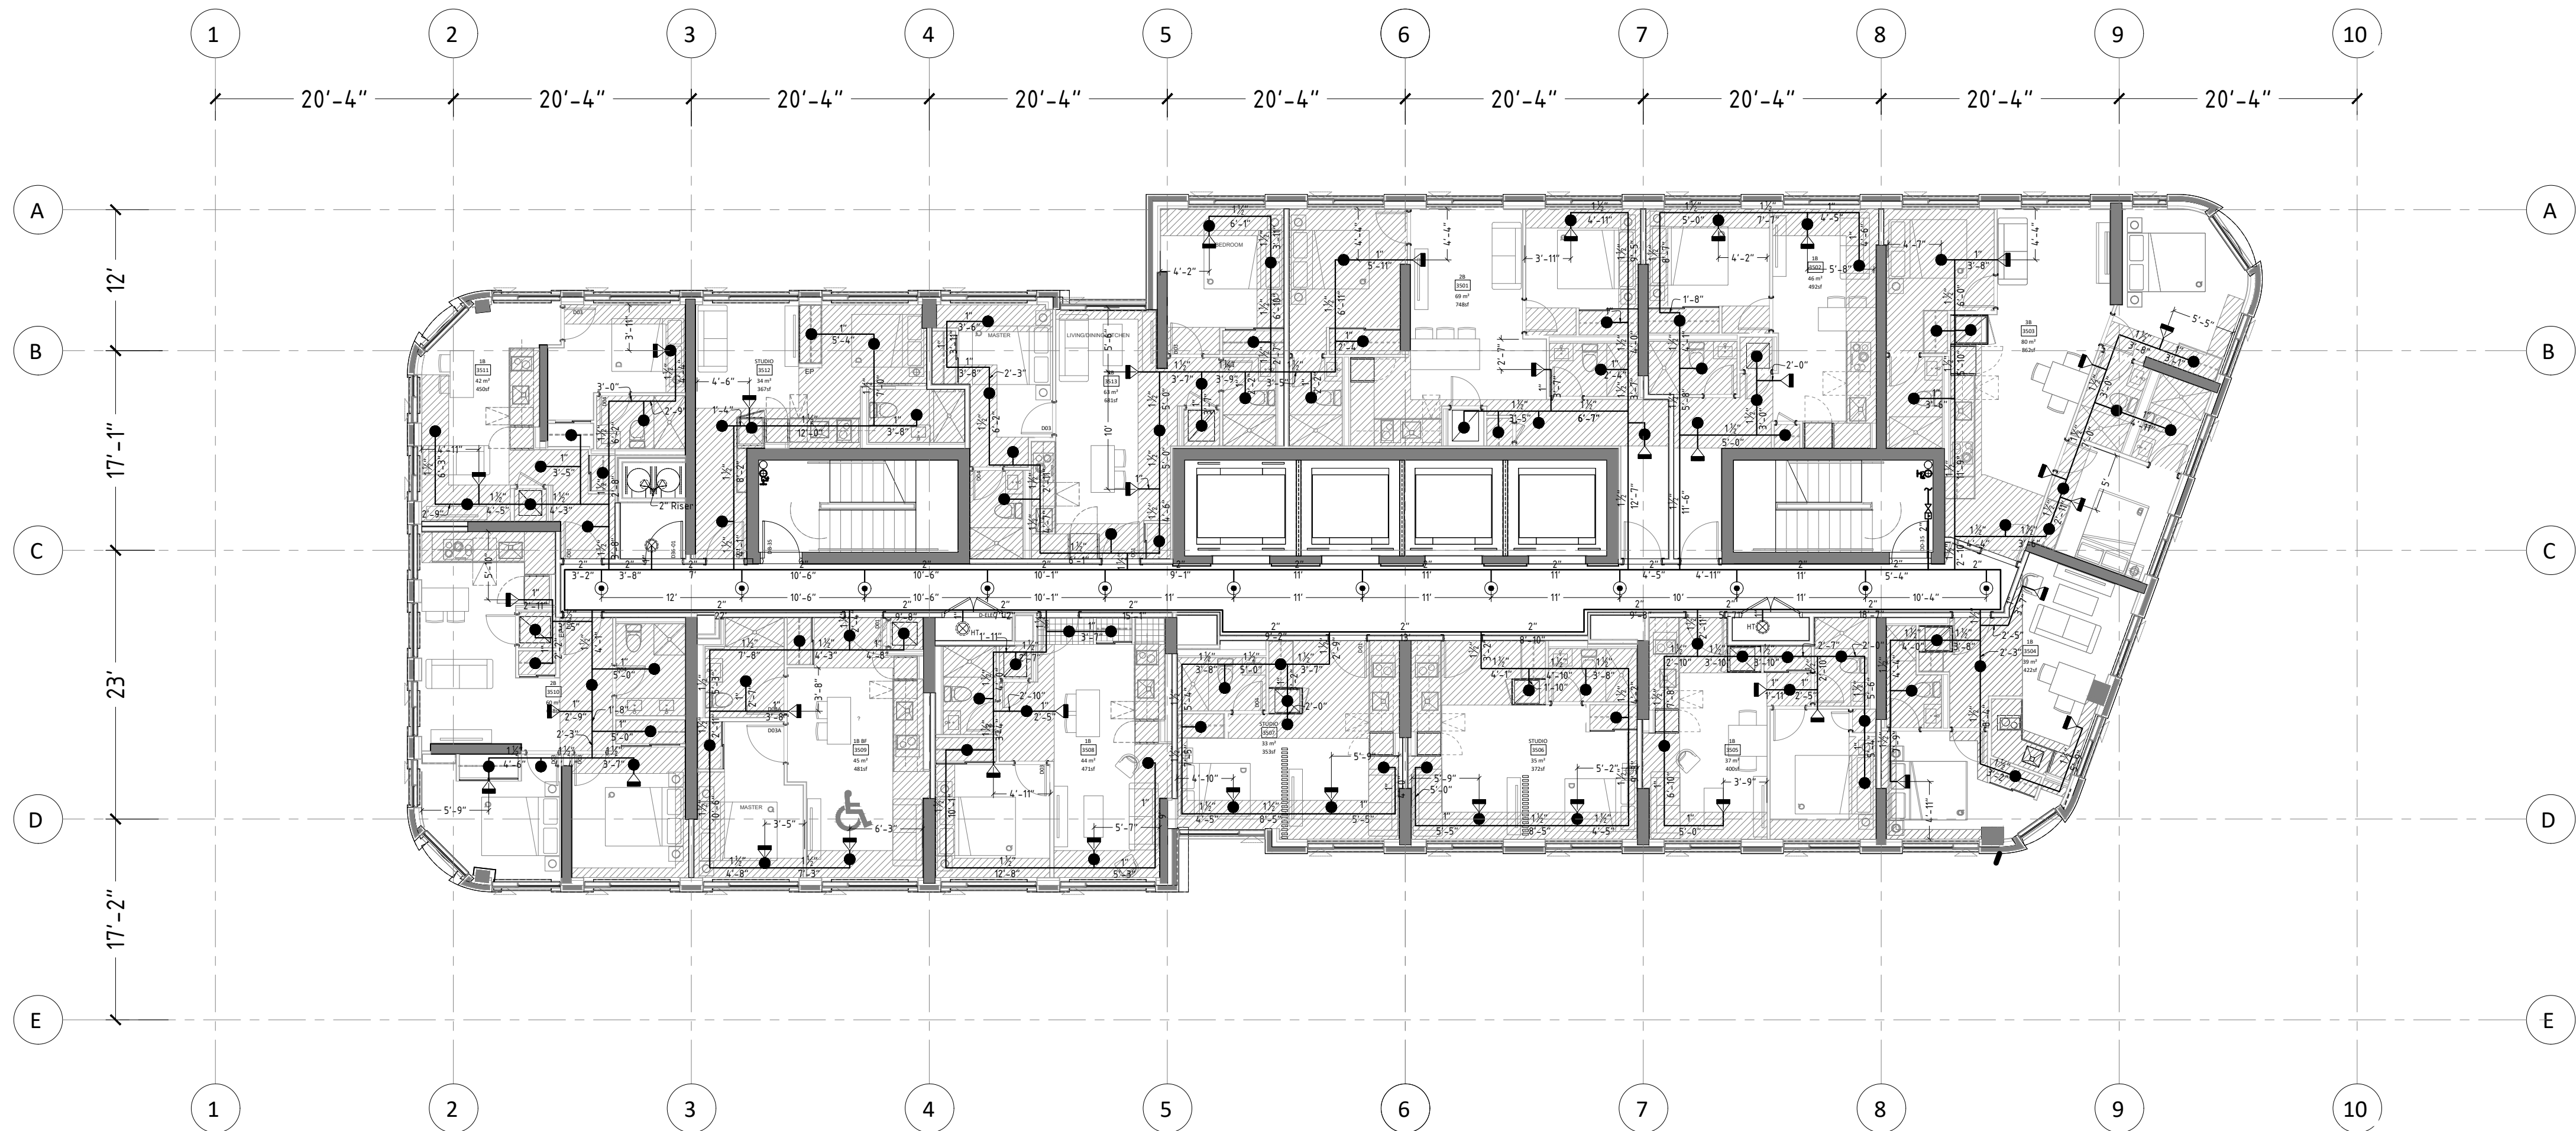

X	00	XXXXXXXXXXXX
NO	DATE	DESCRIPTION
ISSUED/REVISION RECORD		


SPRINKLER HEAD LEGEND				
C/W GUARD				
S/R=STANDARD RESPONSE		Q/R=QUICK RESPONSE		
S/C=STANDARD COVERAGE		E/C=EXTENDED COVERAGE		
SYMBOL	THREAD SIZE	K-FACTOR	TEMP RATING	RESPONSE
	1/2"	14	155°F	EXTENDED COVERAGE UPRIGHT
	1/2"	5.6	165°F	UPRIGHT S/C
	1/2"	5.6	165°F	DRY UPRIGHT SPRINKLER HEAD
	1/2"	5.6	165°F	STANDARD COVERAGE UPRIGHT
	1/2"	5.6	212°F	STANDARD COVERAGE UPRIGHT
	1"	5.6	155°F	FULLY CONCEALED DRY PENDENT S/C
	1"	5.6	165°F	DRY PENDENT S/C
	1/2"	11.2	200°F	EXTENDED COVERAGE SIDEWALL
	1/2"	5.6	155°F	WINDOW SPRINKLER
	1/2"	5.6	165°F	STANDARD COVERAGE SIDEWALL
	1/2"	5.8	200°F	RESIDENTIAL FULLY CONCEALED PENDENT
	1/2"	5.8	200°F	RESIDENTIAL FULLY CONCEALED SIDEWALL
	1/2"	5.6	165°F	CONCEALED PENDENT S/C
	1/2"	5.6	212°F	RESIDENTIAL FULLY CONCEALED PENDENT S/C
	1/2"	8.0	286°F	UPRIGHT IN LOCKER ROOM S/C
	2 1/2" STANDARD FIRE HOSE VALVE C/W THREADED CAP IN STAIRWELL			
	2 1/2" FIRE HOSE VALVE IN CABINET C/W FIRE EXTINGUISHER			

PROJECT
PROPOSED MIXED-USED DEVELOPMENT
ADDRESS:
775-783 Vaughan Rd & 670-680
Northcliffe Blvd, York, ON

DRAWING TITLE
35TH FLOOR
FIRE PROTECTION PLAN

LIFELINE FIRE PROTECTION
www.lifelinefireprotection.com
50 Casimir Court, Concord, ON
L4K 4J5
(416)850-9477

PROJECT TRUE NORTH
22-0007
PROJECT
SK BY RJ REVIEWED
SP-25

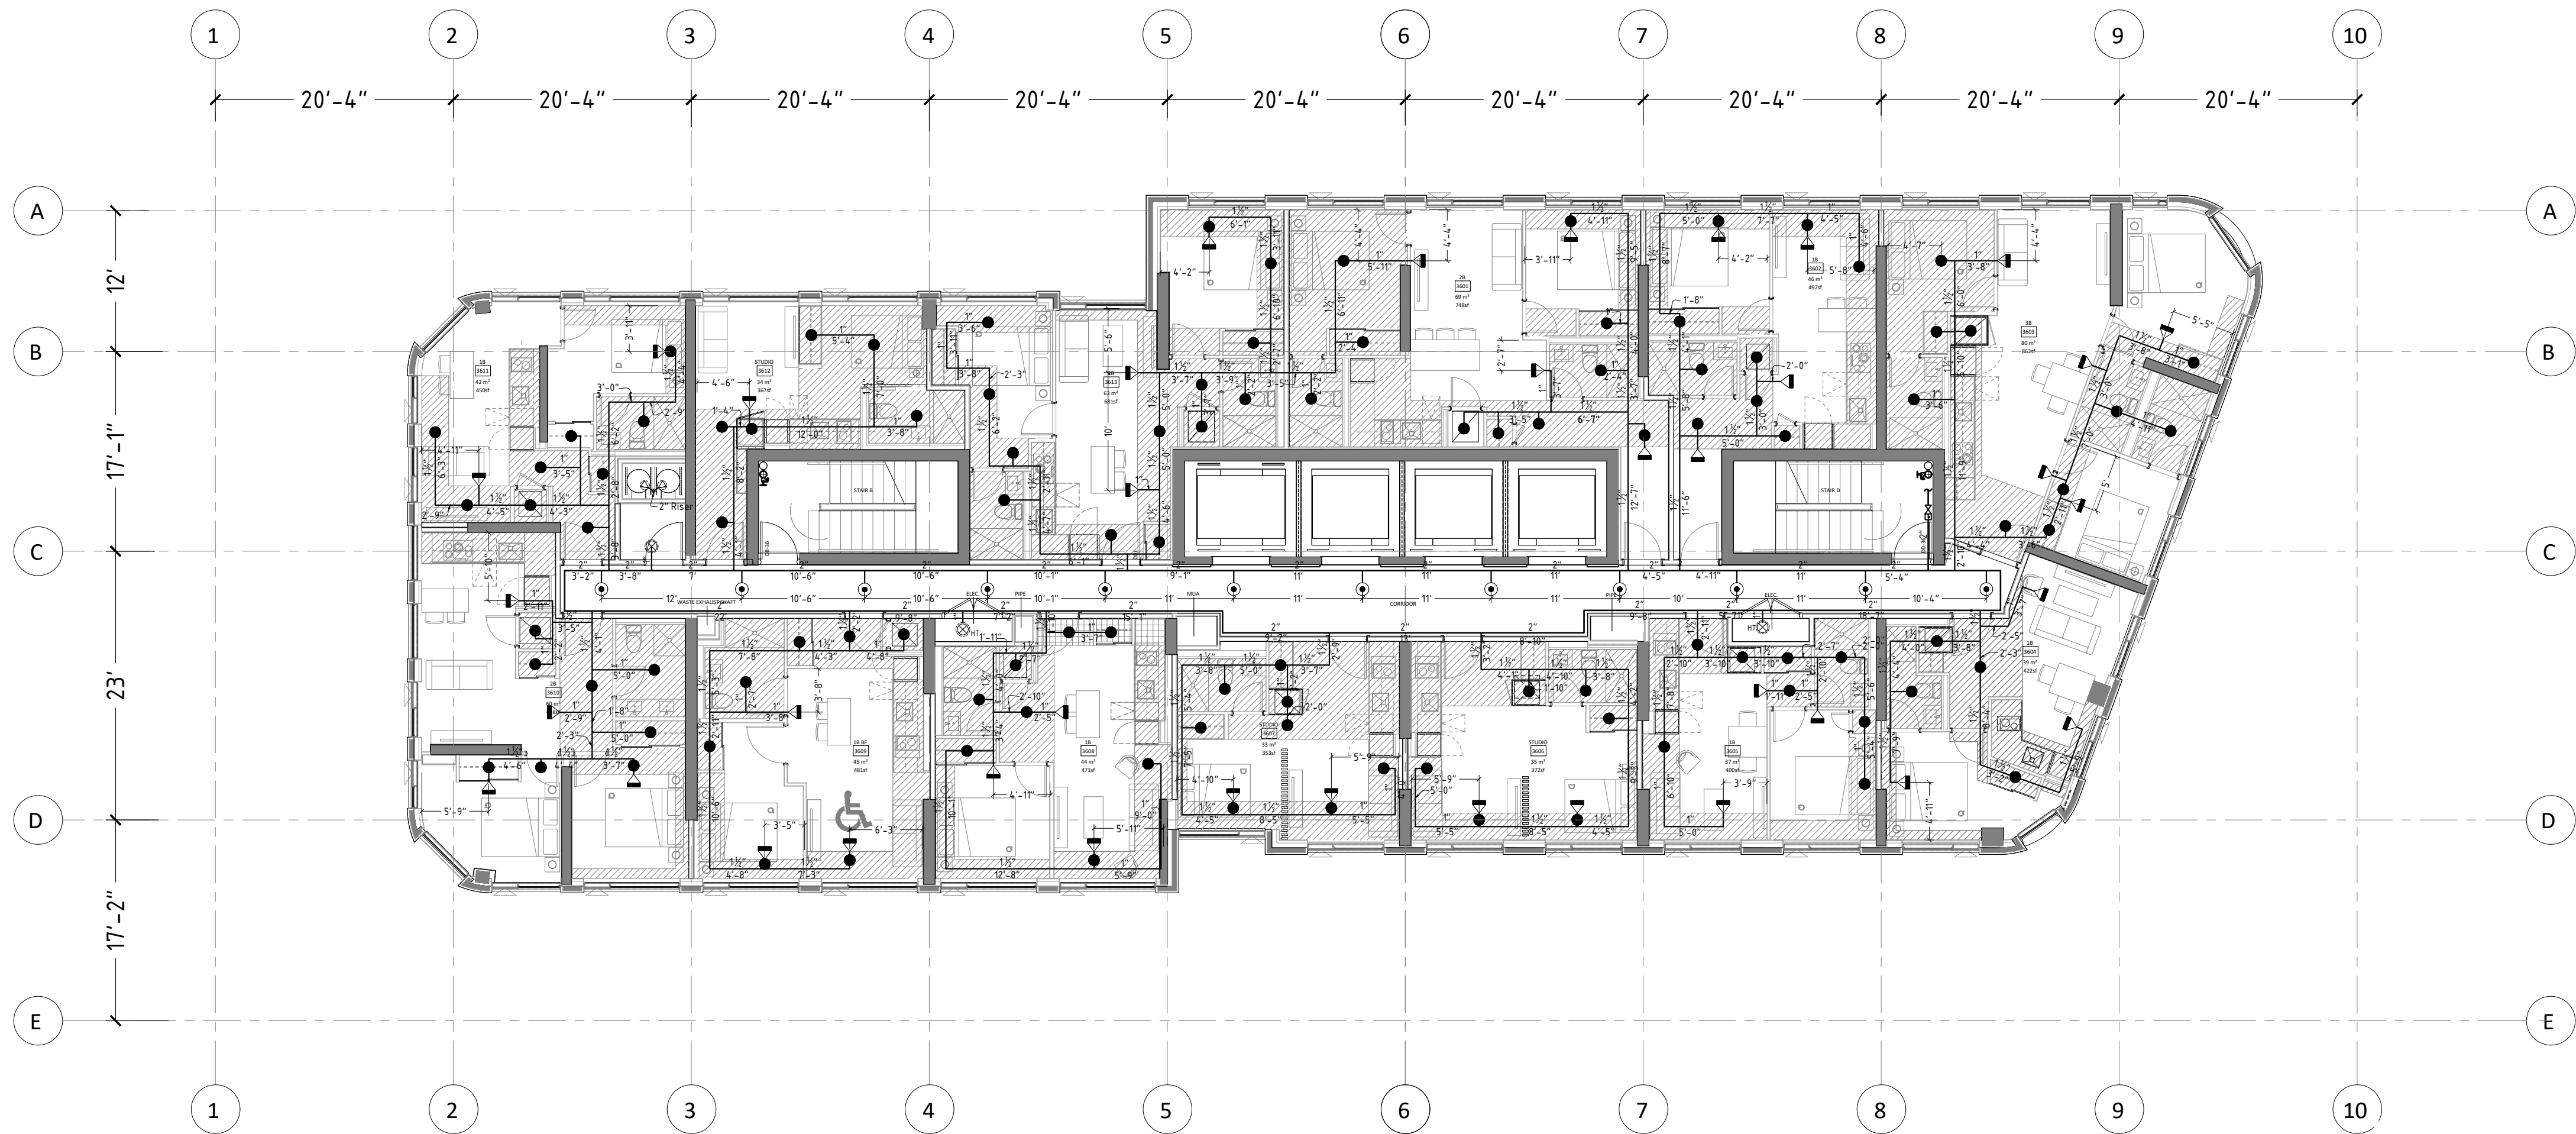

X	XX	XXXXXXXXXXXX
NO	DATE	DESCRIPTION
ISSUED/REVISION RECORD		


SPRINKLER HEAD LEGEND					
C / W GUARD					
S/R=STANDARD RESPONSE			Q/R=QUICK RESPONSE		
S/C=STANDARD COVERAGE			E/C=EXTENDED COVERAGE		
	THREAD/ SIZE	K- FACTOR	TEMP RATING	STYLE(MODEL)	RESPONSE
⊙	1/2"	14	155°F	EXTENDED COVERAGE UPRIGHT	S/R
○	1/2"	5.6	165°F	UPRIGHT S/C	S/R
⊗	1/2"	5.6	165°F	DRY UPRIGHT SPRINKLER HEAD	Q/R
⊙	1/2"	5.6	165°F	STANDARD COVERAGE UPRIGHT	Q/R
⊗	1/2"	5.6	212°F	STANDARD COVERAGE UPRIGHT	Q/R
⊙	1"	5.6	155°F	FULLY CONCEALED DRY PENDENT S/C	Q/R
⊗	1"	5.6	165°F	DRY PENDENT S/C	Q/R
⊙	1/2"	11.2	200°F	EXTENDED COVERAGE SIDEWALL	S/R
⊗	1/2"	5.6	155°F	WINDOW SPRINKLER	Q/R
⊙	1/2"	5.6	165°F	STANDARD COVERAGE SIDEWALL	Q/R
⊗	1/2"	5.8	200°F	RESIDENTIAL FULLY CONCEALED PENDENT	Q/R
⊙	1/2"	5.8	200°F	RESIDENTIAL FULLY CONCEALED SIDEWALL	Q/R
⊗	1/2"	5.6	165°F	CONCEALED PENDENT S/C	Q/R
⊙	1/2"	5.6	212°F	RESIDENTIAL FULLY CONCEALED PENDENT S/C	Q/R
⊗	1/2"	8.0	286°F	UPRIGHT IN LOCKER ROOM S/C	S/R
2 1/2" STANDARD FIRE HOSE VALVE					
C/W THREADED CAP IN STAIRWELL					
2 1/2" FIRE HOSE VALVE IN CABINET					
C/W FIRE EXTINGUISHER					

PROJECT
PROPOSED MIXED-USED DEVELOPMENT
ADDRESS:
775-783 Vaughan Rd & 670-680
Northcliffe Blvd, York, ON

DRAWING TITLE
36TH FLOOR
FIRE PROTECTION PLAN

 LIFELINE FIRE PROTECTION
www.lifelinefireprotection.com
50 Casimir Court, Concord, ON
L4K 4J5
(416)850-9477

PROJECT TRUE NORTH
22-0007
PROJECT
SK RJ
BY REVIEWED
SP-26

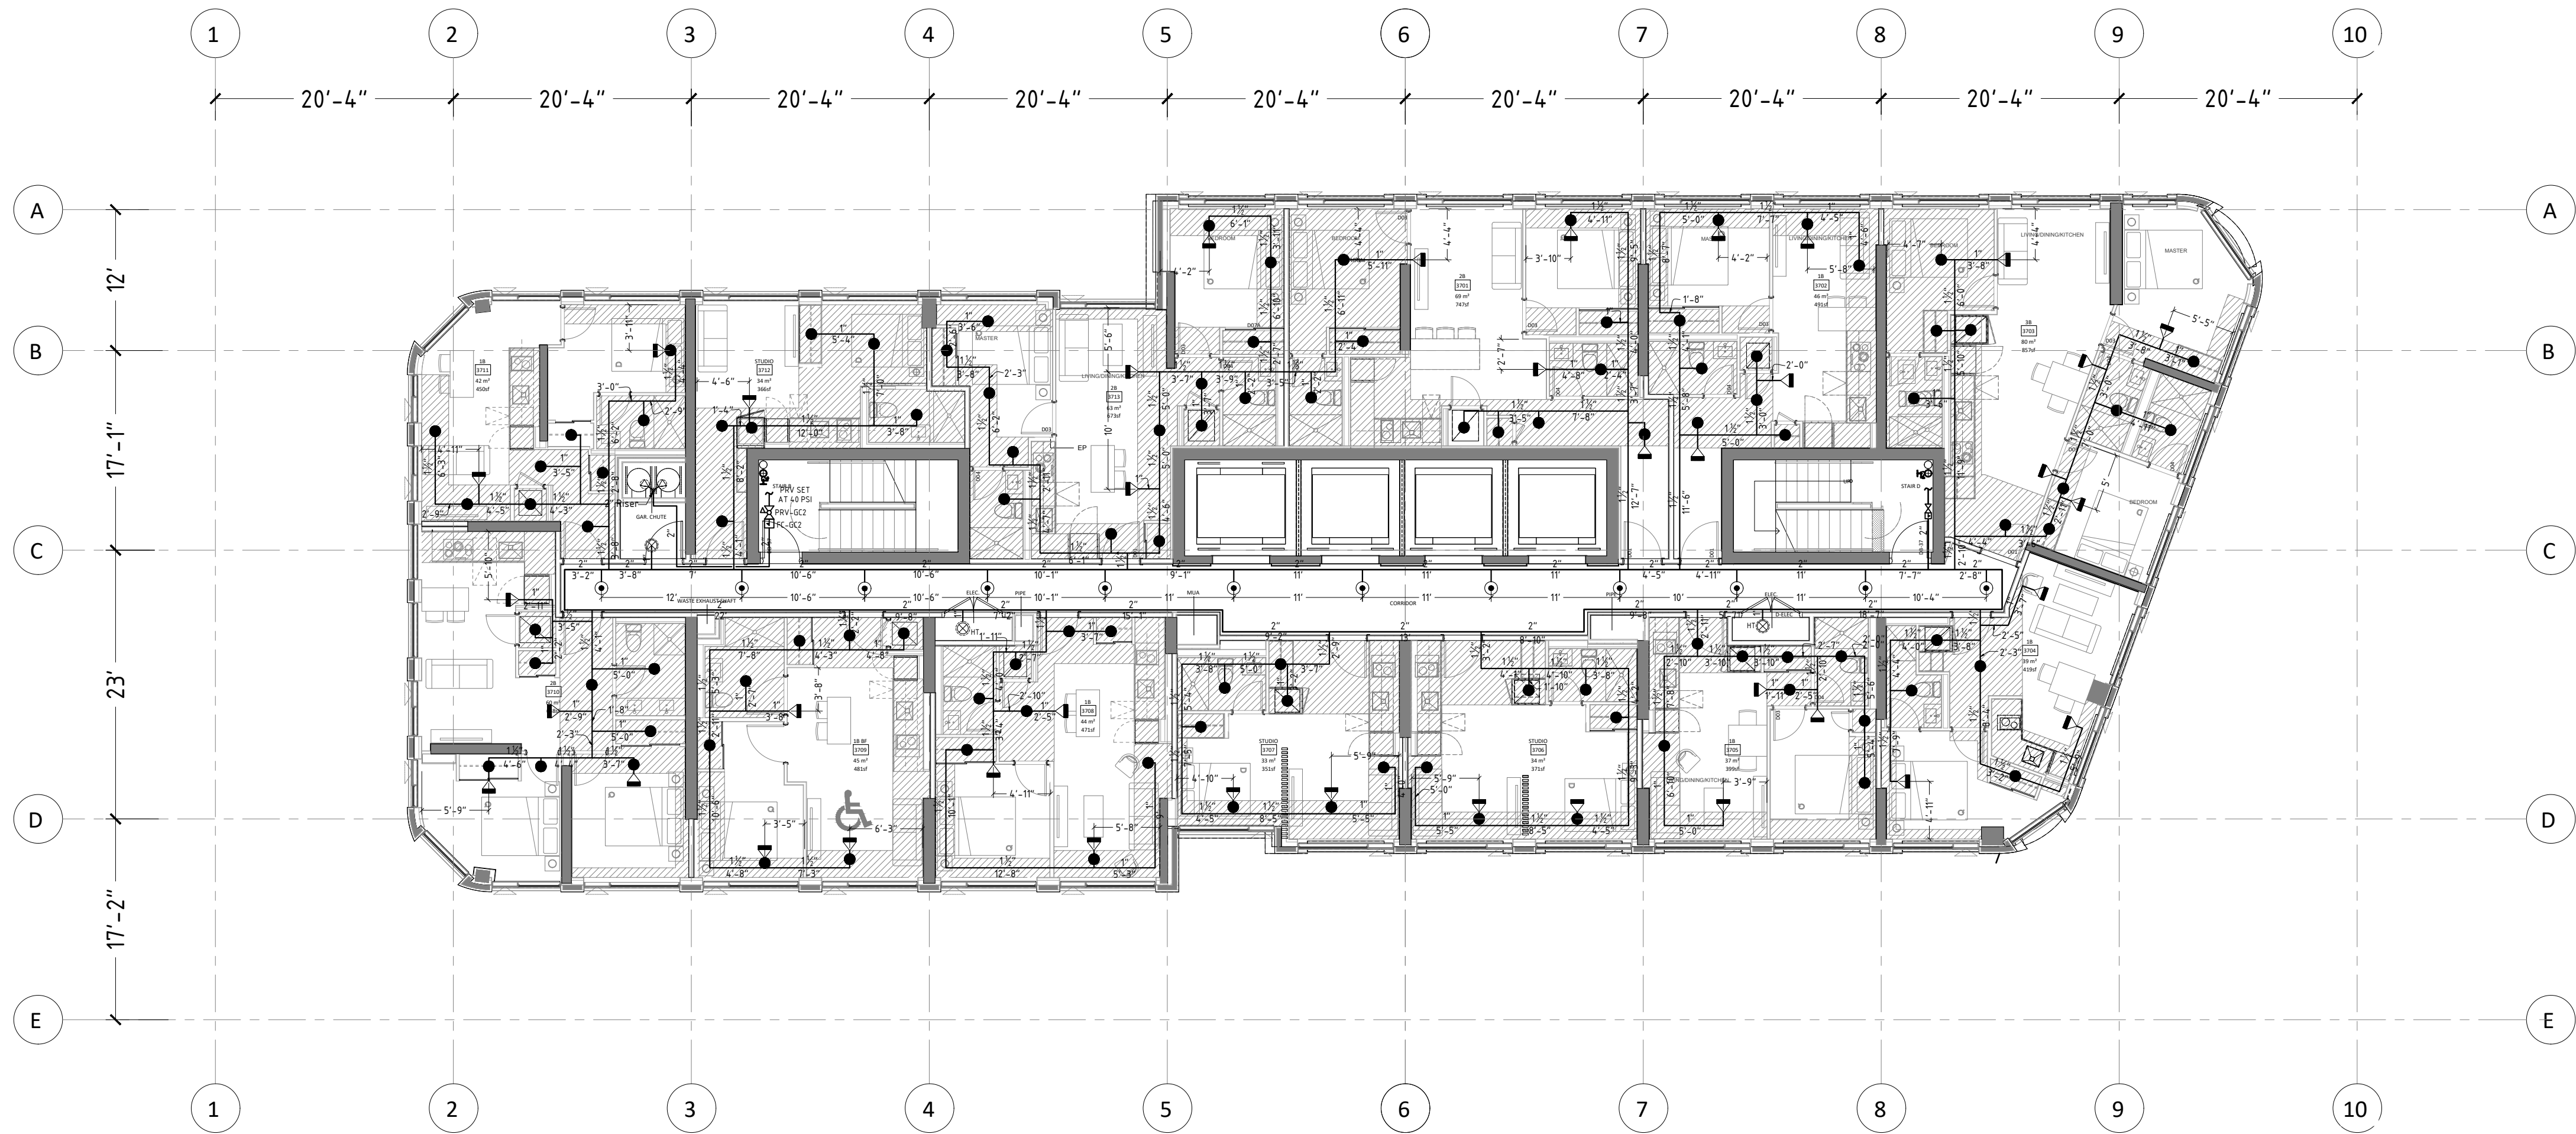


X	00	XXXXXXXXXXXX
NO	DATE	DESCRIPTION
ISSUED/REVISION RECORD		

SPRINKLER HEAD LEGEND


S/R=STANDARD RESPONSE S/C=STANDARD COVERAGE				C/W GUARD	Q/R=QUICK RESPONSE E/C=EXTENDED COVERAGE
	THREAD SIZE	K- FACTOR	TEMP RATING	STYLE(MODEL)	RESPONSE
⊙	1/2"	155	155°F	EXTENDED COVERAGE UPRIGHT	S/R
○	1/2"	165	165°F	UPRIGHT S/C	S/R
⊗	1/2"	165	165°F	DRY UPRIGHT SPRINKLER HEAD	Q/R
⊙	1/2"	165	165°F	STANDARD COVERAGE UPRIGHT	Q/R
⊙	1/2"	165	212°F	STANDARD COVERAGE UPRIGHT	Q/R
⊙	1"	155	155°F	FULLY CONCEALED DRY PENDENT S/C	Q/R
⊙	1"	165	165°F	DRY PENDENT S/C	Q/R
⊙	1/2"	112	200°F	EXTENDED COVERAGE SIDEWALL	S/R
⊙	1/2"	155	155°F	WINDOW SPRINKLER	Q/R
⊙	1/2"	165	165°F	STANDARD COVERAGE SIDEWALL	Q/R
⊙	1/2"	158	200°F	RESIDENTIAL FULLY CONCEALED PENDENT	Q/R
⊙	1/2"	158	200°F	RESIDENTIAL FULLY CONCEALED SIDEWALL	Q/R
⊙	1/2"	165	165°F	CONCEALED PENDENT S/C	Q/R
⊙	1/2"	156	212°F	RESIDENTIAL FULLY CONCEALED PENDENT S/C	Q/R
⊙	1/2"	180	286°F	UPRIGHT IN LOCKER ROOM S/C	S/R
hpd	2 1/2" STANDARD FIRE HOSE VALVE C/W THREADED CAP IN STAIRWELL				
hpd	2 1/2" FIRE HOSE VALVE IN CABINET C/W FIRE EXTINGUISHER				

PROJECT
PROPOSED MIXED-USED DEVELOPMENT
ADDRESS:
775-783 Vaughan Rd & 670-680
Northcliffe Blvd, York, ON

DRAWING TITLE
37TH FLOOR
FIRE PROTECTION PLAN

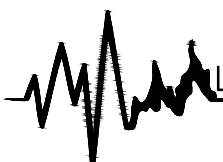 LIFELINE FIRE PROTECTION
www.lifelinefireprotection.com
50 Casimir Court, Concord, ON
L4K 4J5
(416)850-9477

PROJECT NORTH NORTH	22-0007 PROJECT SK RJ BY REVIEWED
SP-27	

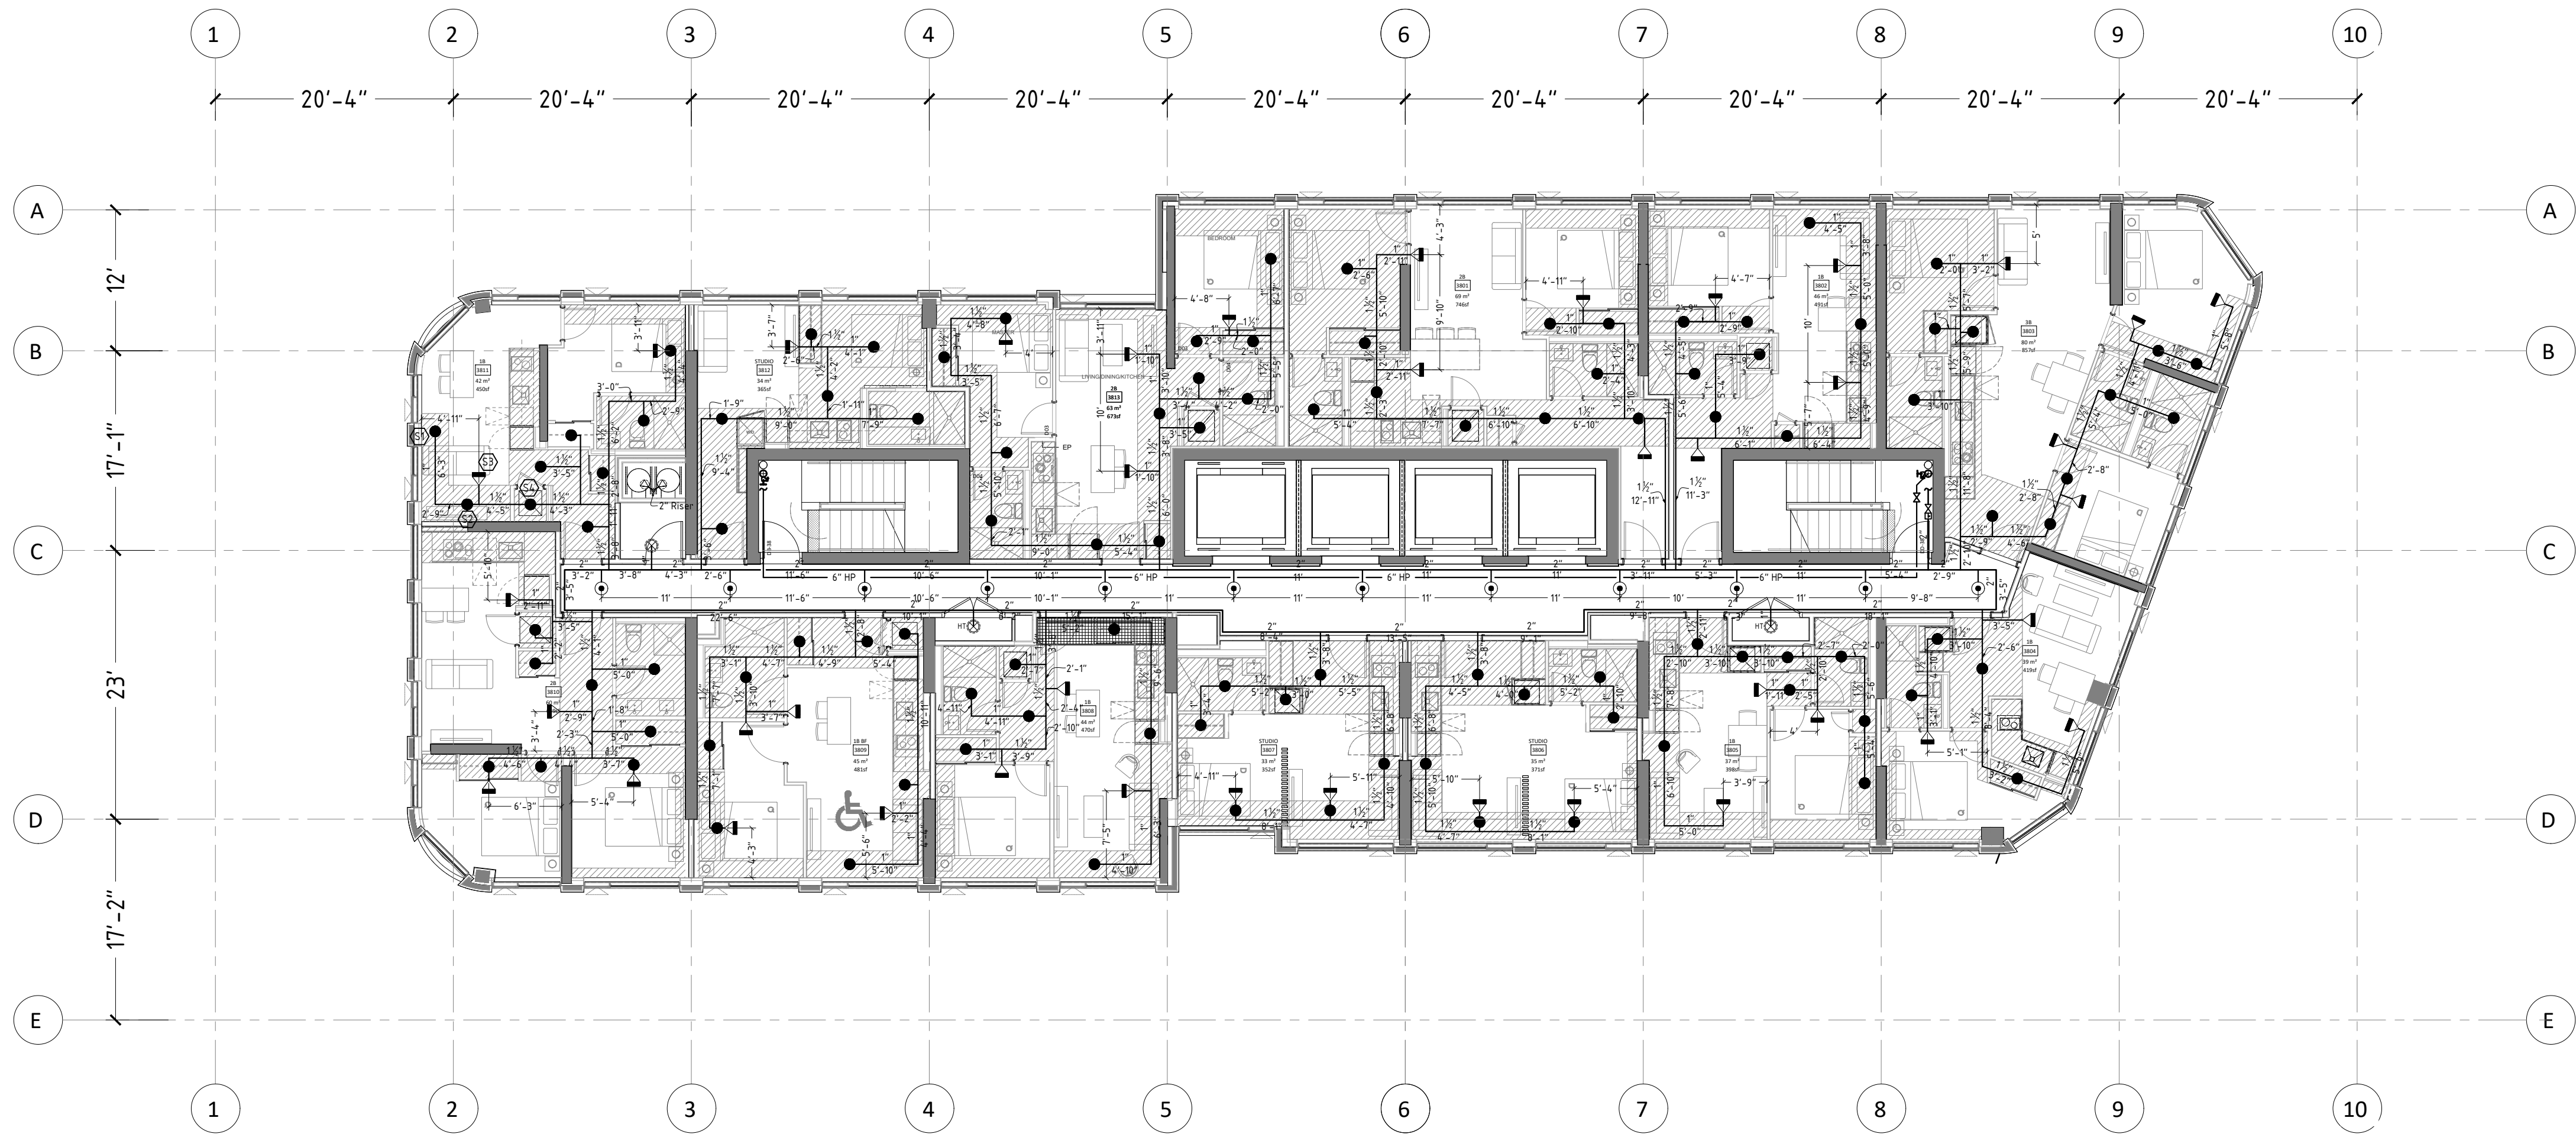

X	00	XXXXXXXXXXXX
NO	DATE	DESCRIPTION
ISSUED/REVISION RECORD		


SPRINKLER HEAD LEGEND				
S/R=STANDARD RESPONSE S/C=STANDARD COVERAGE				
Q/R=QUICK RESPONSE E/C=EXTENDED COVERAGE				
THREADED SIZE	K- FACTOR	TEMP RATING	STYLE(MODEL)	RESPONSE
⊙	1/2"	14	EXTENDED COVERAGE UPRIGHT	S/R
○	1/2"	5.6	UPRIGHT S/C	S/R
⊗	1/2"	5.6	DRY UPRIGHT SPRINKLER HEAD	Q/R
⊙	1/2"	5.6	STANDARD COVERAGE UPRIGHT	Q/R
⊗	1/2"	5.6	STANDARD COVERAGE UPRIGHT	Q/R
⊙	1"	5.6	FULLY CONCEALED DRY PENDENT S/C	Q/R
⊙	1"	5.6	DRY PENDENT S/C	Q/R
⊙	1/2"	11.2	EXTENDED COVERAGE SIDEWALL	S/R
⊙	1/2"	5.6	WINDOW SPRINKLER	Q/R
⊙	1/2"	5.6	STANDARD COVERAGE SIDEWALL	Q/R
⊙	1/2"	5.8	RESIDENTIAL FULLY CONCEALED PENDENT	Q/R
⊙	1/2"	5.8	RESIDENTIAL FULLY CONCEALED SIDEWALL	Q/R
⊙	1/2"	5.6	CONCEALED PENDENT S/C	Q/R
⊙	1/2"	5.6	RESIDENTIAL FULLY CONCEALED PENDENT S/C	Q/R
⊙	1/2"	5.6	UPRIGHT IN LOCKER ROOM S/C	S/R
⊙	1/2"	286°F	2 1/2" STANDARD FIRE HOSE VALVE C/W THREADED CAP IN STAIRWELL	
⊙	1/2"	286°F	2 1/2" FIRE HOSE VALVE IN CABINET C/W FIRE EXTINGUISHER	

PROJECT
PROPOSED MIXED-USED DEVELOPMENT
ADDRESS:
775-783 Vaughan Rd & 670-680
Northcliffe Blvd, York, ON

DRAWING TITLE
38TH FLOOR
FIRE PROTECTION PLAN

LIFELINE FIRE PROTECTION
www.lifelinefireprotection.com
50 Casimir Court, Concord, ON
L4K 4J5
(416)850-9477

PROJECT TRUE
NORTH NORTH
22-0007
PROJECT
SK RJ
BY REVIEWED
SP-28

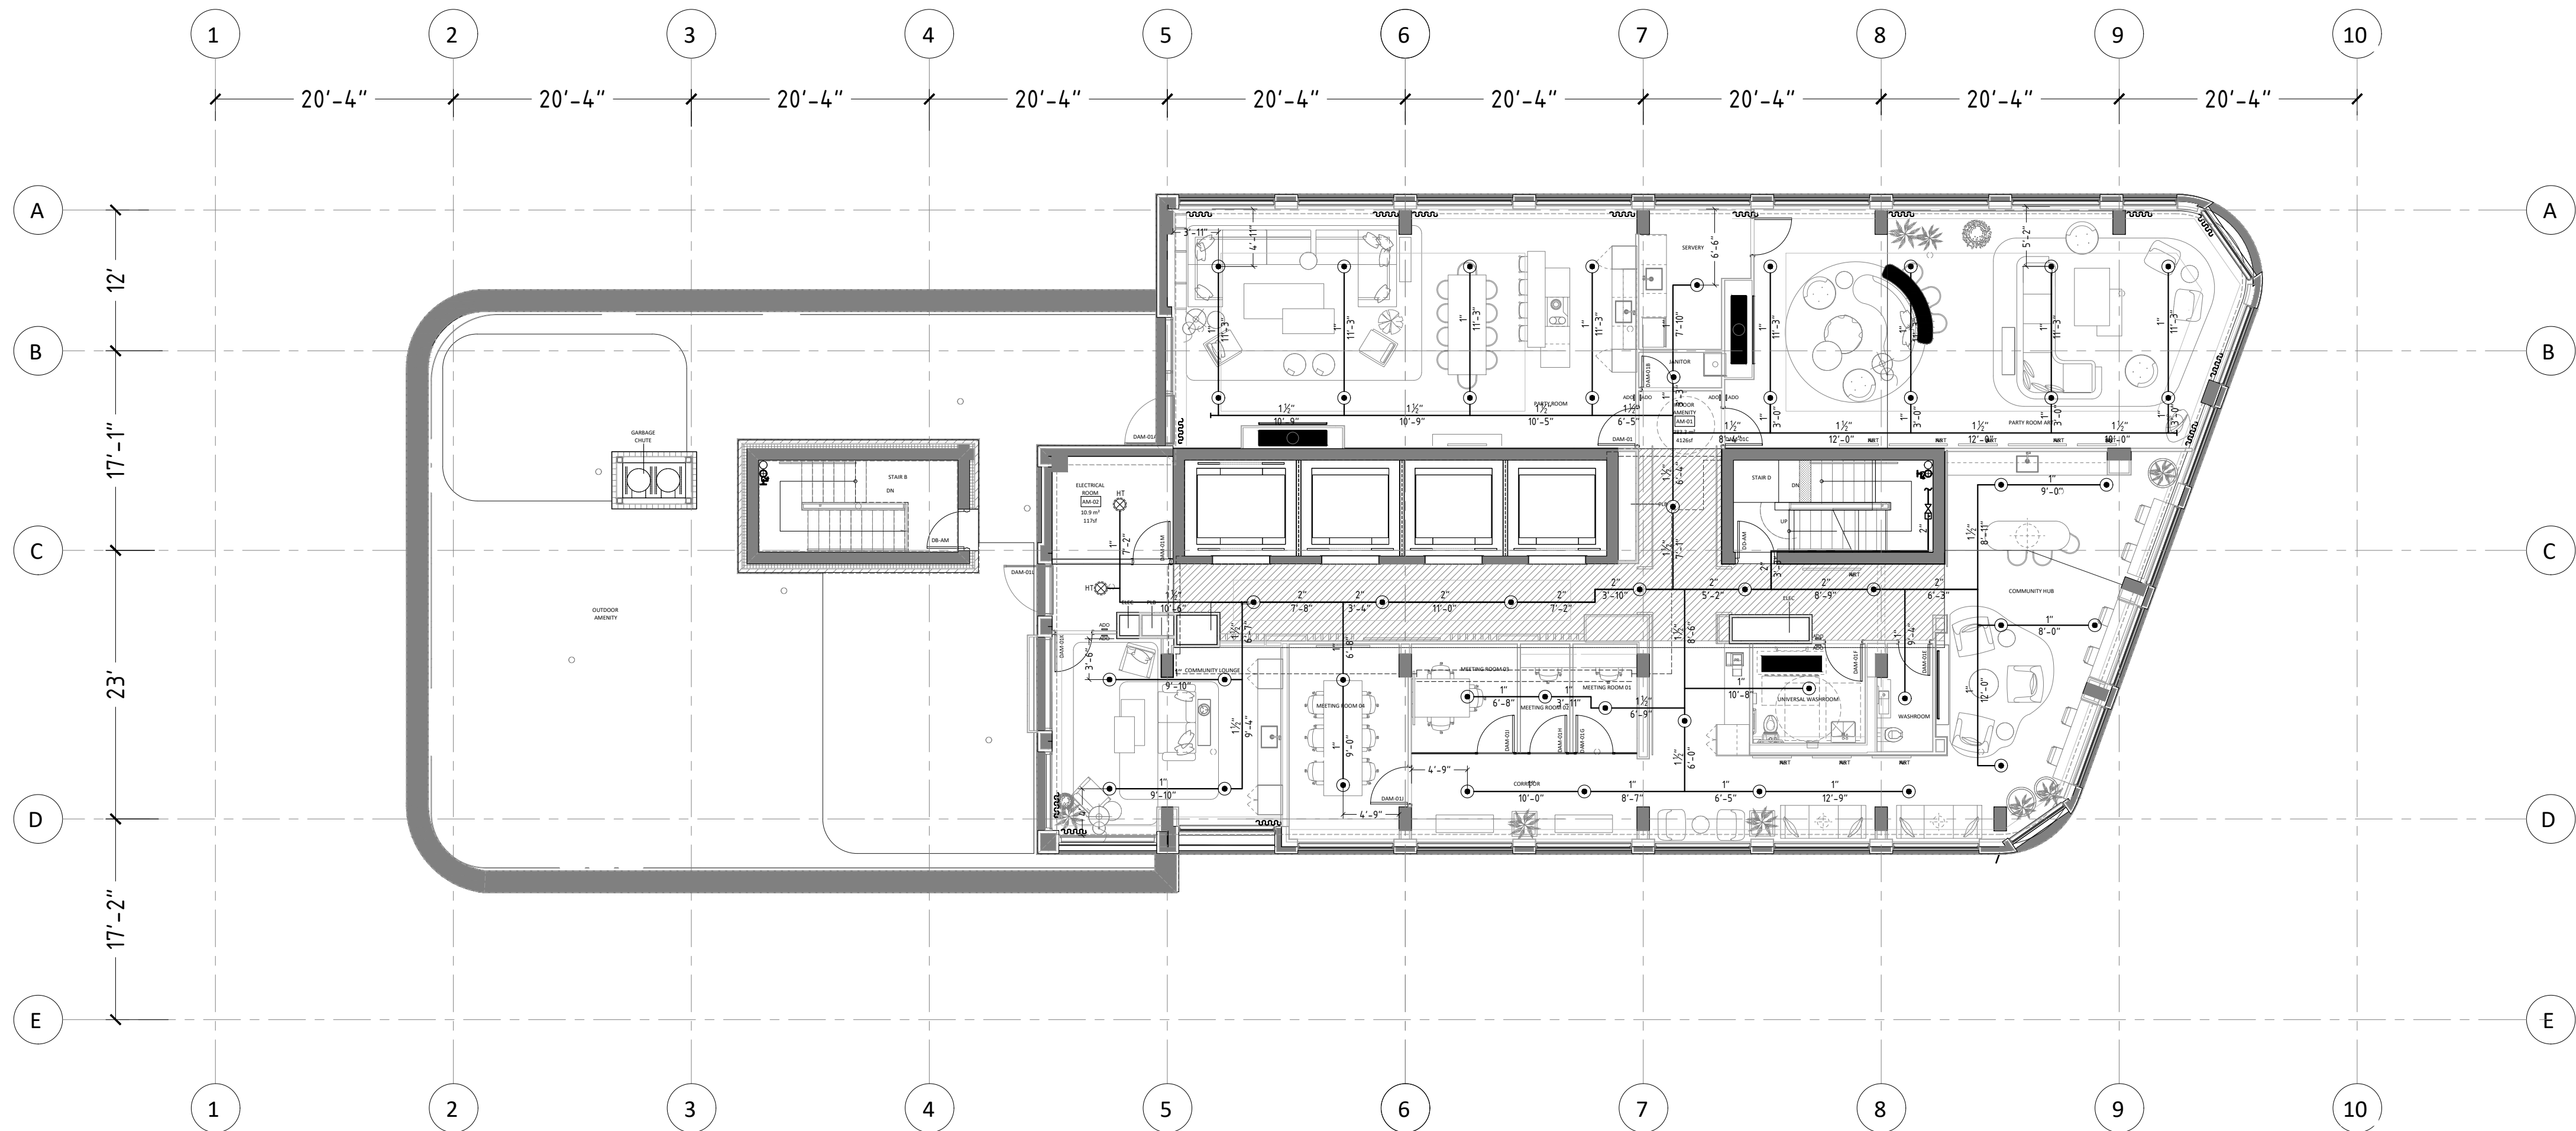

X	00	XXXXXXXXXXXX
NO	DATE	DESCRIPTION
ISSUED/REVISION RECORD		

SPRINKLER HEAD LEGEND

C / W GUARD

S/R=STANDARD RESPONSE
S/C=STANDARD COVERAGE

Q/R=QUICK RESPONSE
E/C=EXTENDED COVERAGE


	THREAD SIZE	K-FACTOR	TEMP RATING	STYLE/MODEL	RESPONSE
	1/2"	14	155°F	EXTENDED COVERAGE UPRIGHT	S/R
	1/2"	5.6	165°F	UPRIGHT S/C	S/R
	1/2"	5.6	165°F	DRY UPRIGHT SPRINKLER HEAD	Q/R
	1/2"	5.6	165°F	STANDARD COVERAGE UPRIGHT	Q/R
	1/2"	5.6	212°F	STANDARD COVERAGE UPRIGHT	Q/R
	1"	5.6	155°F	FULLY CONCEALED DRY PENDENT S/C	Q/R
	1"	5.6	165°F	DRY PENDENT S/C	Q/R
	1/2"	11.2	200°F	EXTENDED COVERAGE SIDEWALL	S/R
	1/2"	5.6	155°F	WINDOW SPRINKLER	Q/R
	1/2"	5.6	165°F	STANDARD COVERAGE SIDEWALL	Q/R
	1/2"	5.8	200°F	RESIDENTIAL FULLY CONCEALED PENDENT	Q/R
	1/2"	5.8	200°F	RESIDENTIAL FULLY CONCEALED SIDEWALL	Q/R
	1/2"	5.6	165°F	CONCEALED PENDENT S/C	Q/R
	1/2"	5.6	212°F	RESIDENTIAL FULLY CONCEALED PENDENT S/C	Q/R
	1/2"	8.0	286°F	UPRIGHT IN LOCKER ROOM S/C	S/R
	2 1/2" STANDARD FIRE HOSE VALVE				
	2 1/2" THREADED CAP IN STAIRWELL				
	2 1/2" FIRE HOSE VALVE IN CABINET				
	C/W FIRE EXTINGUISHER				

PROJECT
PROPOSED MIXED-USED DEVELOPMENT
ADDRESS:
775-783 Vaughan Rd & 670-680
Northcliffe Blvd, York, ON

DRAWING TITLE
AMENITY FLOOR
FIRE PROTECTION PLAN

LIFELINE FIRE PROTECTION
www.lifelinefireprotection.com
50 Casimir Court, Concord, ON
L4K 4J5
(416)850-9477

	PROJECT	22-0007
	DATE	PROJECT
	BY	RJ
	REVIEWED	
		SP-29

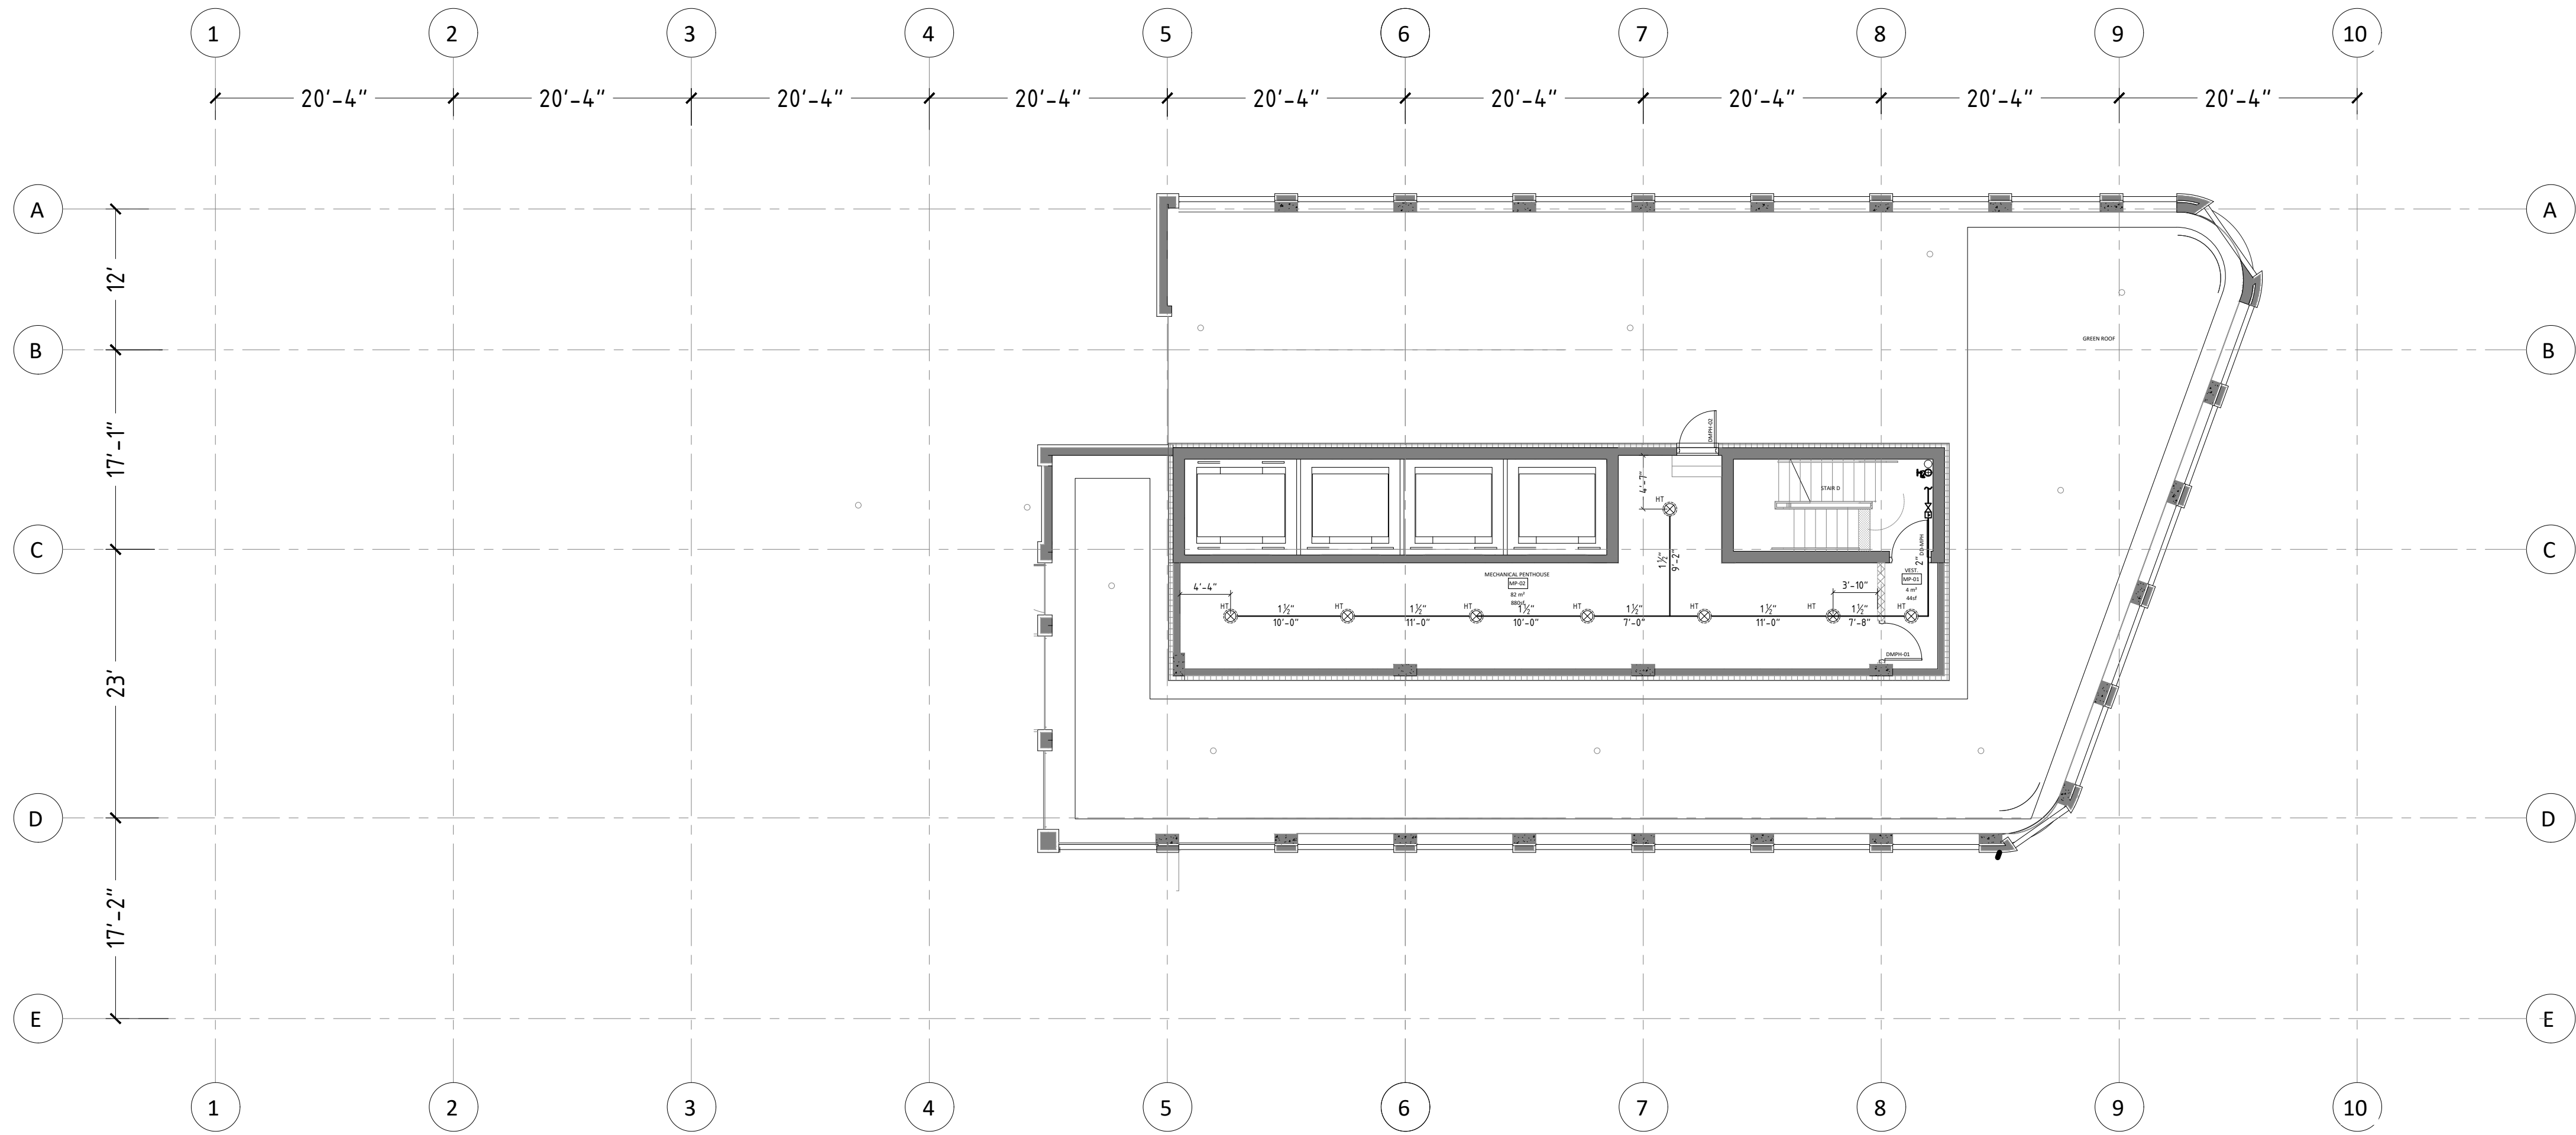



X	000	XXXXXXXXXXXX
NO	DATE	DESCRIPTION
ISSUED/REVISION RECORD		


SPRINKLER HEAD LEGEND				
C/W GUARD				
S/R=STANDARD RESPONSE		Q/R=QUICK RESPONSE		
S/C=STANDARD COVERAGE		E/C=EXTENDED COVERAGE		
SYMBOL	THREAD SIZE	K-FACTOR	TEMP RATING	STYLE(MODEL)
⊙	1/2"	14	155°F	EXTENDED COVERAGE UPRIGHT
○	1/2"	5.6	165°F	UPRIGHT S/C
⊗	1/2"	5.6	165°F	DRY UPRIGHT SPRINKLER HEAD
⊙	1/2"	5.6	165°F	STANDARD COVERAGE UPRIGHT
⊗	1/2"	5.6	212°F	STANDARD COVERAGE UPRIGHT
⊙	1"	5.6	155°F	FULLY CONCEALED DRY PENDENT S/C
⊙	1"	5.6	165°F	DRY PENDENT S/C
◀	1/2"	11.2	200°F	EXTENDED COVERAGE SIDEWALL
▲	1/2"	5.6	155°F	WINDOW SPRINKLER
◀	1/2"	5.6	165°F	STANDARD COVERAGE SIDEWALL
●	1/2"	5.8	200°F	RESIDENTIAL FULLY CONCEALED PENDENT
◐	1/2"	5.8	200°F	RESIDENTIAL FULLY CONCEALED SIDEWALL
⊙	1/2"	5.6	165°F	CONCEALED PENDENT S/C
⊙	1/2"	5.6	212°F	RESIDENTIAL FULLY CONCEALED PENDENT S/C
⊙	1/2"	8.0	286°F	UPRIGHT IN LOCKER ROOM S/C
hpf	2 1/2" STANDARD FIRE HOSE VALVE C/W THREADED CAP IN STAIRWELL			
hpf	2 1/2" FIRE HOSE VALVE IN CABINET C/W FIRE EXTINGUISHER			

PROJECT
PROPOSED MIXED-USED DEVELOPMENT
ADDRESS:
775-783 Vaughan Rd & 670-680
Northcliffe Blvd, York, ON

DRAWING TITLE
MECH. PENTHOUSE
FIRE PROTECTION PLAN

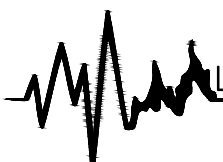 LIFELINE FIRE PROTECTION
www.lifelinefireprotection.com
50 Casimir Court, Concord, ON
L4K 4J5
(416)850-9477

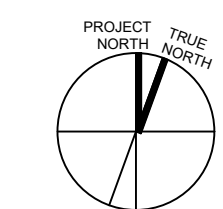	PROJECT 22-0007
	SK BY
	PROJECT RJ REVIEWED
	SP-30

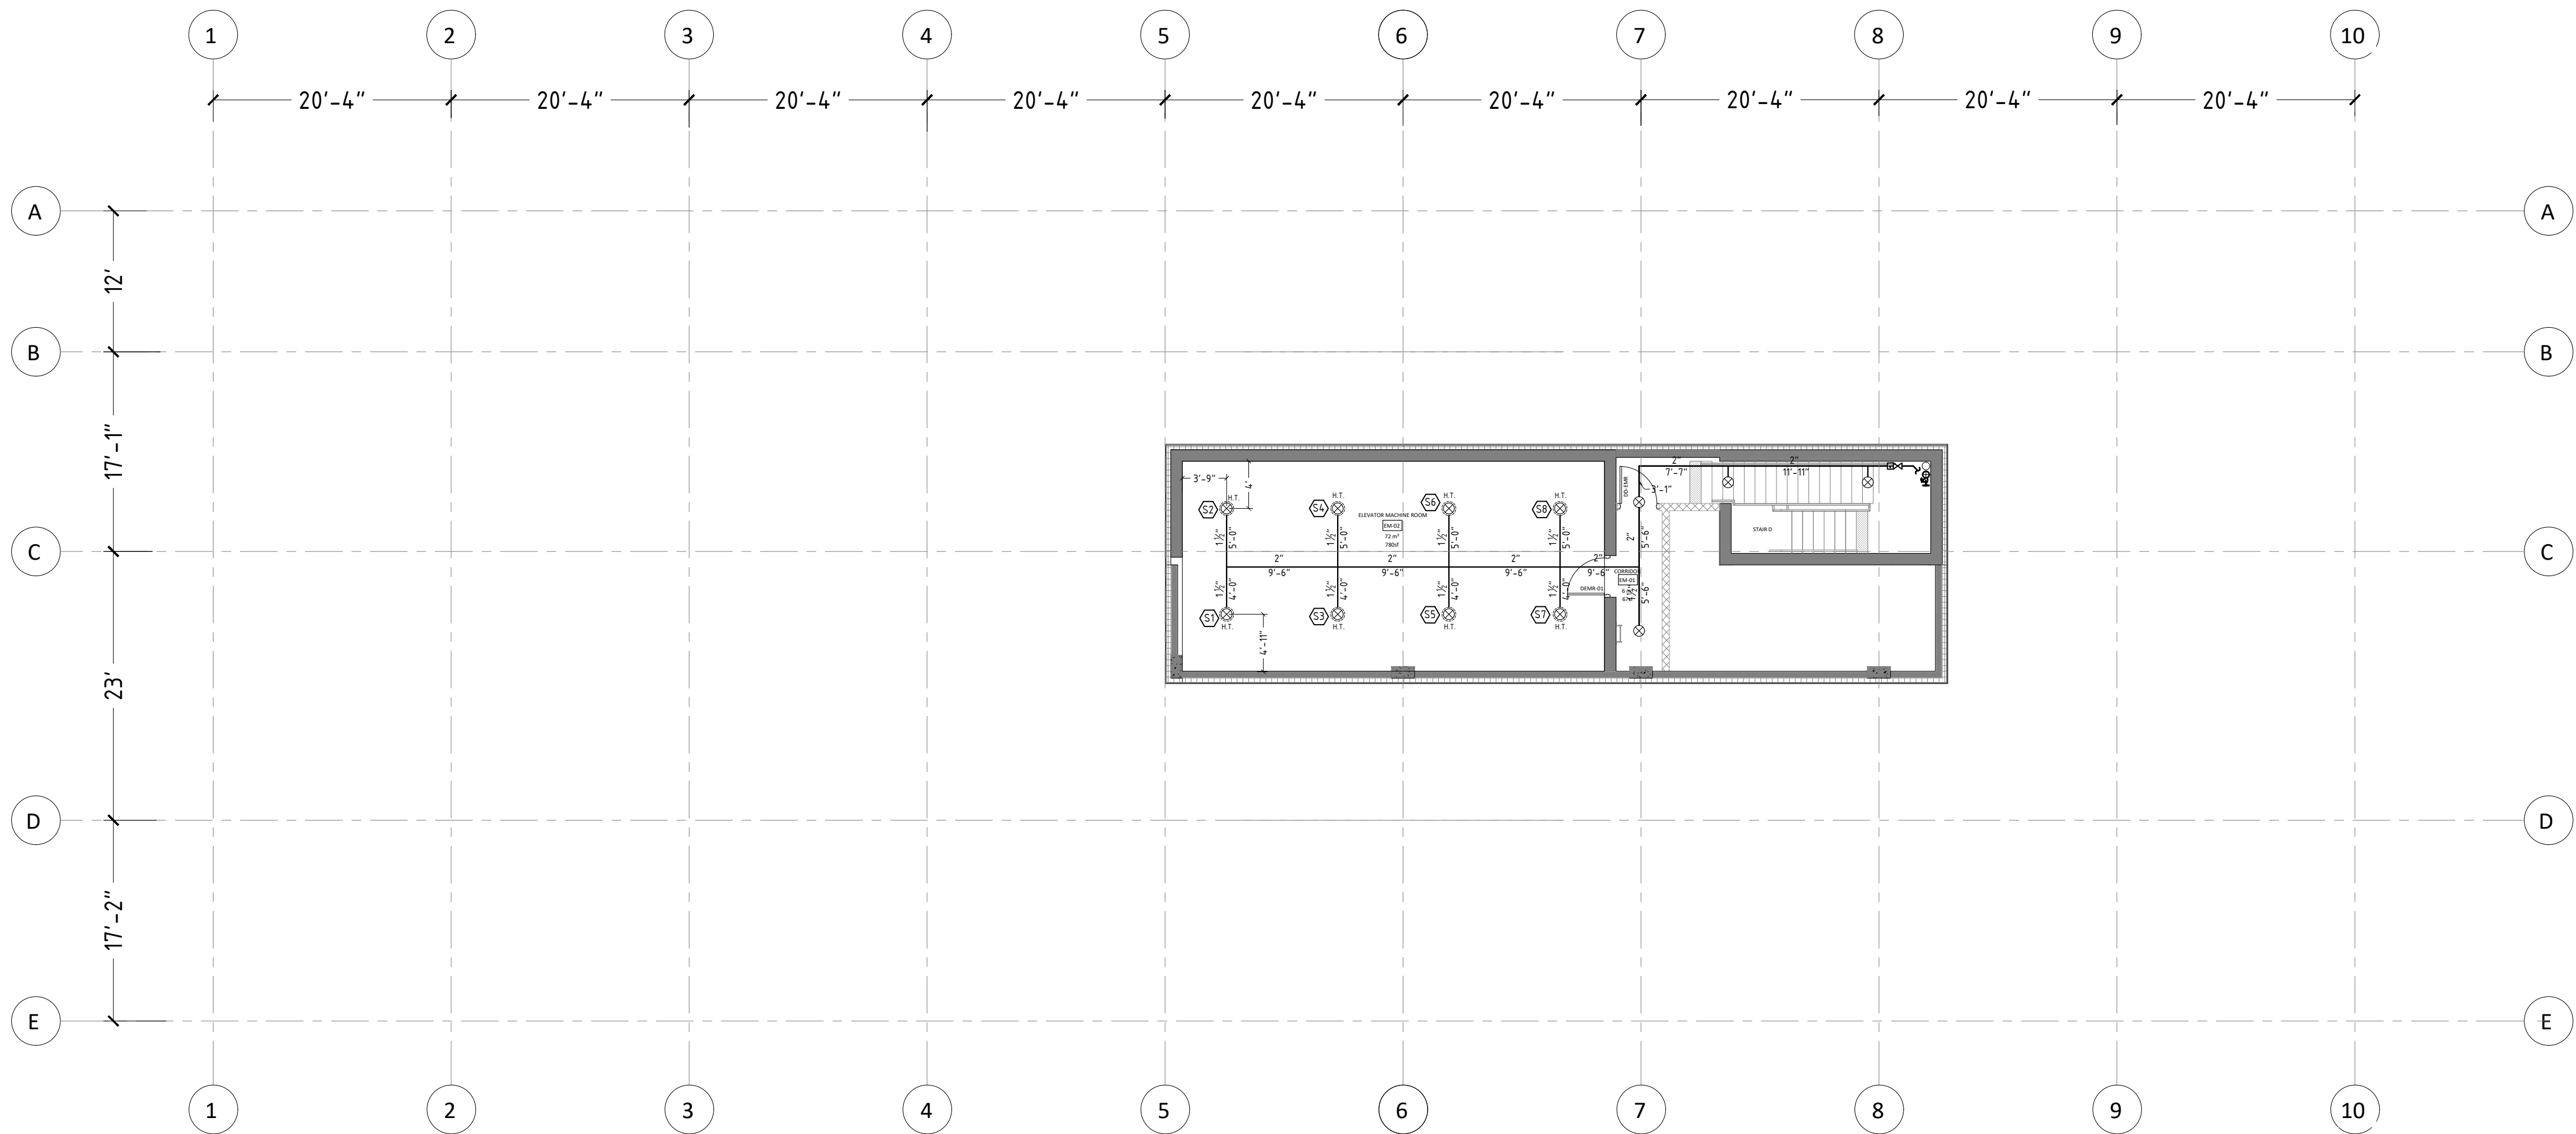



X	00	0000000000
NO	DATE	DESCRIPTION
ISSUED/REVISION RECORD		

SPRINKLER HEAD LEGEND				
C/W GUARD				
S/R=STANDARD RESPONSE		Q/R=QUICK RESPONSE		
S/C=STANDARD COVERAGE		E/C=EXTENDED COVERAGE		
THREAD	K-FACTOR	TEMP RATING	STYLE(MODEL)	RESPONSE
1/2"	14	155°F	EXTENDED COVERAGE UPRIGHT	S/R
1/2"	5.6	165°F	UPRIGHT S/C	S/R
1/2"	5.6	165°F	DRY UPRIGHT SPRINKLER HEAD	Q/R
1/2"	5.6	165°F	STANDARD COVERAGE UPRIGHT	Q/R
1/2"	5.6	212°F	STANDARD COVERAGE UPRIGHT	Q/R
1"	5.6	155°F	FULLY CONCEALED DRY PENDENT S/C	Q/R
1"	5.6	165°F	DRY PENDENT S/C	Q/R
1/2"	11.2	200°F	EXTENDED COVERAGE SIDEWALL	S/R
1/2"	5.6	155°F	WINDOW SPRINKLER	Q/R
1/2"	5.6	165°F	STANDARD COVERAGE SIDEWALL	Q/R
1/2"	5.8	200°F	RESIDENTIAL FULLY CONCEALED PENDENT	Q/R
1/2"	5.8	200°F	RESIDENTIAL FULLY CONCEALED SIDEWALL	Q/R
1/2"	5.6	165°F	CONCEALED PENDENT S/C	Q/R
1/2"	5.6	212°F	RESIDENTIAL FULLY CONCEALED PENDENT S/C	Q/R
1/2"	8.0	286°F	UPRIGHT IN LOCKER ROOM S/C	S/R
2 1/2"	STANDARD FIRE HOSE VALVE C/W THREADED CAP IN STAIRWELL			
2 1/2"	FIRE HOSE VALVE IN CABINET C/W FIRE EXTINGUISHER			

PROJECT
PROPOSED MIXED-USED DEVELOPMENT
ADDRESS:
775-783 Vaughan Rd & 670-680
Northcliffe Blvd, York, ON

DRAWING TITLE
ELEVATOR MACHINE ROOM
FIRE PROTECTION PLAN

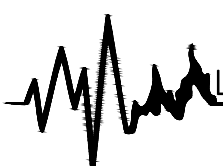 LIFELINE FIRE PROTECTION
www.lifelinefireprotection.com
50 Casimir Court, Concord, ON
L4K 4J5
(416)850-9477

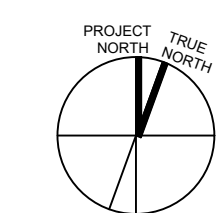	22-0007 PROJECT
	SK RJ BY REVIEWED
SP-31	